


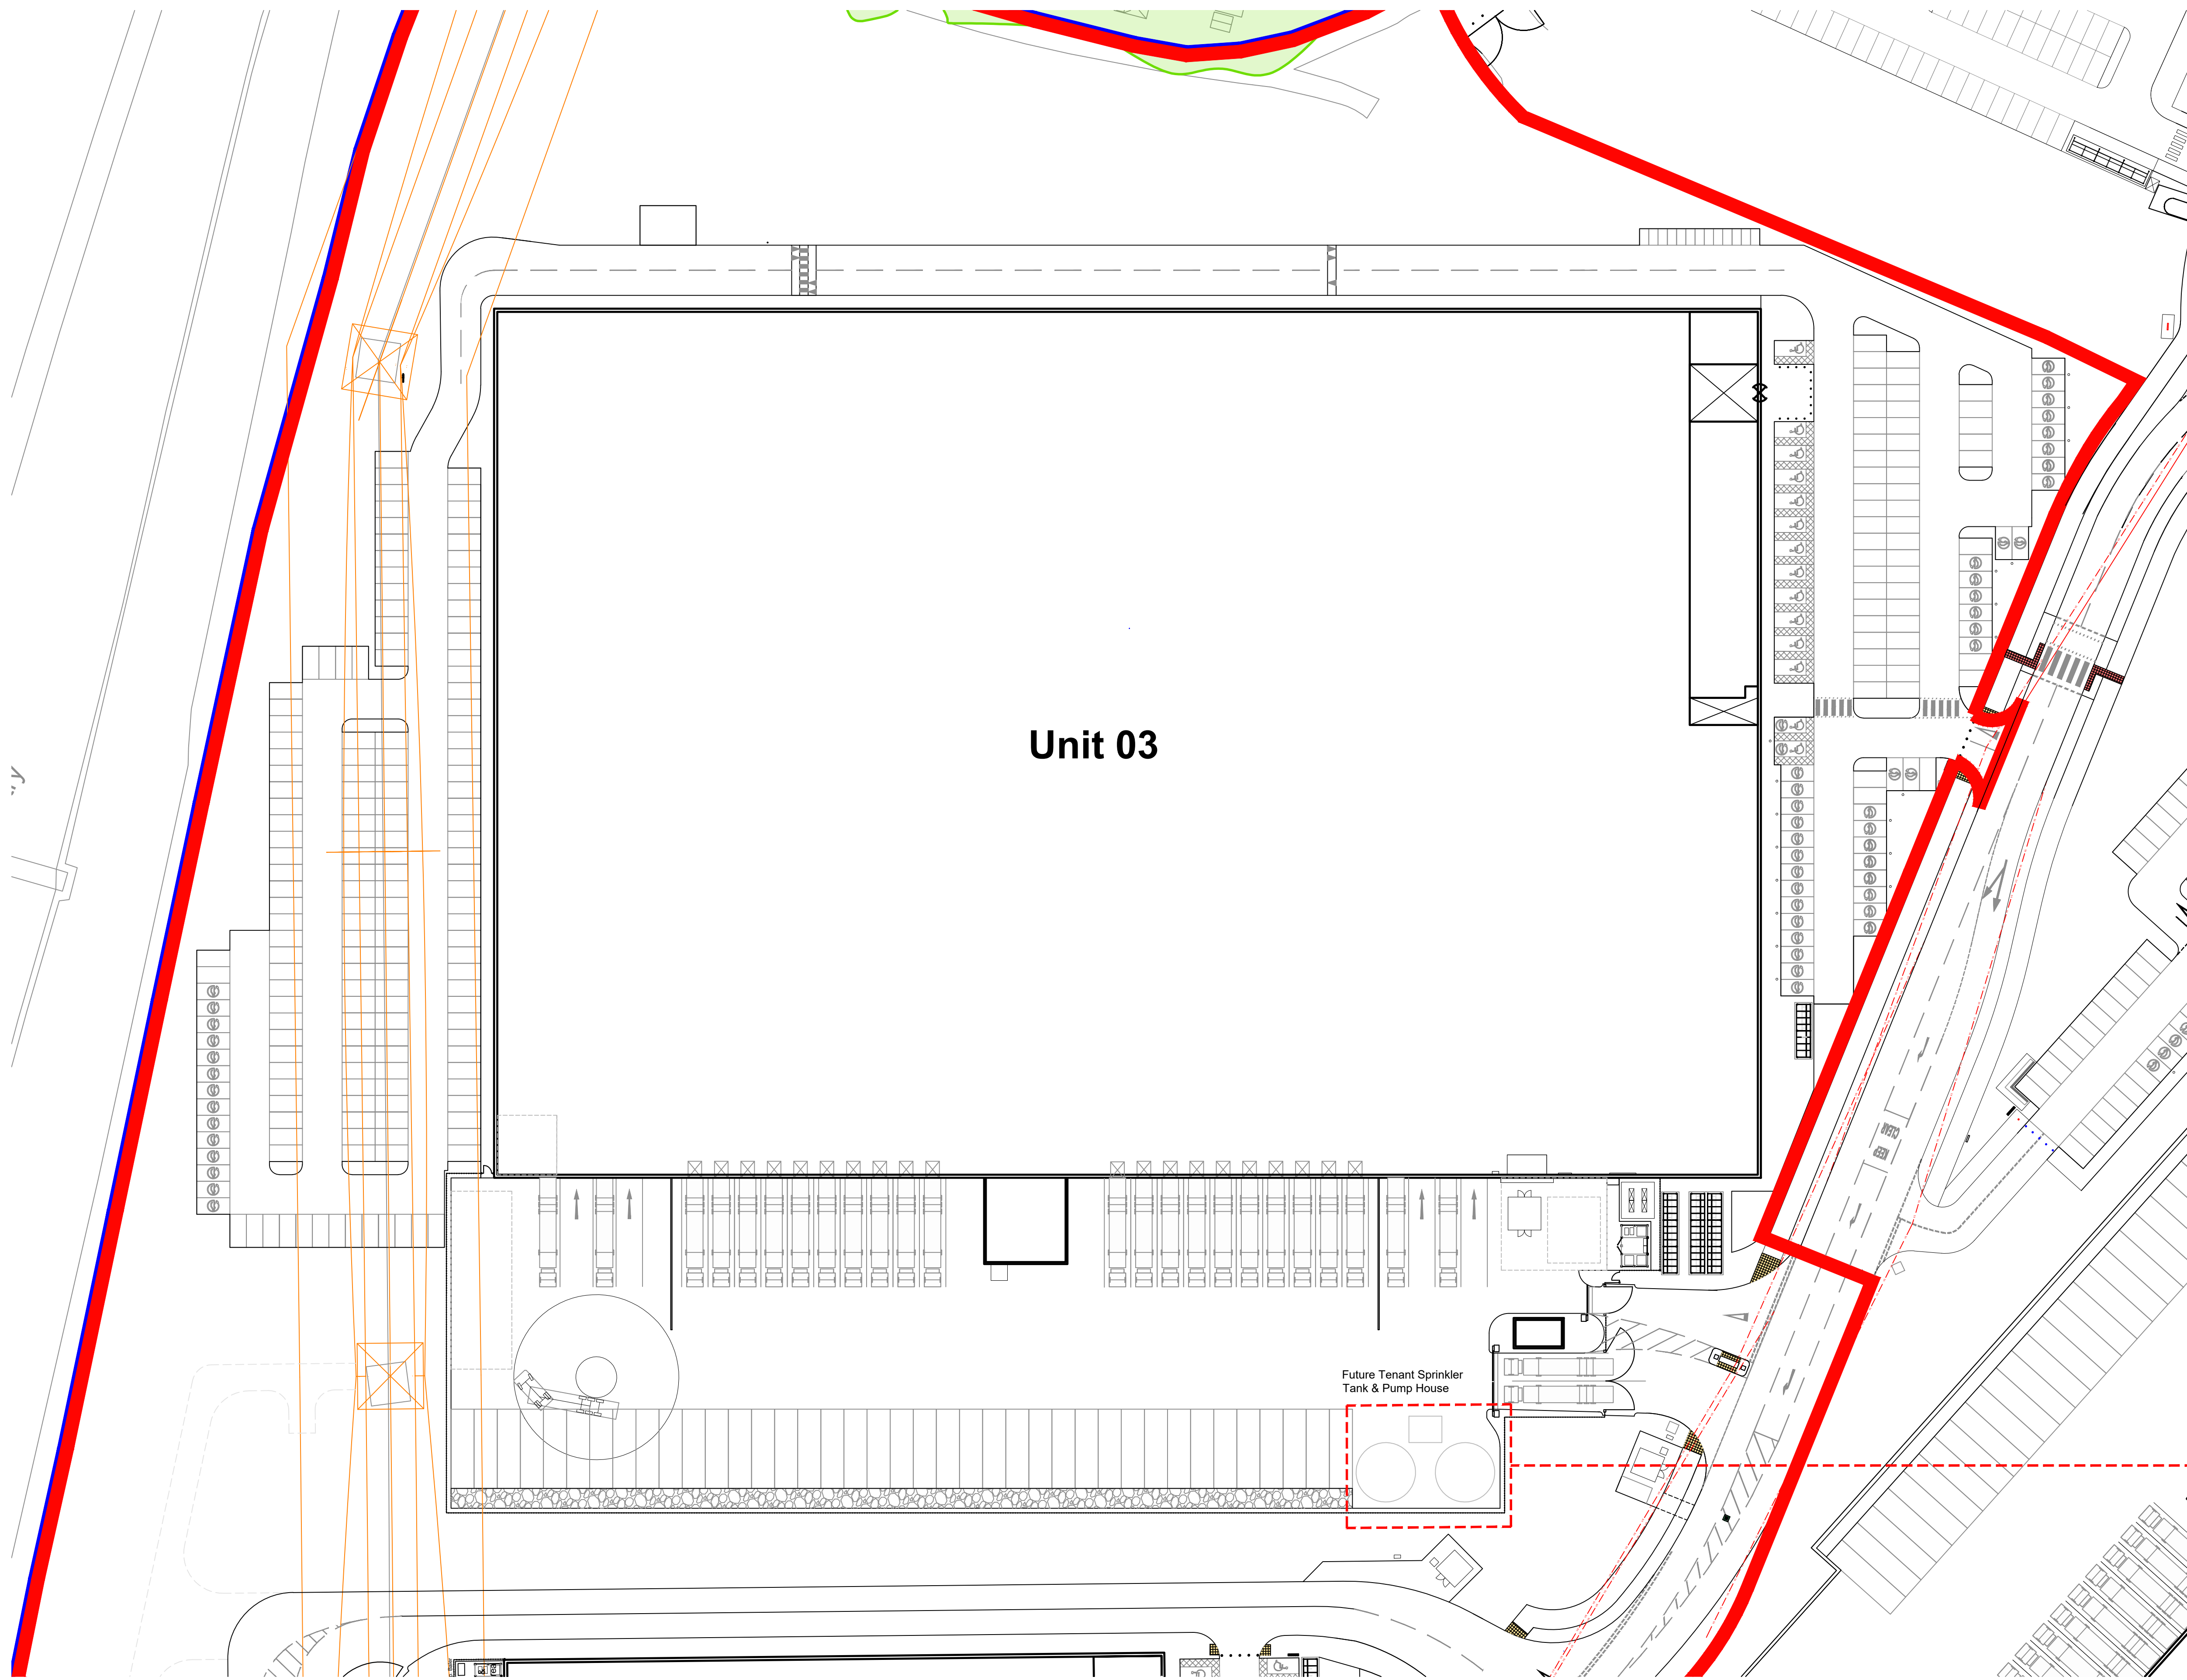
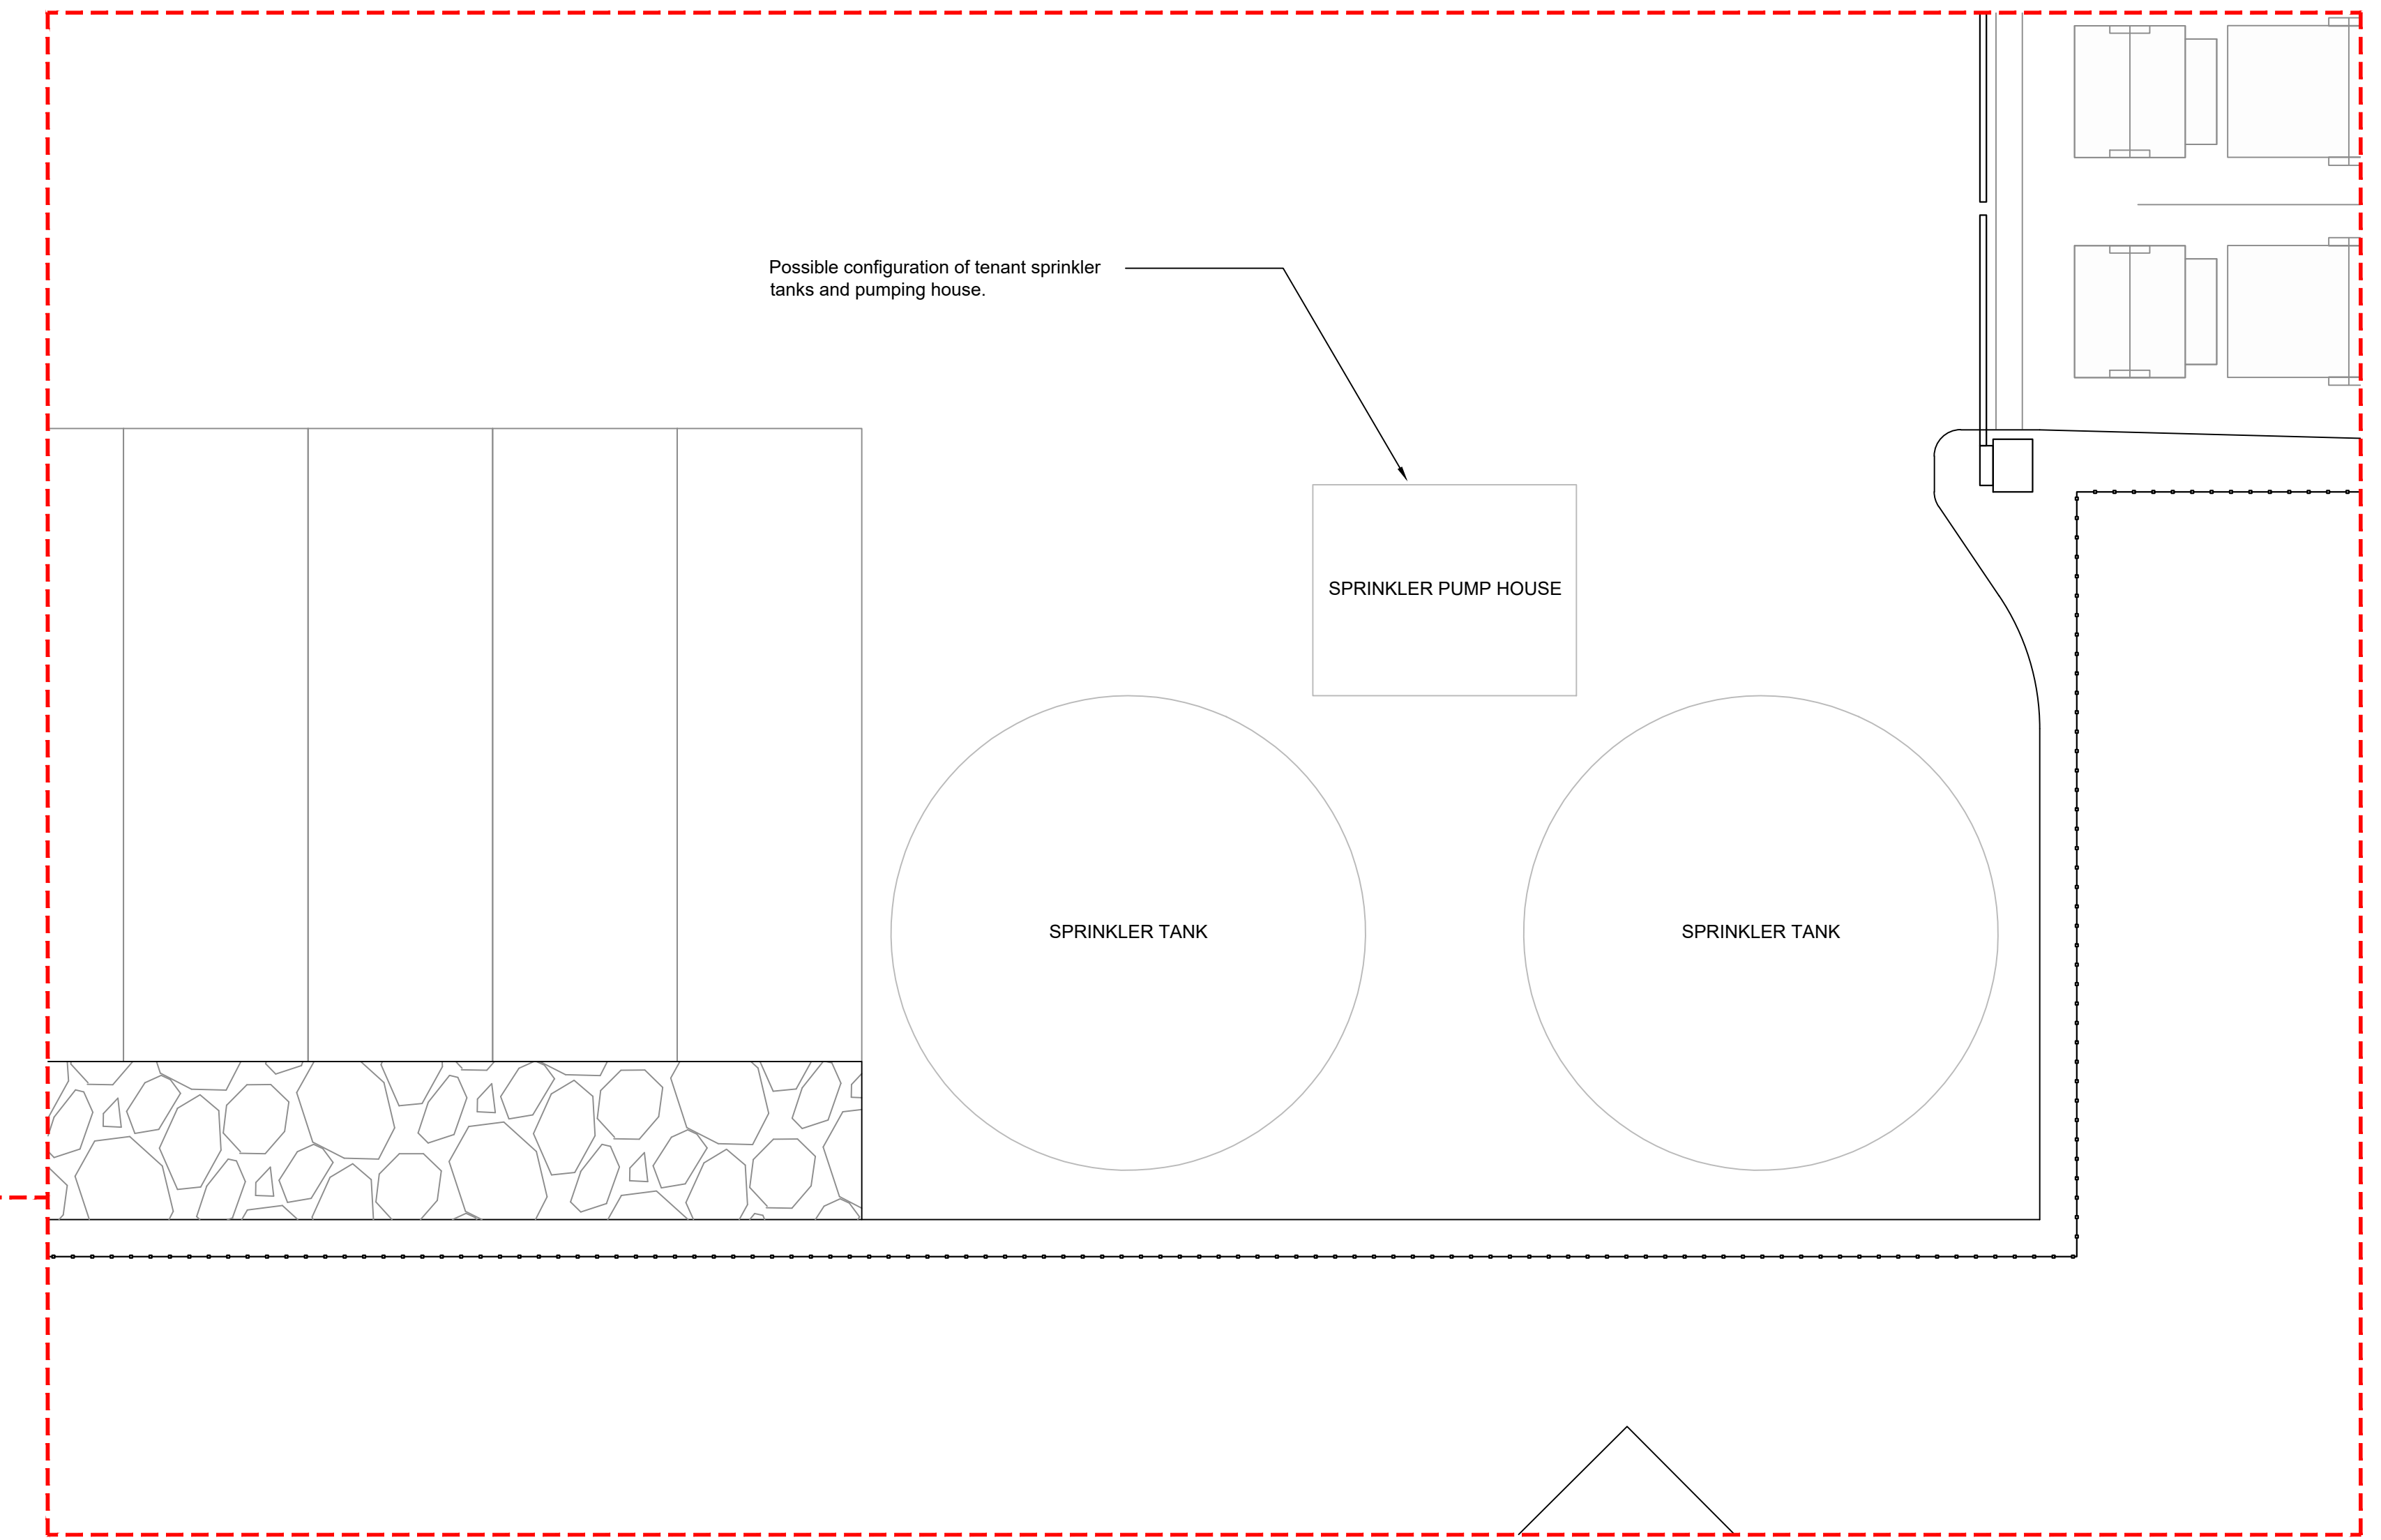


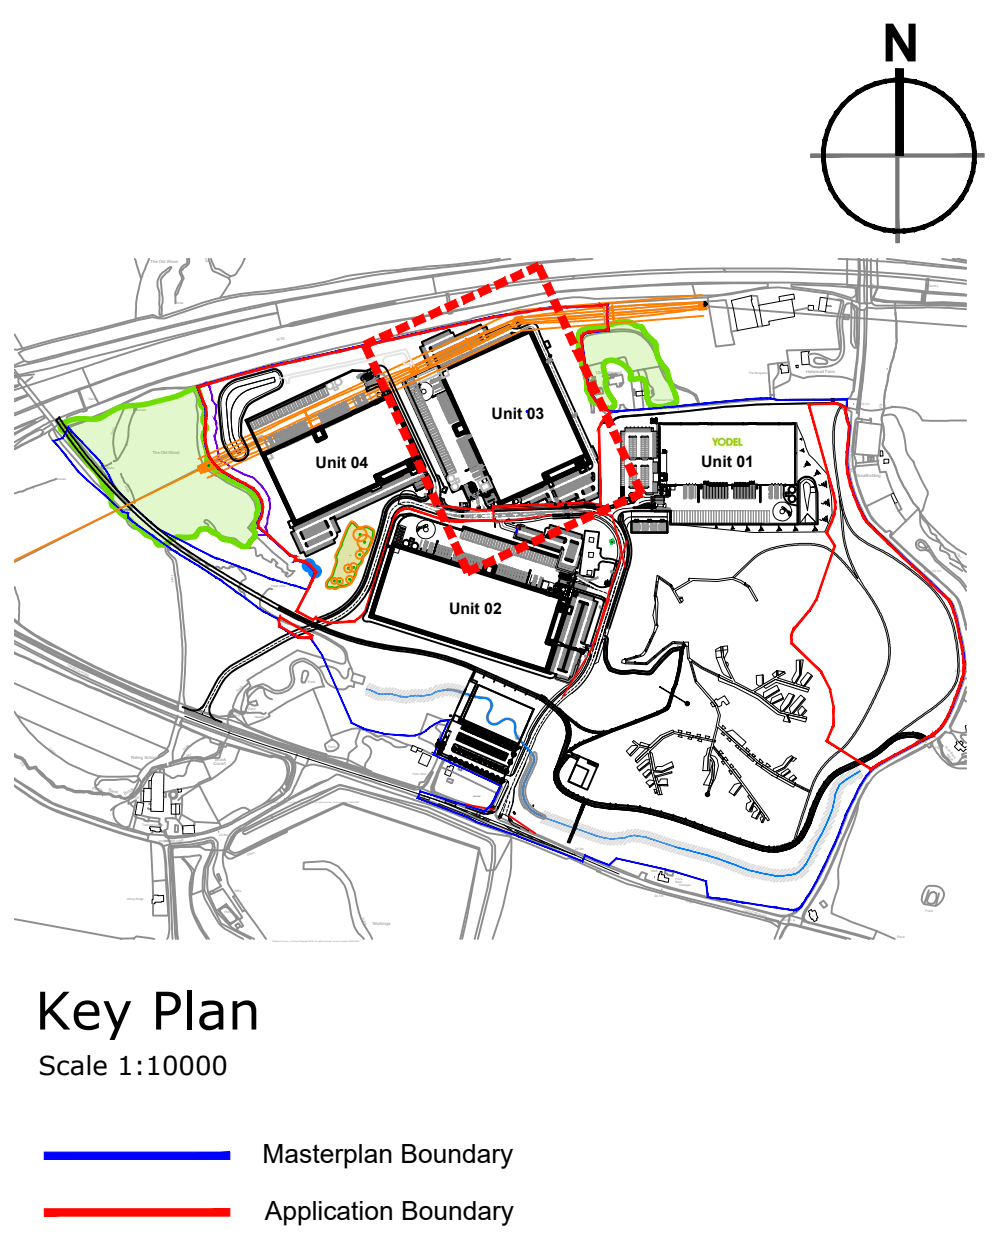


Unit 03 Site Plan
Scale 1:500

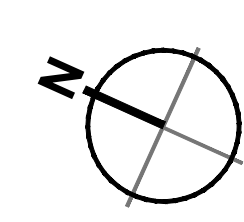

Potential Sprinkler Tank and Pump House Layout
Scale 1:100

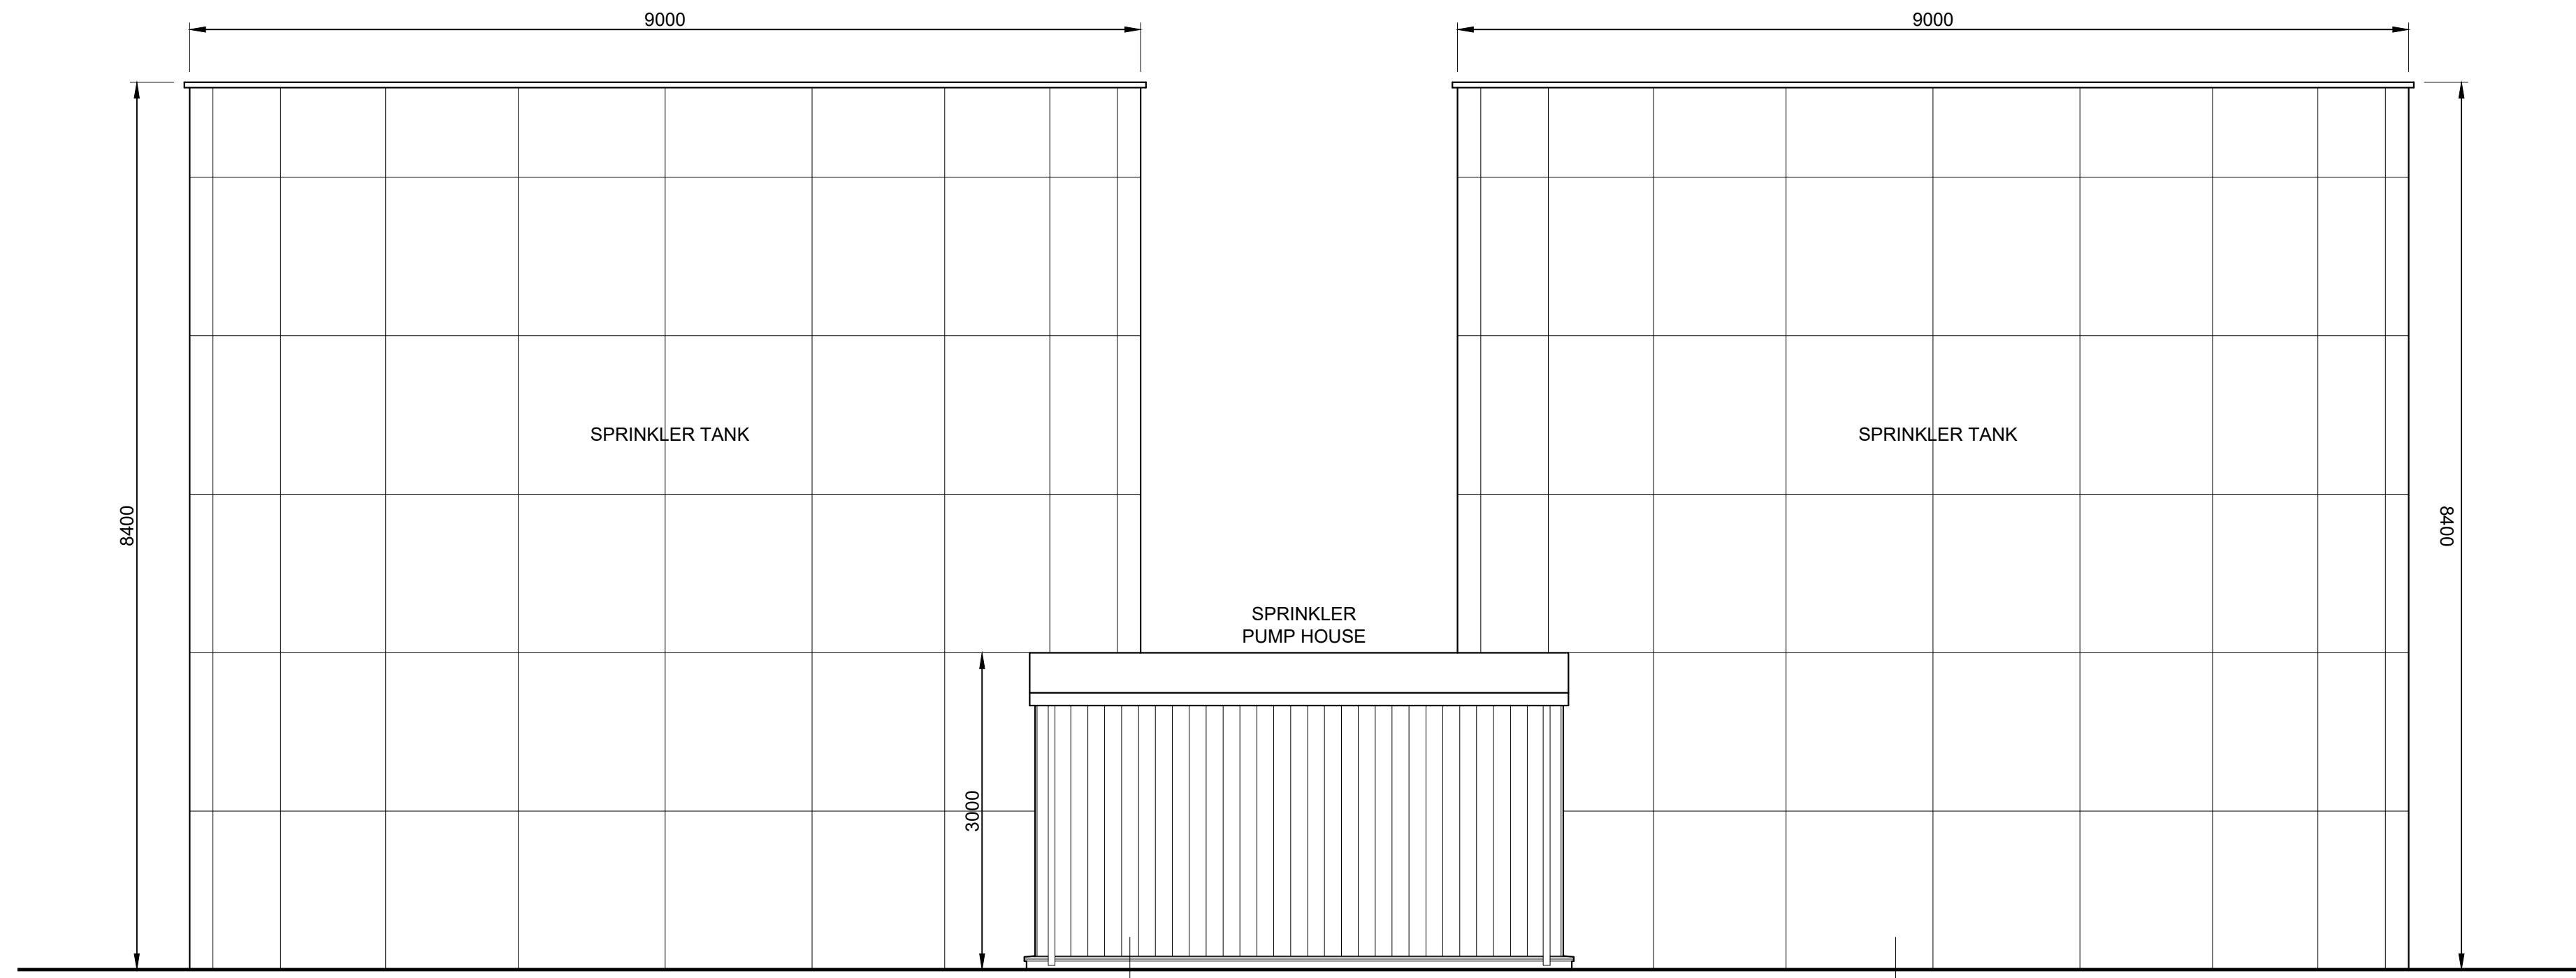


Sprinkler Tanks and Pump House Elevation
Scale 1:50

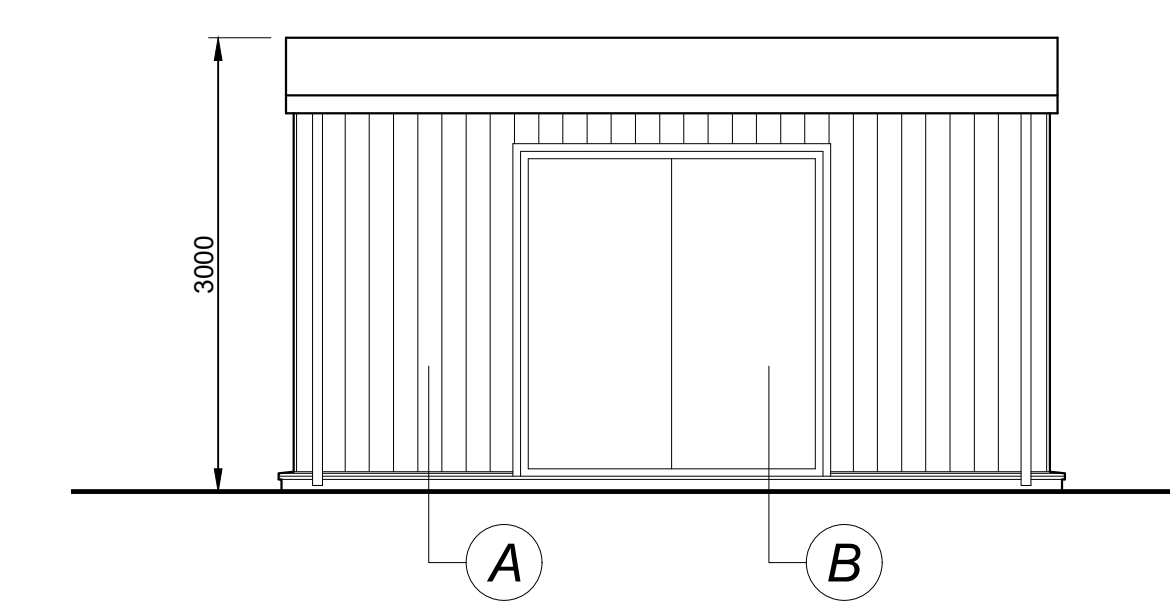

Pump House Elevation
Scale 1:50

- External Finishes
- A** Vertically laid
Profiled wall cladding system.
Finish: Tata Colorcoat HPS 200 Ultra.
Colour: Alaska Grey (RAL 7000)
 - B** Steel insulated personnel door & frame
Finish: Factory applied polyester powder
coat paint finish
Colour: Anthracite (RAL 7016)
 - C** Galvanised steel water storage tanks
Finish: Factory applied polyester powder
coat paint finish
Colour: Metallic Silver (RAL 9006)

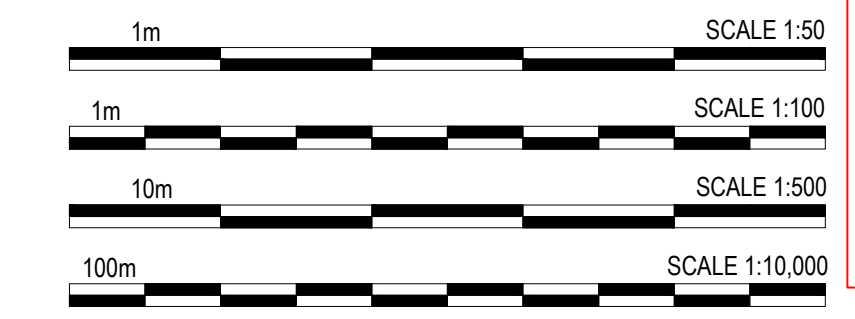

PLANNING