




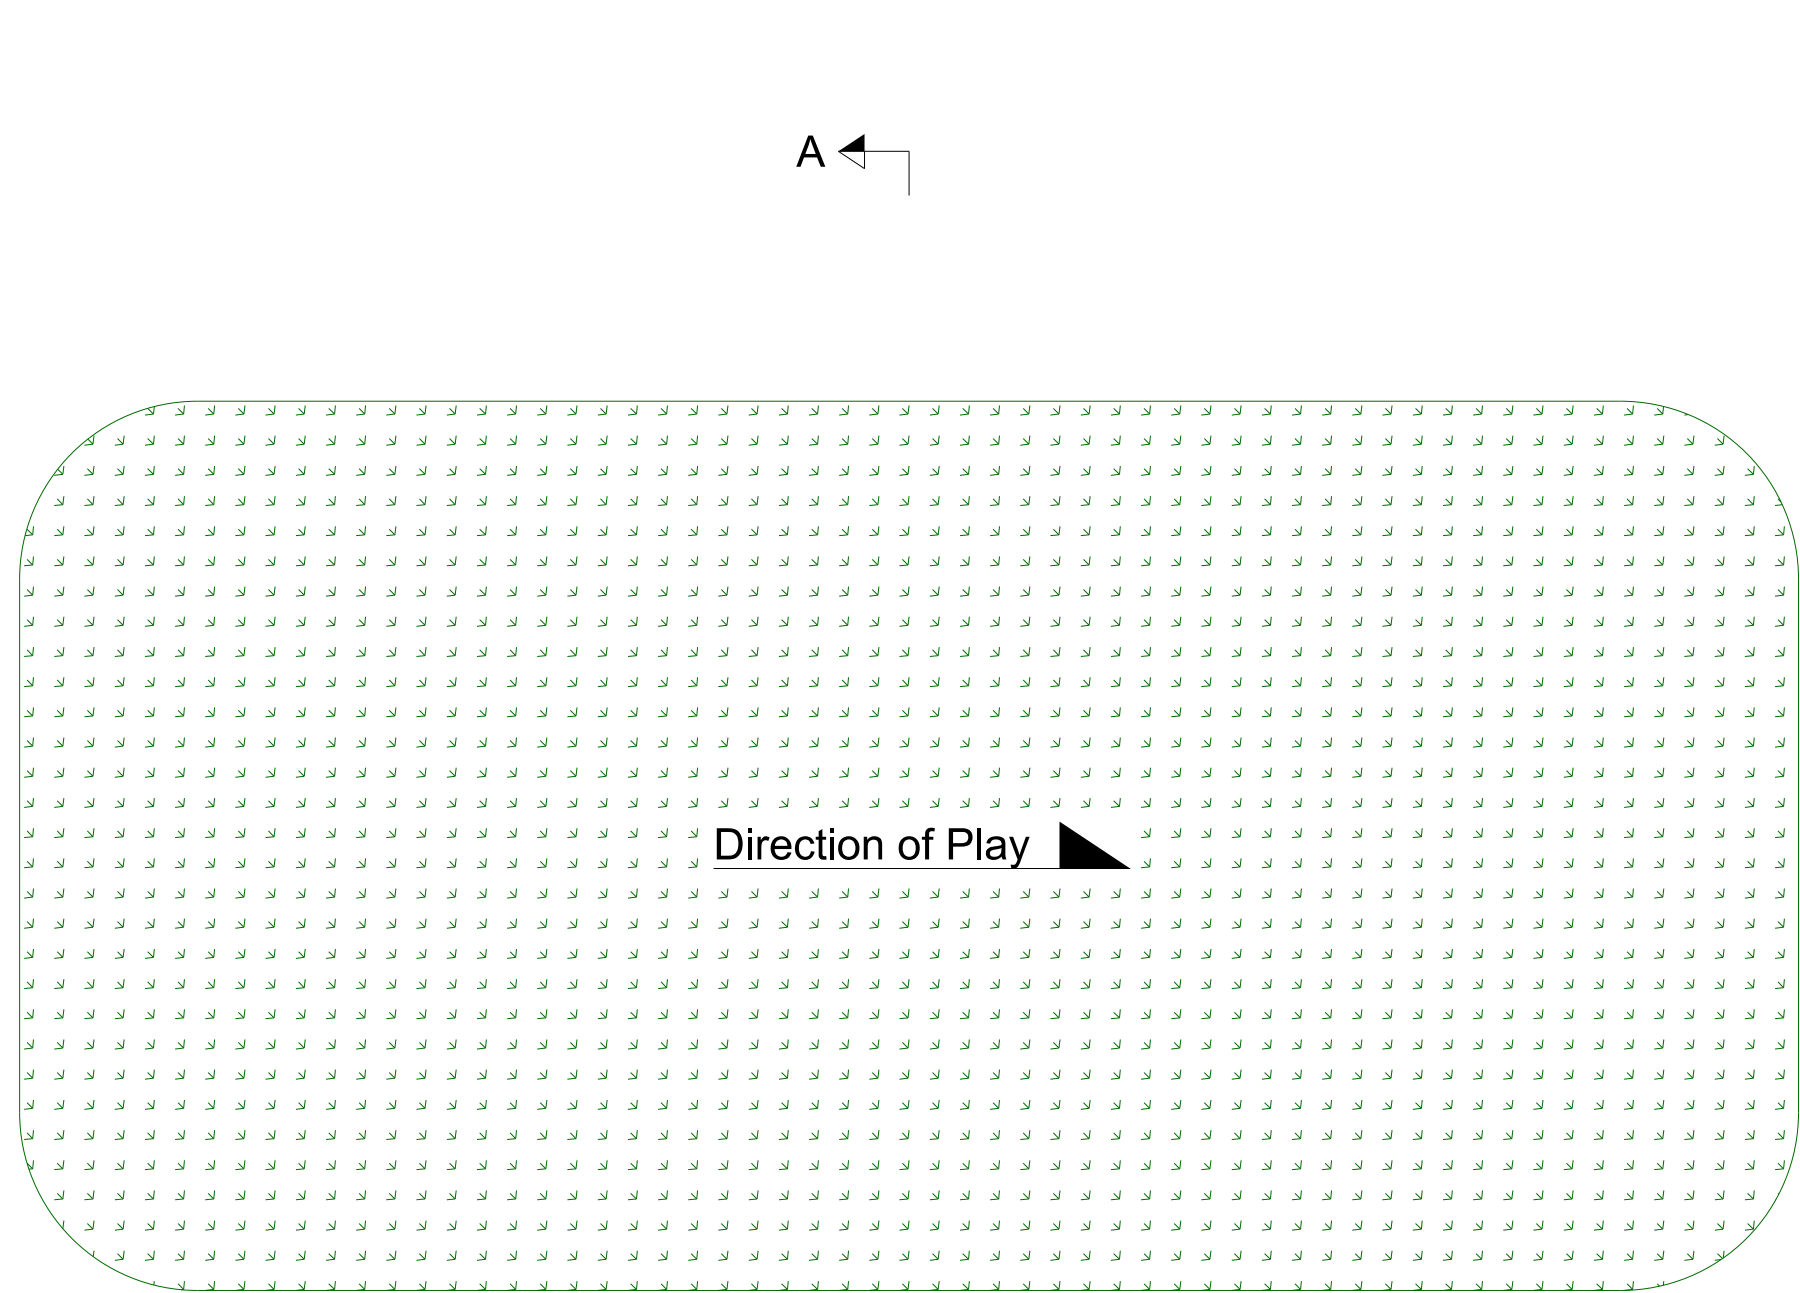


TL01 TYPICAL TEE LAYOUT

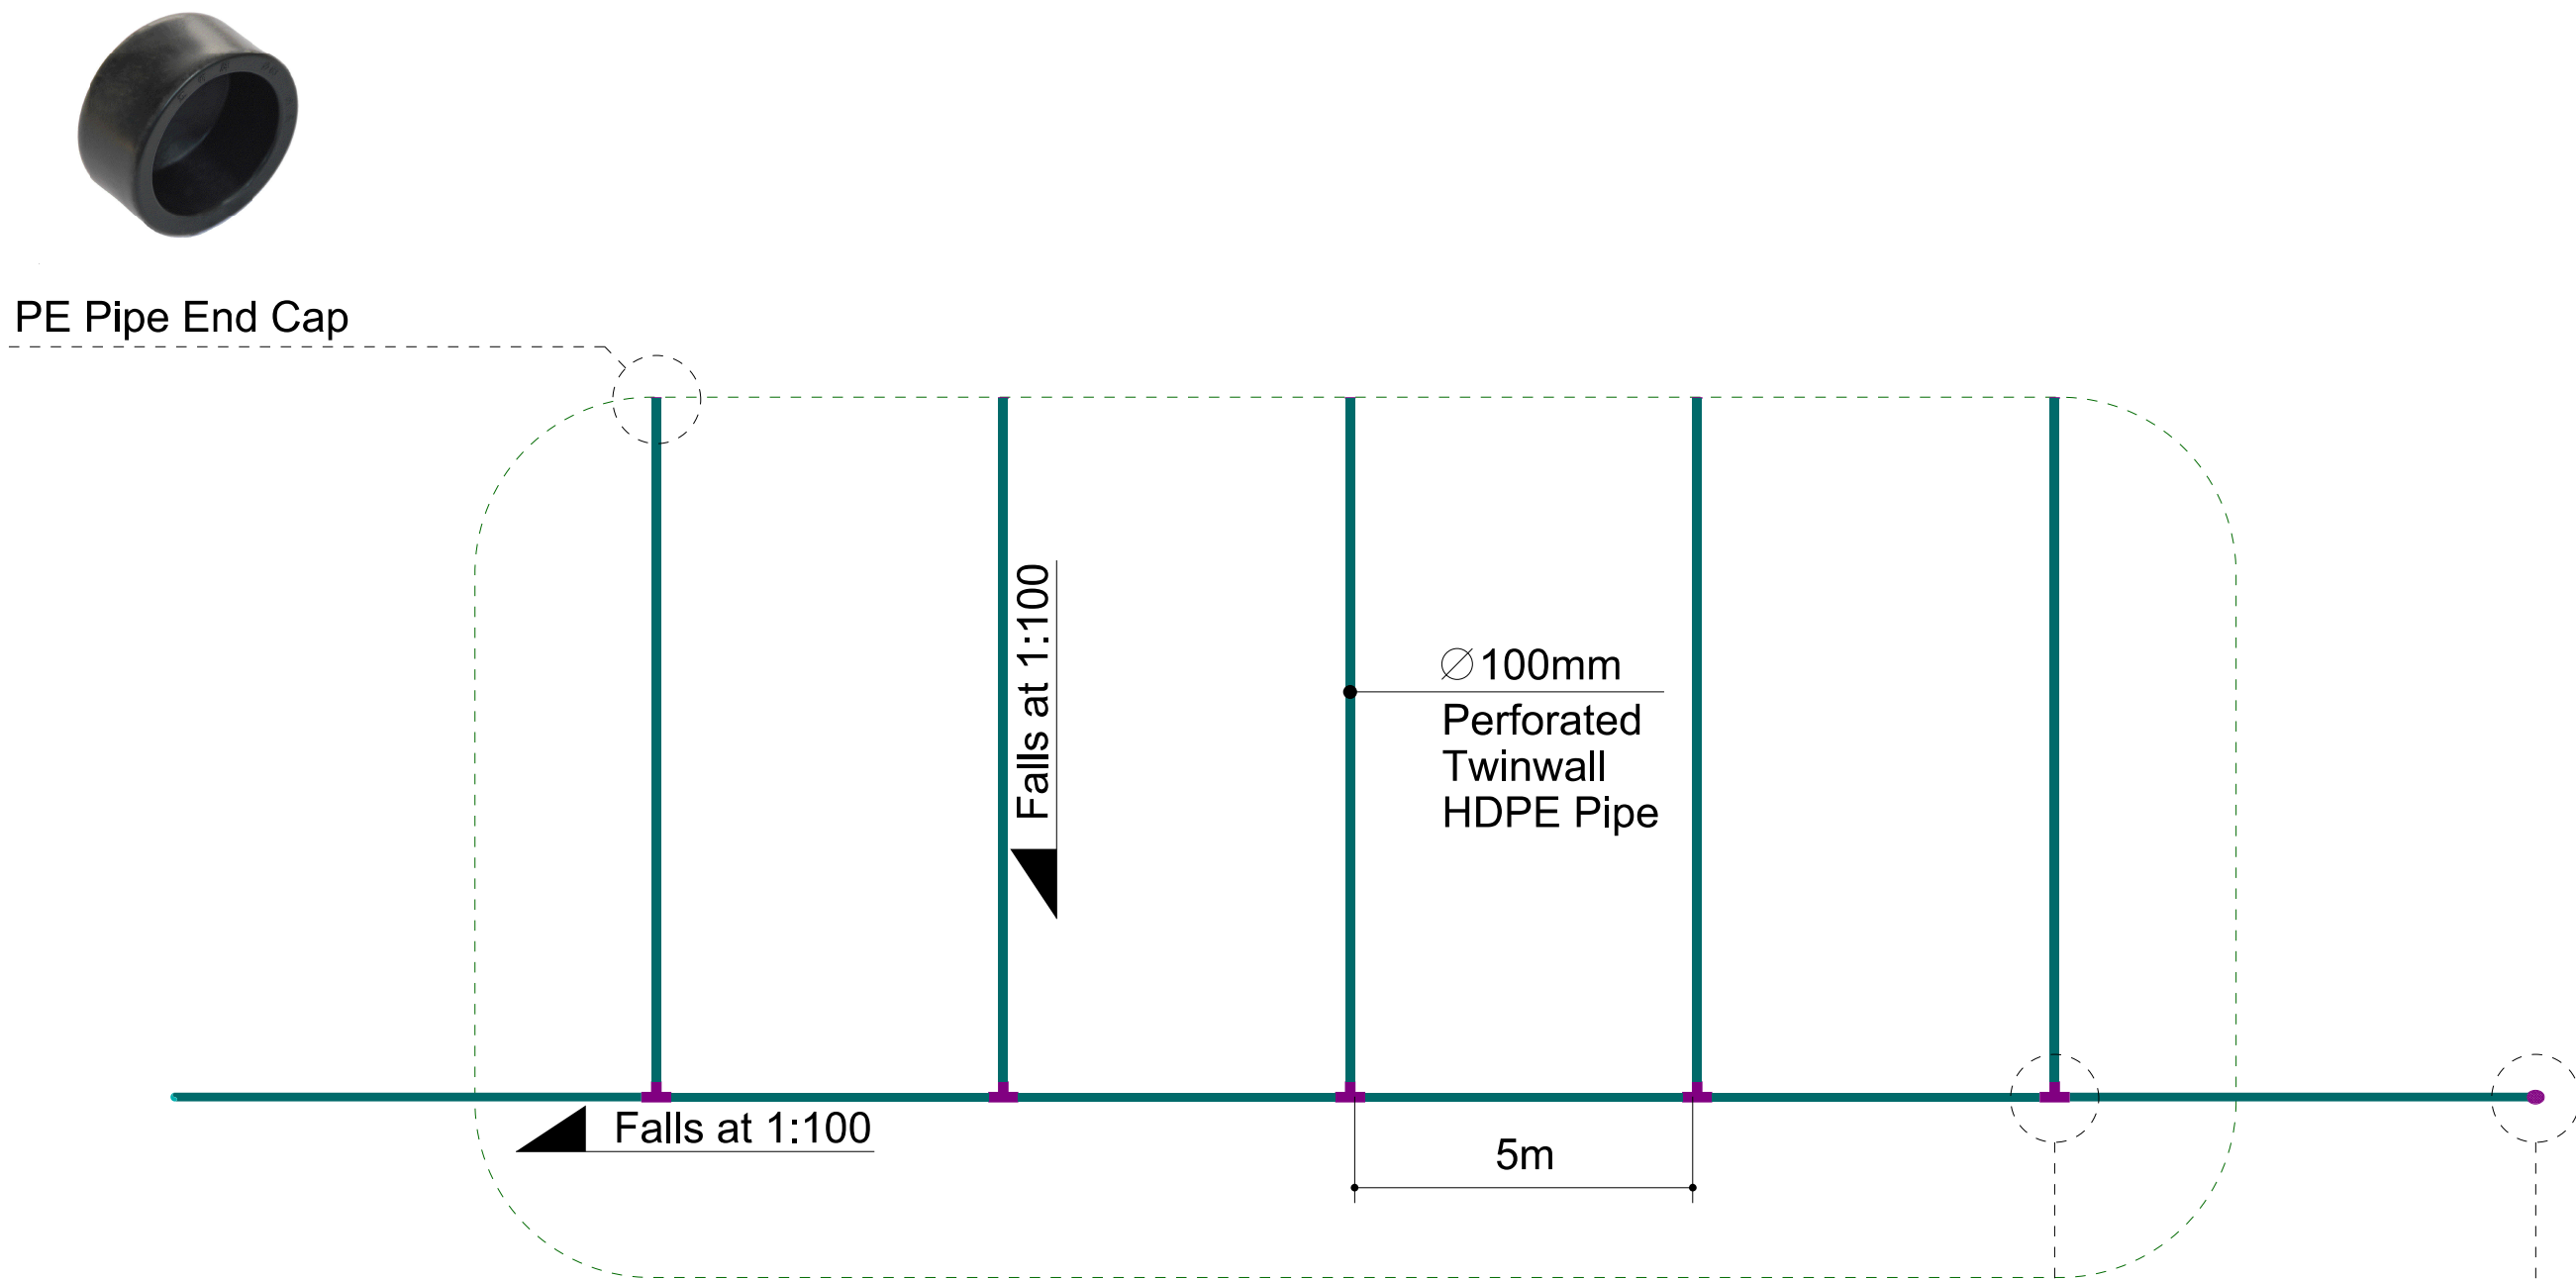


TD01 TYPICAL TEE DRAINAGE LAYOUT

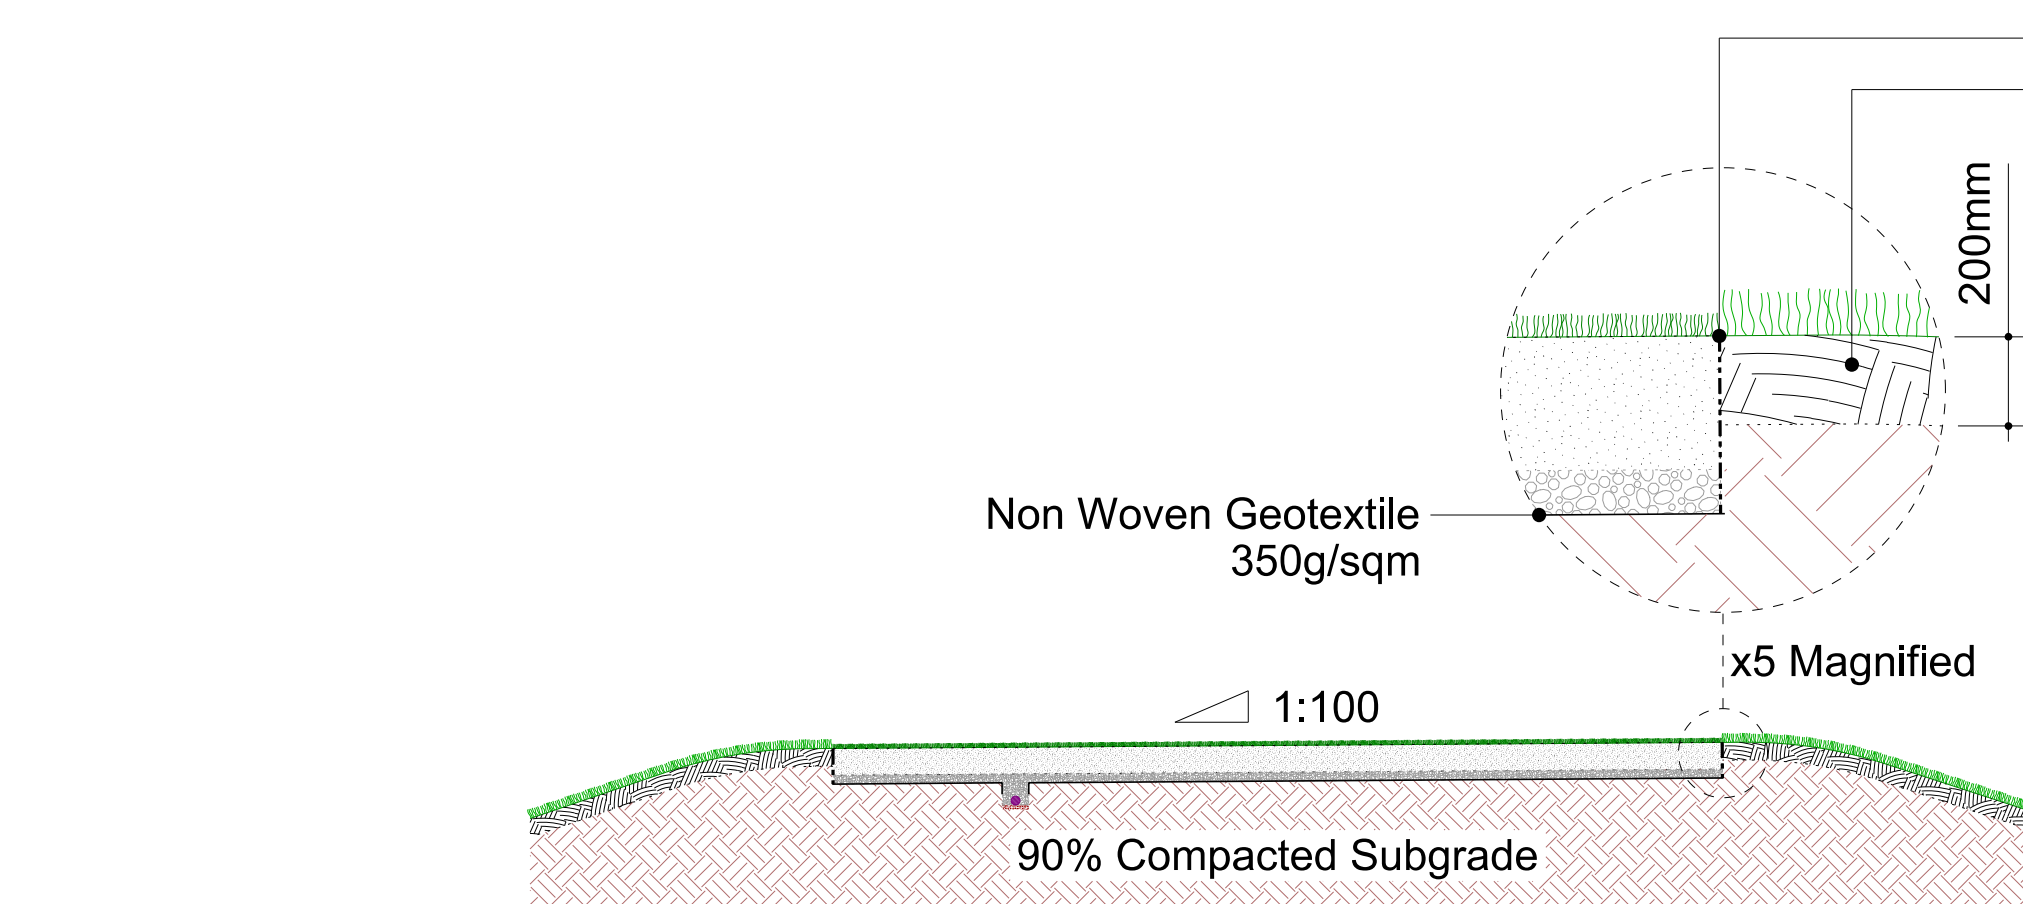

TS01 SECTION AA

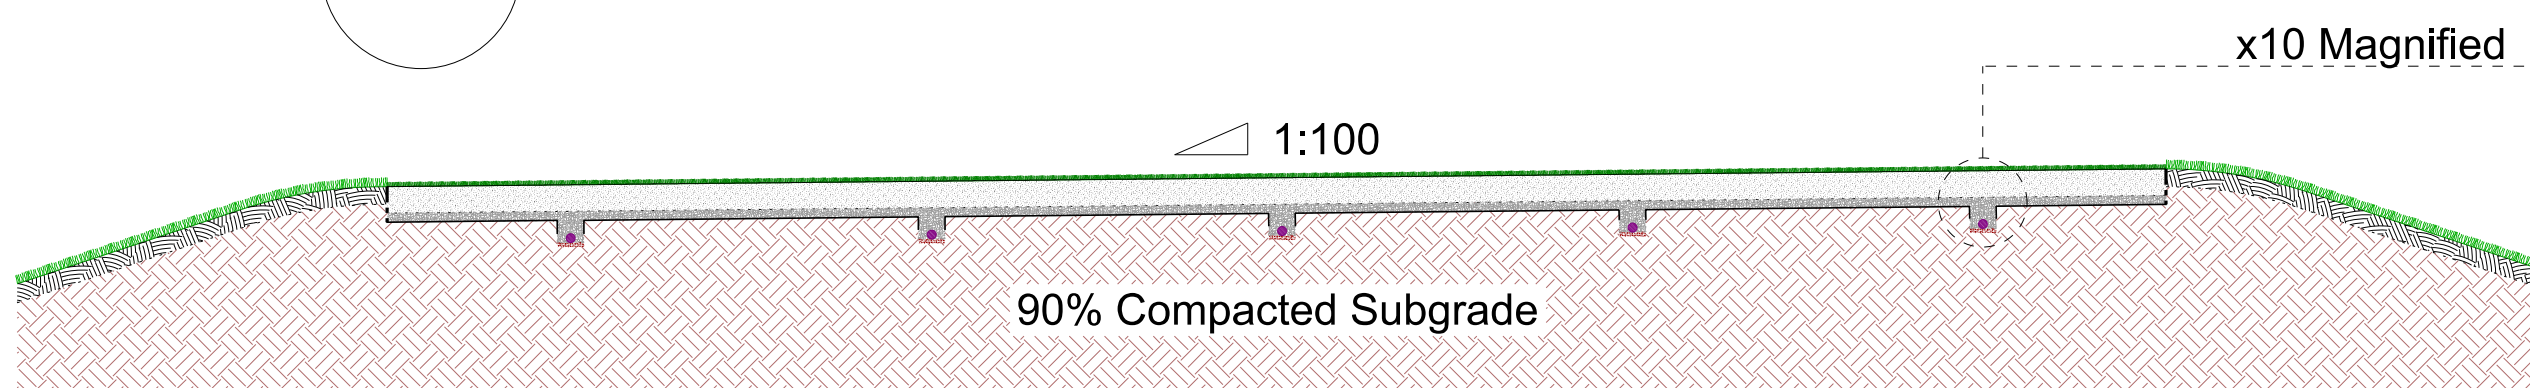

TS02 SECTION BB

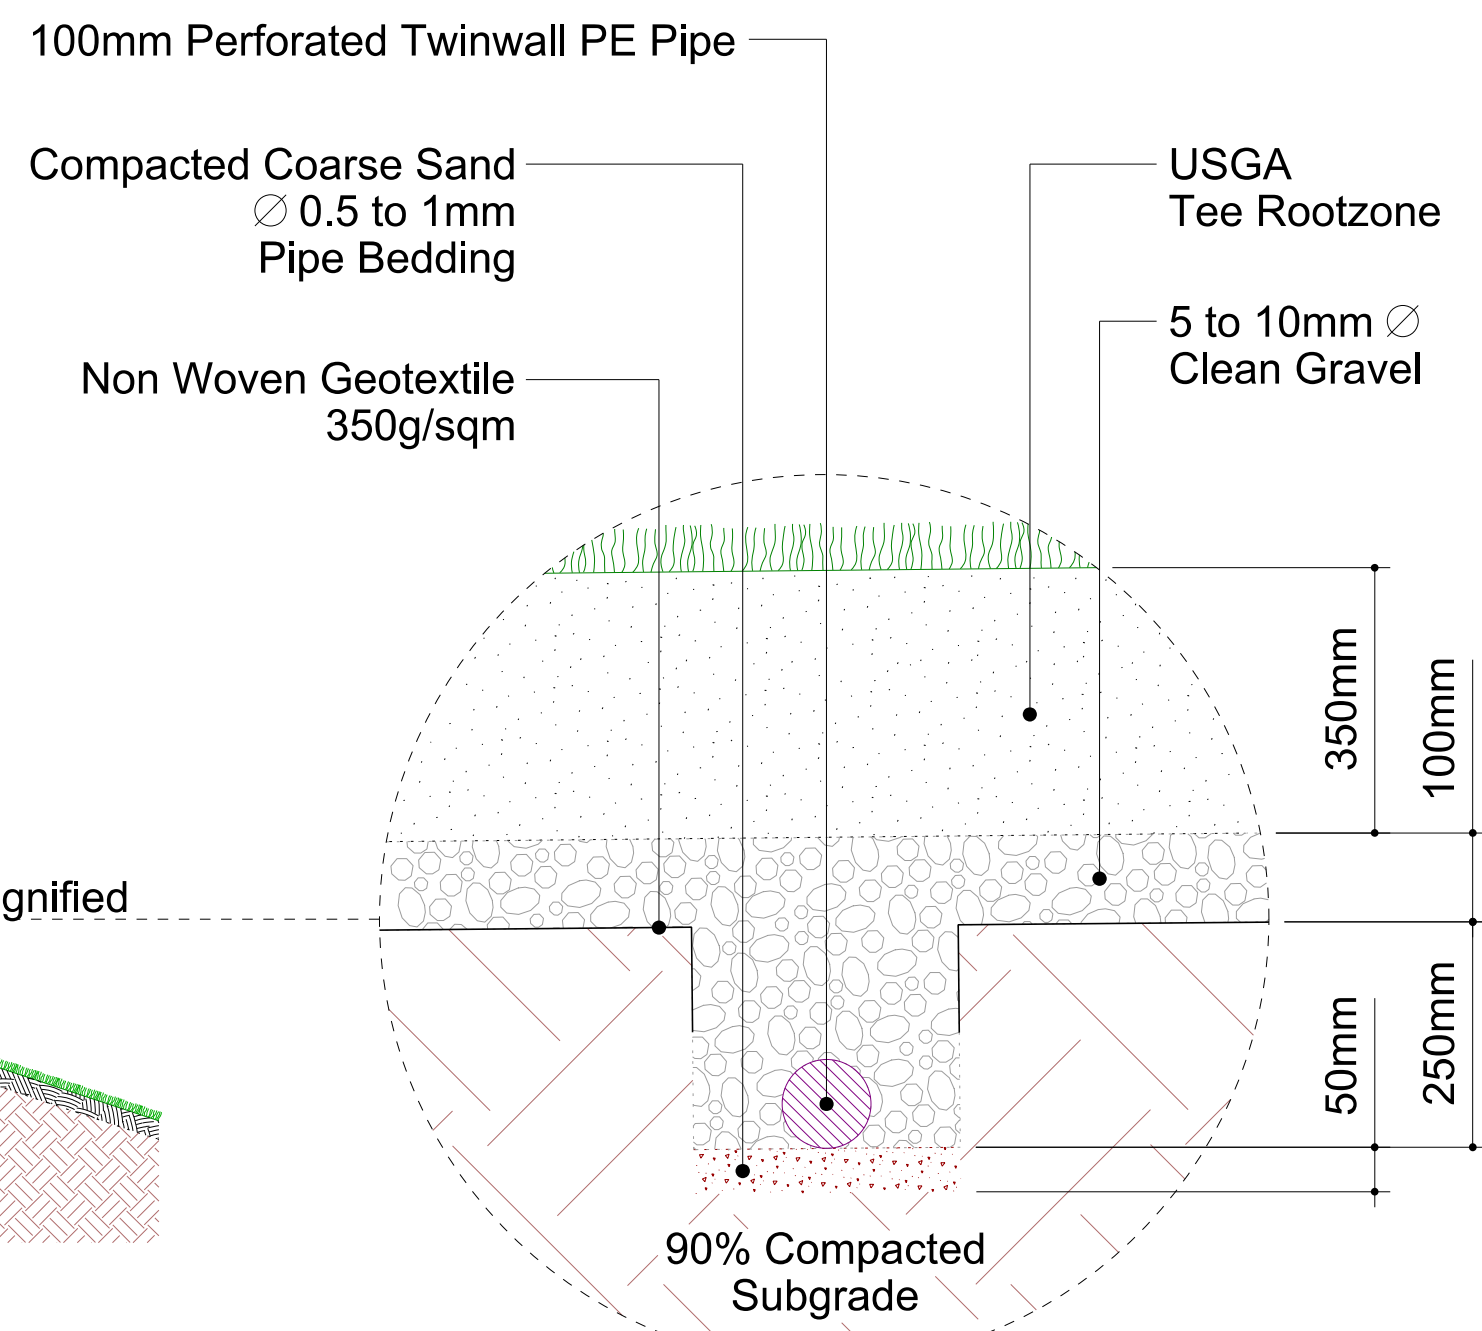

TD02 TEE DRAINAGE DETAIL



HDPE T-Coupler



Rodding Eye

GENERAL NOTES

- 01.
- 02.
- 03.
- 04.
- 05.

REVISIONS

REV	DATE	DESCRIPTION	REV BY	CHK BY
A	09/03/20	Amendments to Driving Range	PA	AC
B	22/06/21	Amendments to highways and site layout	SS	AC

KEY PLAN

CONSULTANT



LEAD CONSULTANT

CLIENT

ISSUED FOR

Planning Application
(90% submittal)

PROJECT

Kirkby Valley Golf Club

DRAWING TITLE

232 Tees Details

Drawn	PA	Checked	AC	Approved	--
Date	29.08.19	Sheet Size	A3	Scale	NTS
Drawing No. G935 232 TEES DETAILS				Rev.	B
CAD File No. G935 232			Consultant Project No.		

This drawing, the designs and details shown are the copyright of International Design Group and shall not be copied or reproduced in any form without their written consent.