


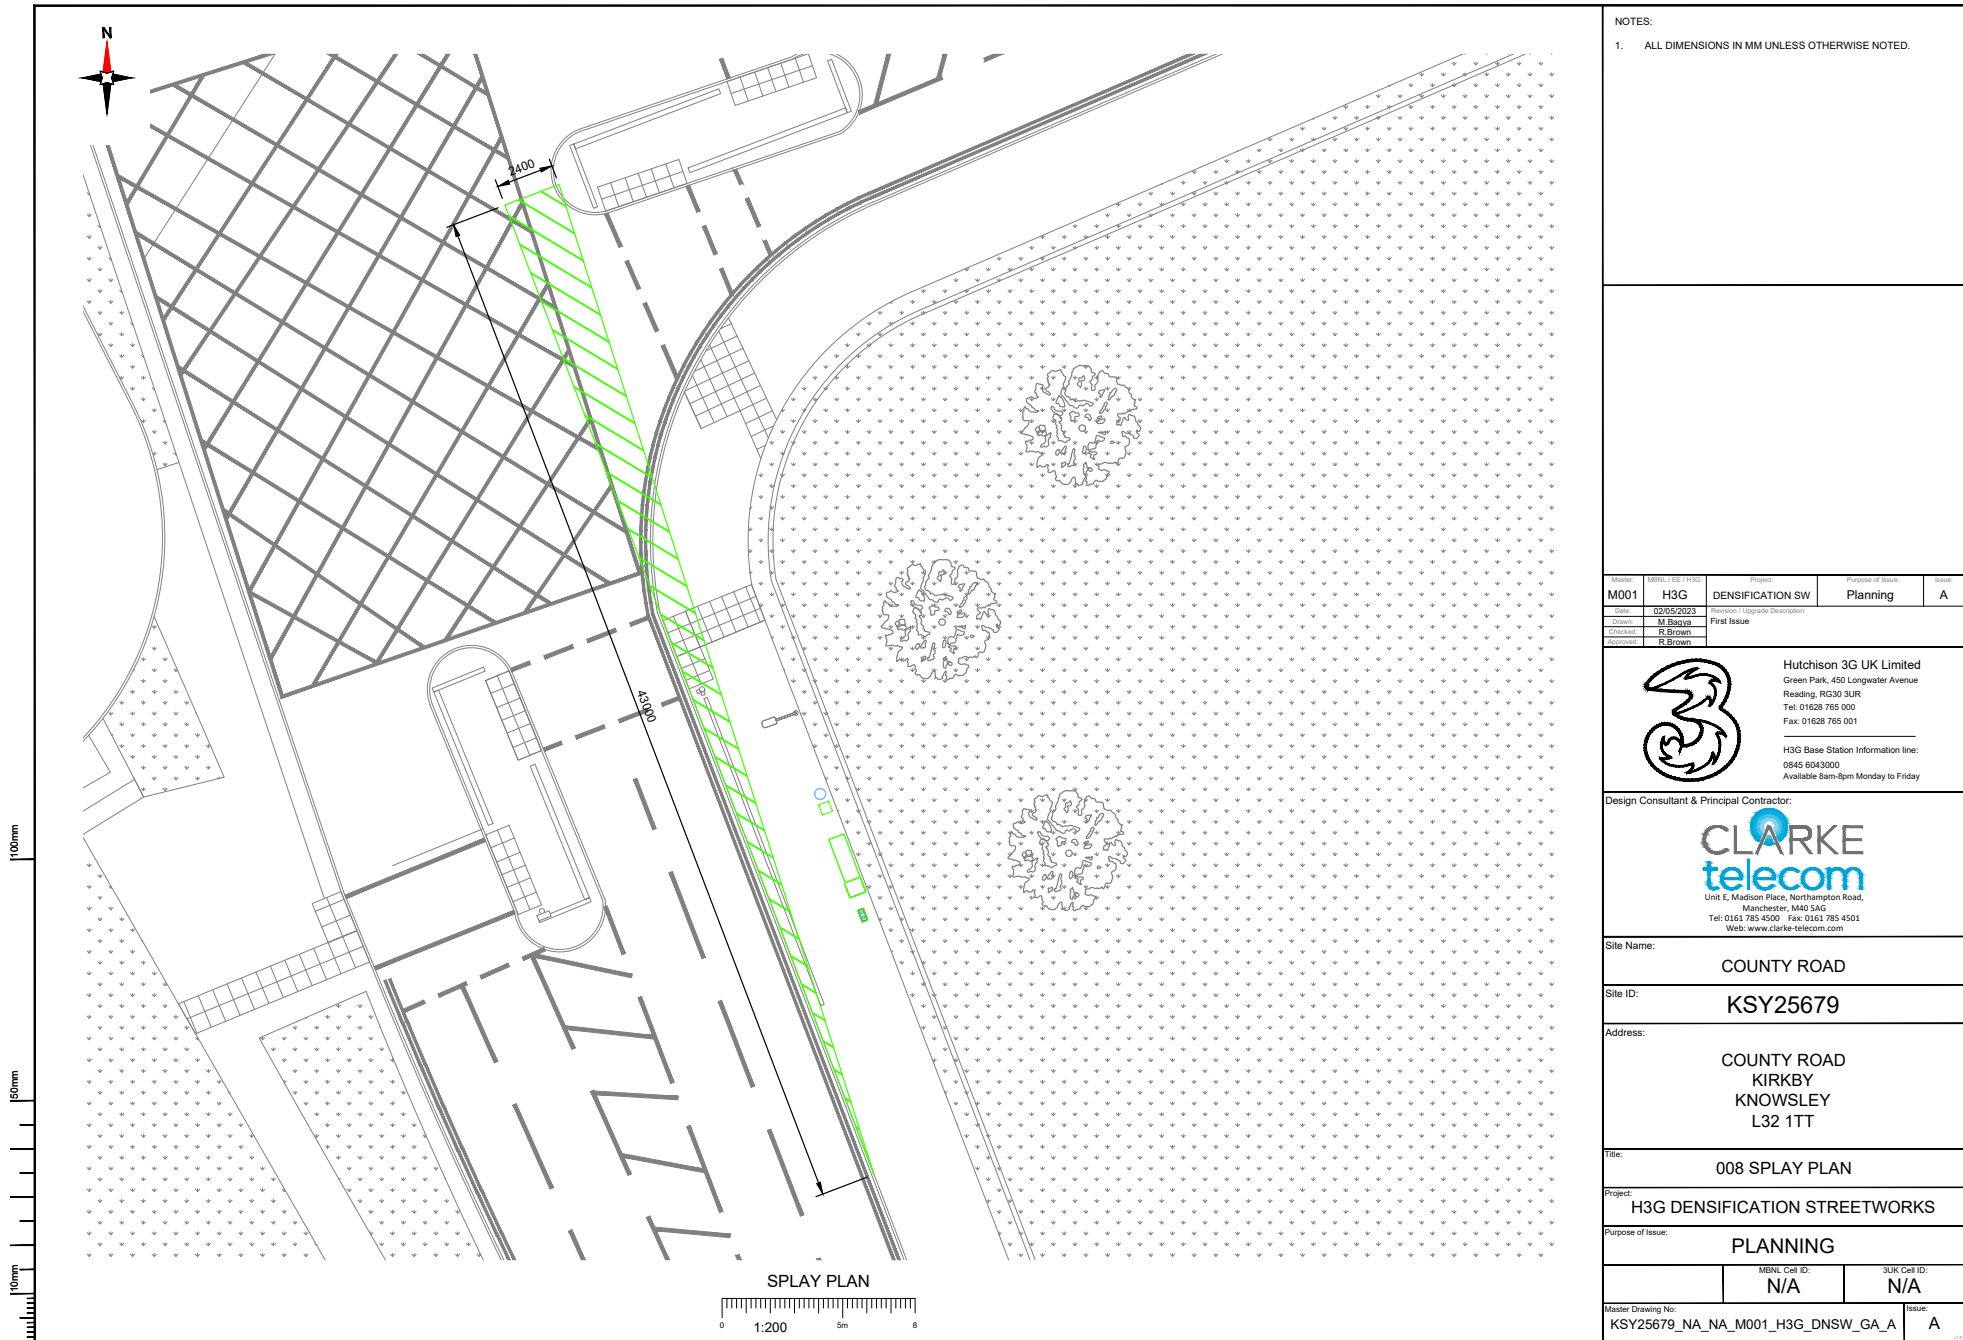

NOTES:

1. ALL DIMENSIONS IN MM UNLESS OTHERWISE NOTED.

Master	MBNL Cell ID:	Project	Purpose of Issue	Issue
M001	H3G	DENSIFICATION SW	Planning	A
Drawn	02/05/2023	Revision / Upgrade Description:		
Checked	M. Brown	First Issue		
Approved	R. Brown			



Hutchison 3G UK Limited
Green Park, 450 Longwater Avenue
Reading, RG30 3UR
Tel: 01628 765 000
Fax: 01628 765 001

H3G Base Station Information line:
0845 6043000
Available 8am-8pm Monday to Friday

Design Consultant & Principal Contractor:



Site Name:

COUNTY ROAD

Site ID:

KSY25679

Address:

COUNTY ROAD
KIRKBY
KNOWSLEY
L32 1TT

Title:

008 SPLAY PLAN


Project:

H3G DENSIFICATION STREETWORKS

Purpose of Issue:

PLANNING


Master Drawing No:	MBNL Cell ID:	3UK Cell ID:	Issue:
KSY25679_NA_NA_M001_H3G_DNSW_GA_A	N/A	N/A	A

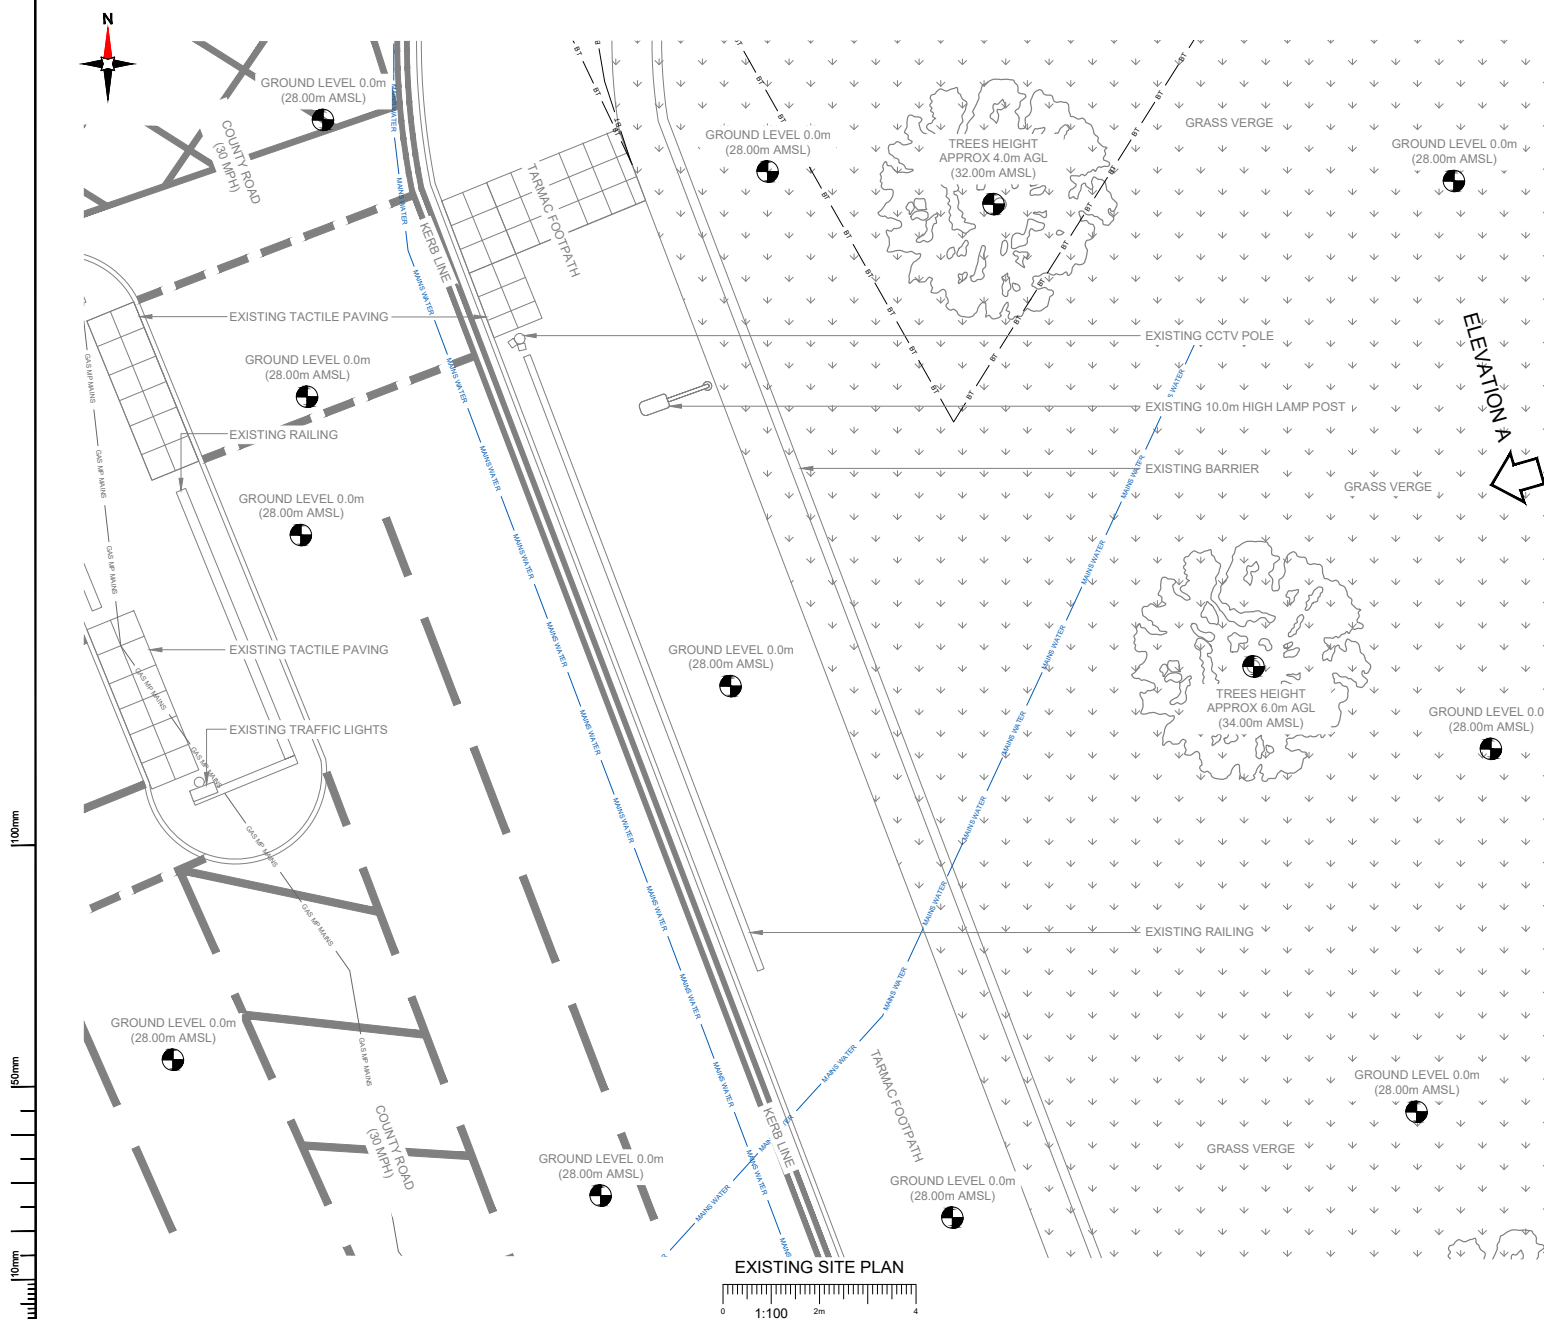

NOTES:

1. ALL DIMENSIONS IN MM UNLESS OTHERWISE NOTED.

SERVICES:

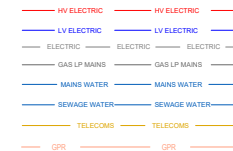

Project	Client	Project Name	Project Number	Issue
M001	H3G	DENSIFICATION SW	Planning	A
Date:	02/05/2023	Revision/Change Description:	First Issue	
Drawn:	M. Brown	Checked:	R. Brown	Approved:



Hutchison 3G UK Limited
 Green Park, 450 Longwater Avenue
 Reading, RG30 3UR
 Tel: 01628 785 000
 Fax: 01628 785 001
 H3G Base Station Information line:
 0845 6043000
 Available 8am-8pm Monday to Friday

Design Consultant & Principal Contractor:




Site Name:	COUNTY ROAD		
Site ID:	KS25679		
Address:	COUNTY ROAD KIRKBY KNOWSLEY L32 1TT		
Title:	100 EXISTING SITE PLAN		
Project:	H3G DENSIFICATION STREETWORKS		
Purpose of Issue:	PLANNING		
MBNL Cell ID:	N/A	3UK Cell ID:	N/A
Master Drawing No:	KS25679_NA_NA_M001_H3G_DNSW_GA_A		Issue:
		A	

100mm

50mm

10mm

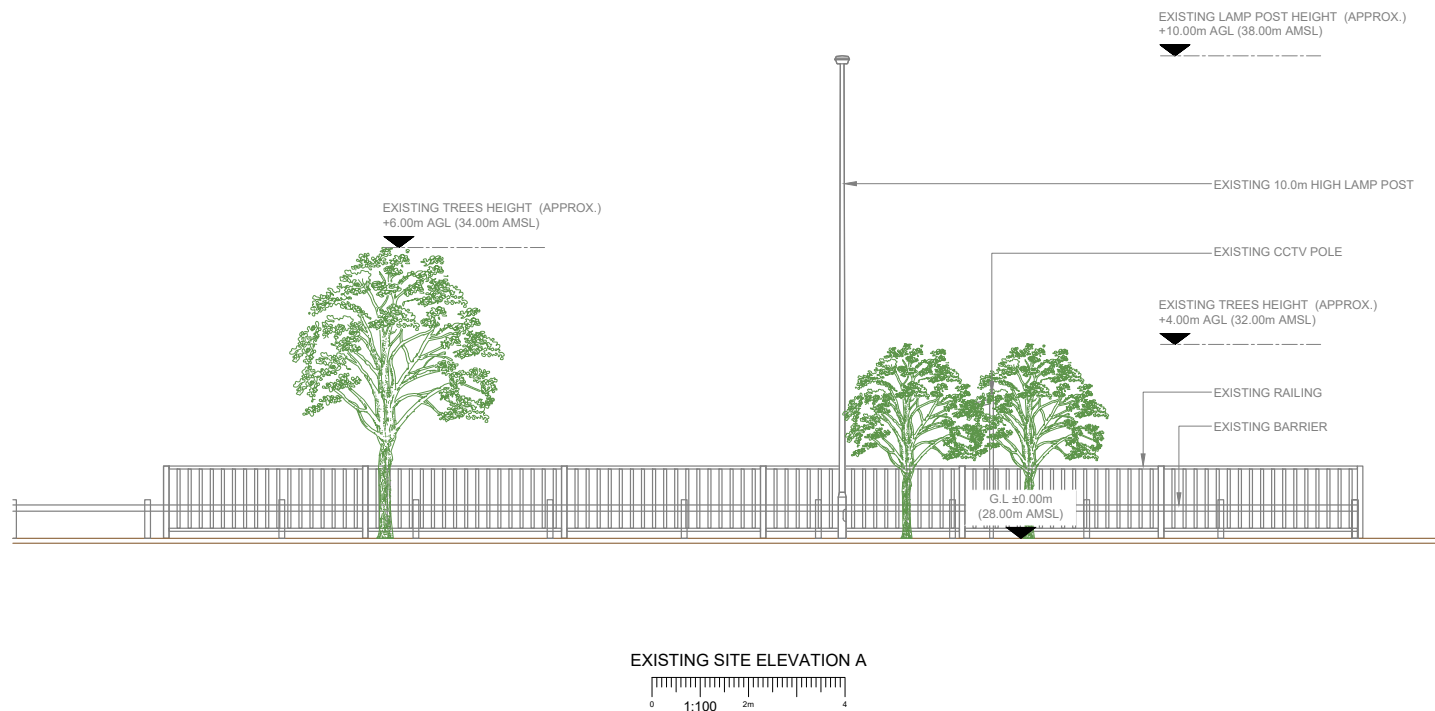

NOTES:

- ALL DIMENSIONS IN MM UNLESS OTHERWISE NOTED.

Sheet	MBNL Cell ID	Project	Purpose of Issue	Issue
M001	H3G	DENSIFICATION SW	Planning	A
Date	02/05/2023	Revision / Change Description:		
Drawn	M. Baya	First Issue		
Checked	R. Brown			
Approved	R. Brown			



Hutchison 3G UK Limited
Green Park, 450 Longwater Avenue
Reading, RG30 3UR
Tel: 01628 785 000
Fax: 01628 785 001

H3G Base Station Information line:
0845 6043000
Available 8am-8pm Monday to Friday

Design Consultant & Principal Contractor:

CLARKE
telecom
Unit E, Madison Place, Northampton Road,
Manchester, M40 5AG
Tel: 0161 785 4500 Fax: 0161 785 4501
Web: www.clarke-telecom.com

Site Name:

COUNTY ROAD

Site ID:

KSY25679

Address:

COUNTY ROAD
KIRKBY
KNOWSLEY
L32 1TT

Title:

150 EXISTING SITE ELEVATION A

Project:

H3G DENSIFICATION STREETWORKS

Purpose of Issue:

PLANNING


MBNL Cell ID:	3UK Cell ID:
N/A	N/A

Master Drawing No:

KSY25679_NA_NA_M001_H3G_DNSW_GA_A

Issue:

A

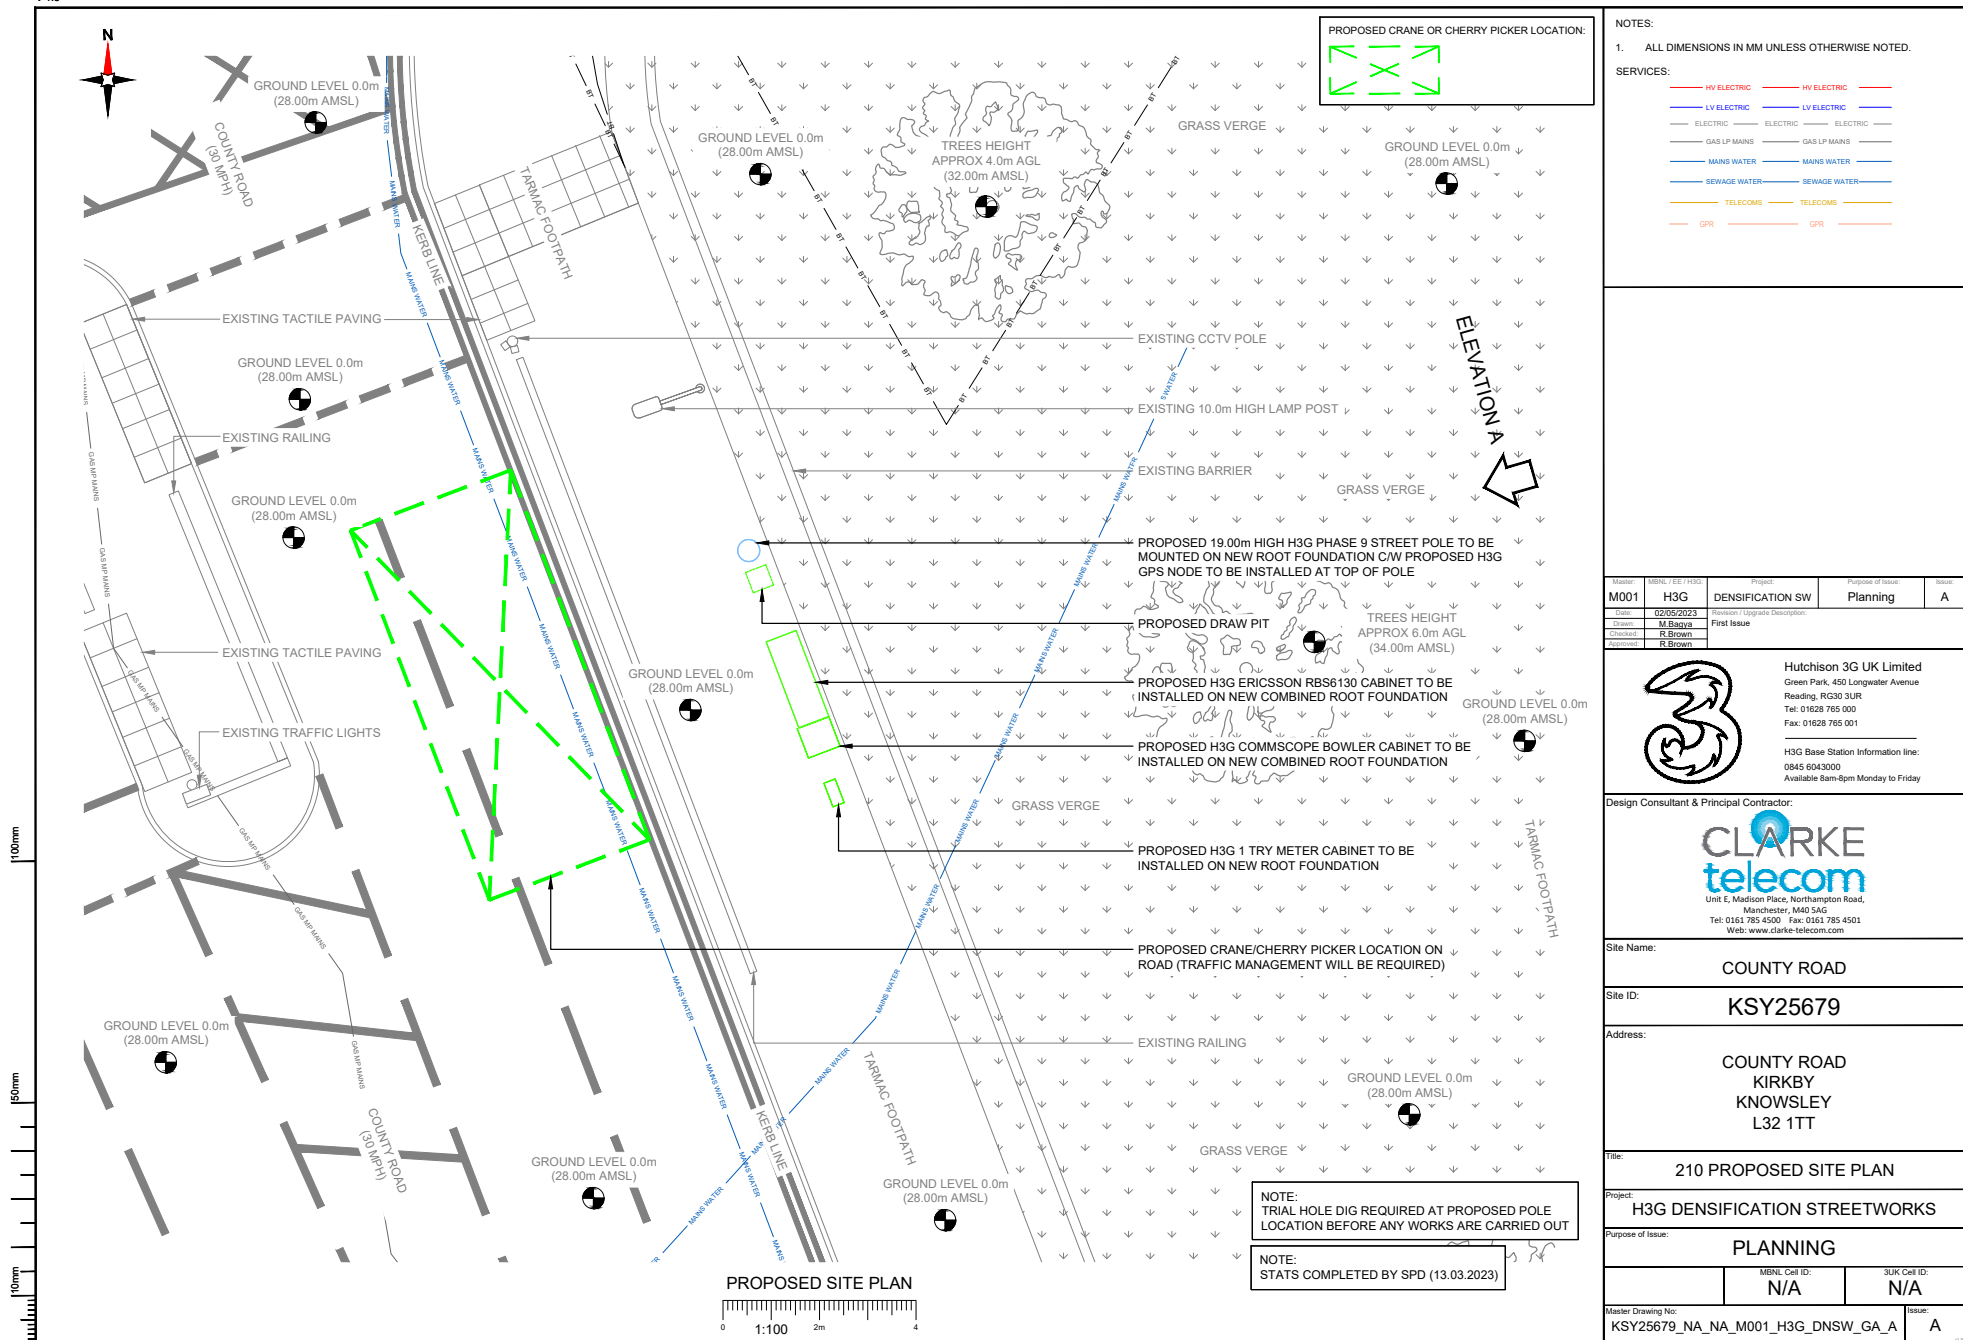

NOTES:

1. ALL DIMENSIONS IN MM UNLESS OTHERWISE NOTED.

SERVICES:

— HV ELECTRIC — HV ELECTRIC —

— LV ELECTRIC — LV ELECTRIC —

— ELECTRIC — ELECTRIC — ELECTRIC —

— GAS LP MAINS — GAS LP MAINS —

— MAINS WATER — MAINS WATER —

— SEWAGE WATER — SEWAGE WATER —

— TELECOMS — TELECOMS —

— GPR — GPR —

Sheet	MBNL Cell ID	Project	Proposed Cell ID	Issue
M001	H3G	DENSIFICATION SW	Planning	A
Date	02/05/2023	Revision/Change Description:		
Drawn	M. Brown	First Issue		
Checked	R. Brown			
Approved	R. Brown			



Hutchison 3G UK Limited
Green Park, 450 Longwater Avenue
Reading, RG30 3UR
Tel: 01628 785 000
Fax: 01628 785 001

H3G Base Station Information line:
0845 6043000
Available 8am-8pm Monday to Friday

Design Consultant & Principal Contractor:

CLARKE
telecom
Unit E, Madison Place, Northampton Road,
Manchester, M40 5AG
Tel: 0161 785 4500 Fax: 0161 785 4501
Web: www.clarke-telecom.com

Site Name:

COUNTY ROAD

Site ID:

KS25679

Address:

COUNTY ROAD
KIRKBY
KNOWSLEY
L32 1TT

Title:

210 PROPOSED SITE PLAN

Project:

H3G DENSIFICATION STREETWORKS

Purpose of Issue:


PLANNING

Master Drawing No:

KS25679_NA_NA_M001_H3G_DNSW_GA_A

Issue:

A

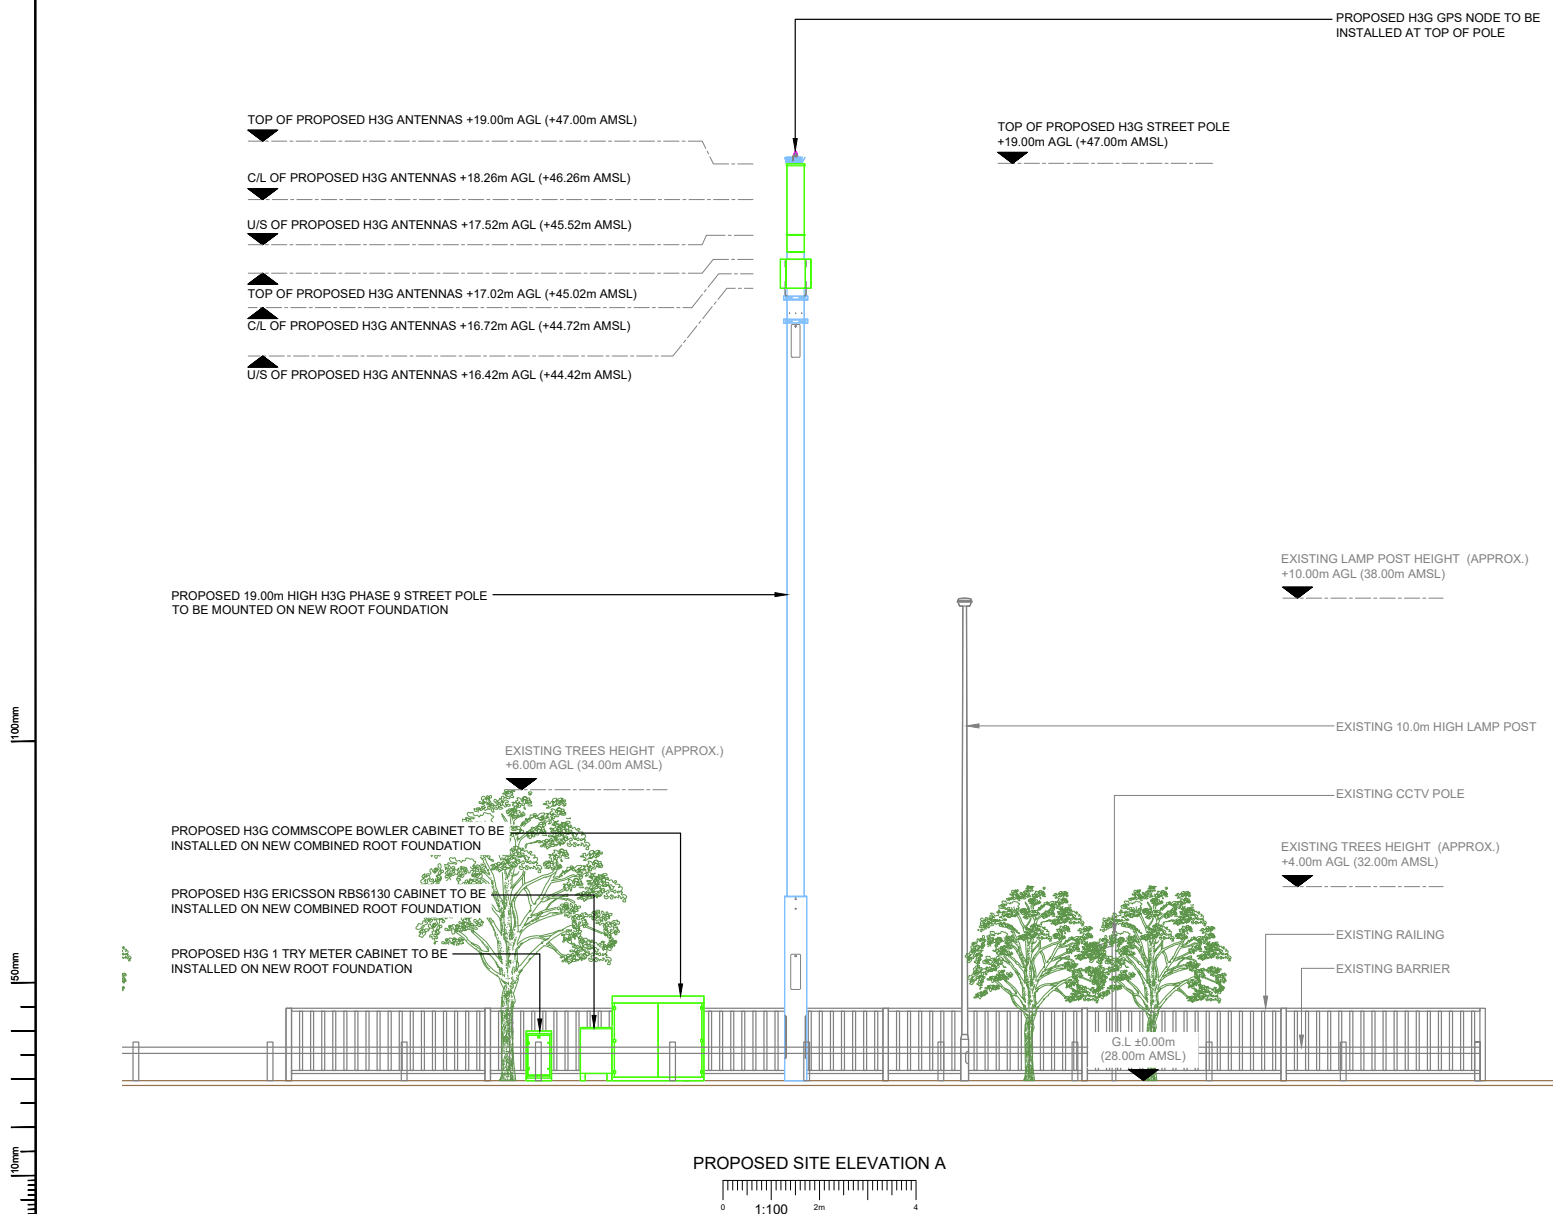

NOTES:

- ALL DIMENSIONS IN MM UNLESS OTHERWISE NOTED.

Sheet	MBNL Cell ID	Project	Proposed Cell Name	Issue
M001	H3G	DENSIFICATION SW	Planning	A
Date	02/05/2023	Revision / Corporate Description		
Drawn	M. Baya	First Issue		
Checked	R. Brown			
Approved	R. Brown			



Hutchison 3G UK Limited
Green Park, 450 Longwater Avenue
Reading, RG30 3UR
Tel: 01628 785 000
Fax: 01628 785 001

H3G Base Station Information line:
0845 6043000
Available 8am-8pm Monday to Friday

Design Consultant & Principal Contractor:



Site Name:

COUNTY ROAD

Site ID:

KSY25679

Address:

COUNTY ROAD
KIRKBY
KNOWSLEY
L32 1TT

Title:

260 PROPOSED SITE ELEVATION A

Project:

H3G DENSIFICATION STREETWORKS

Purpose of Issue:

PLANNING

MBNL Cell ID	3UK Cell ID
N/A	N/A

Master Drawing No:

KSY25679_NA_NA_M001_H3G_DNSW_GA_A

Issue:

A