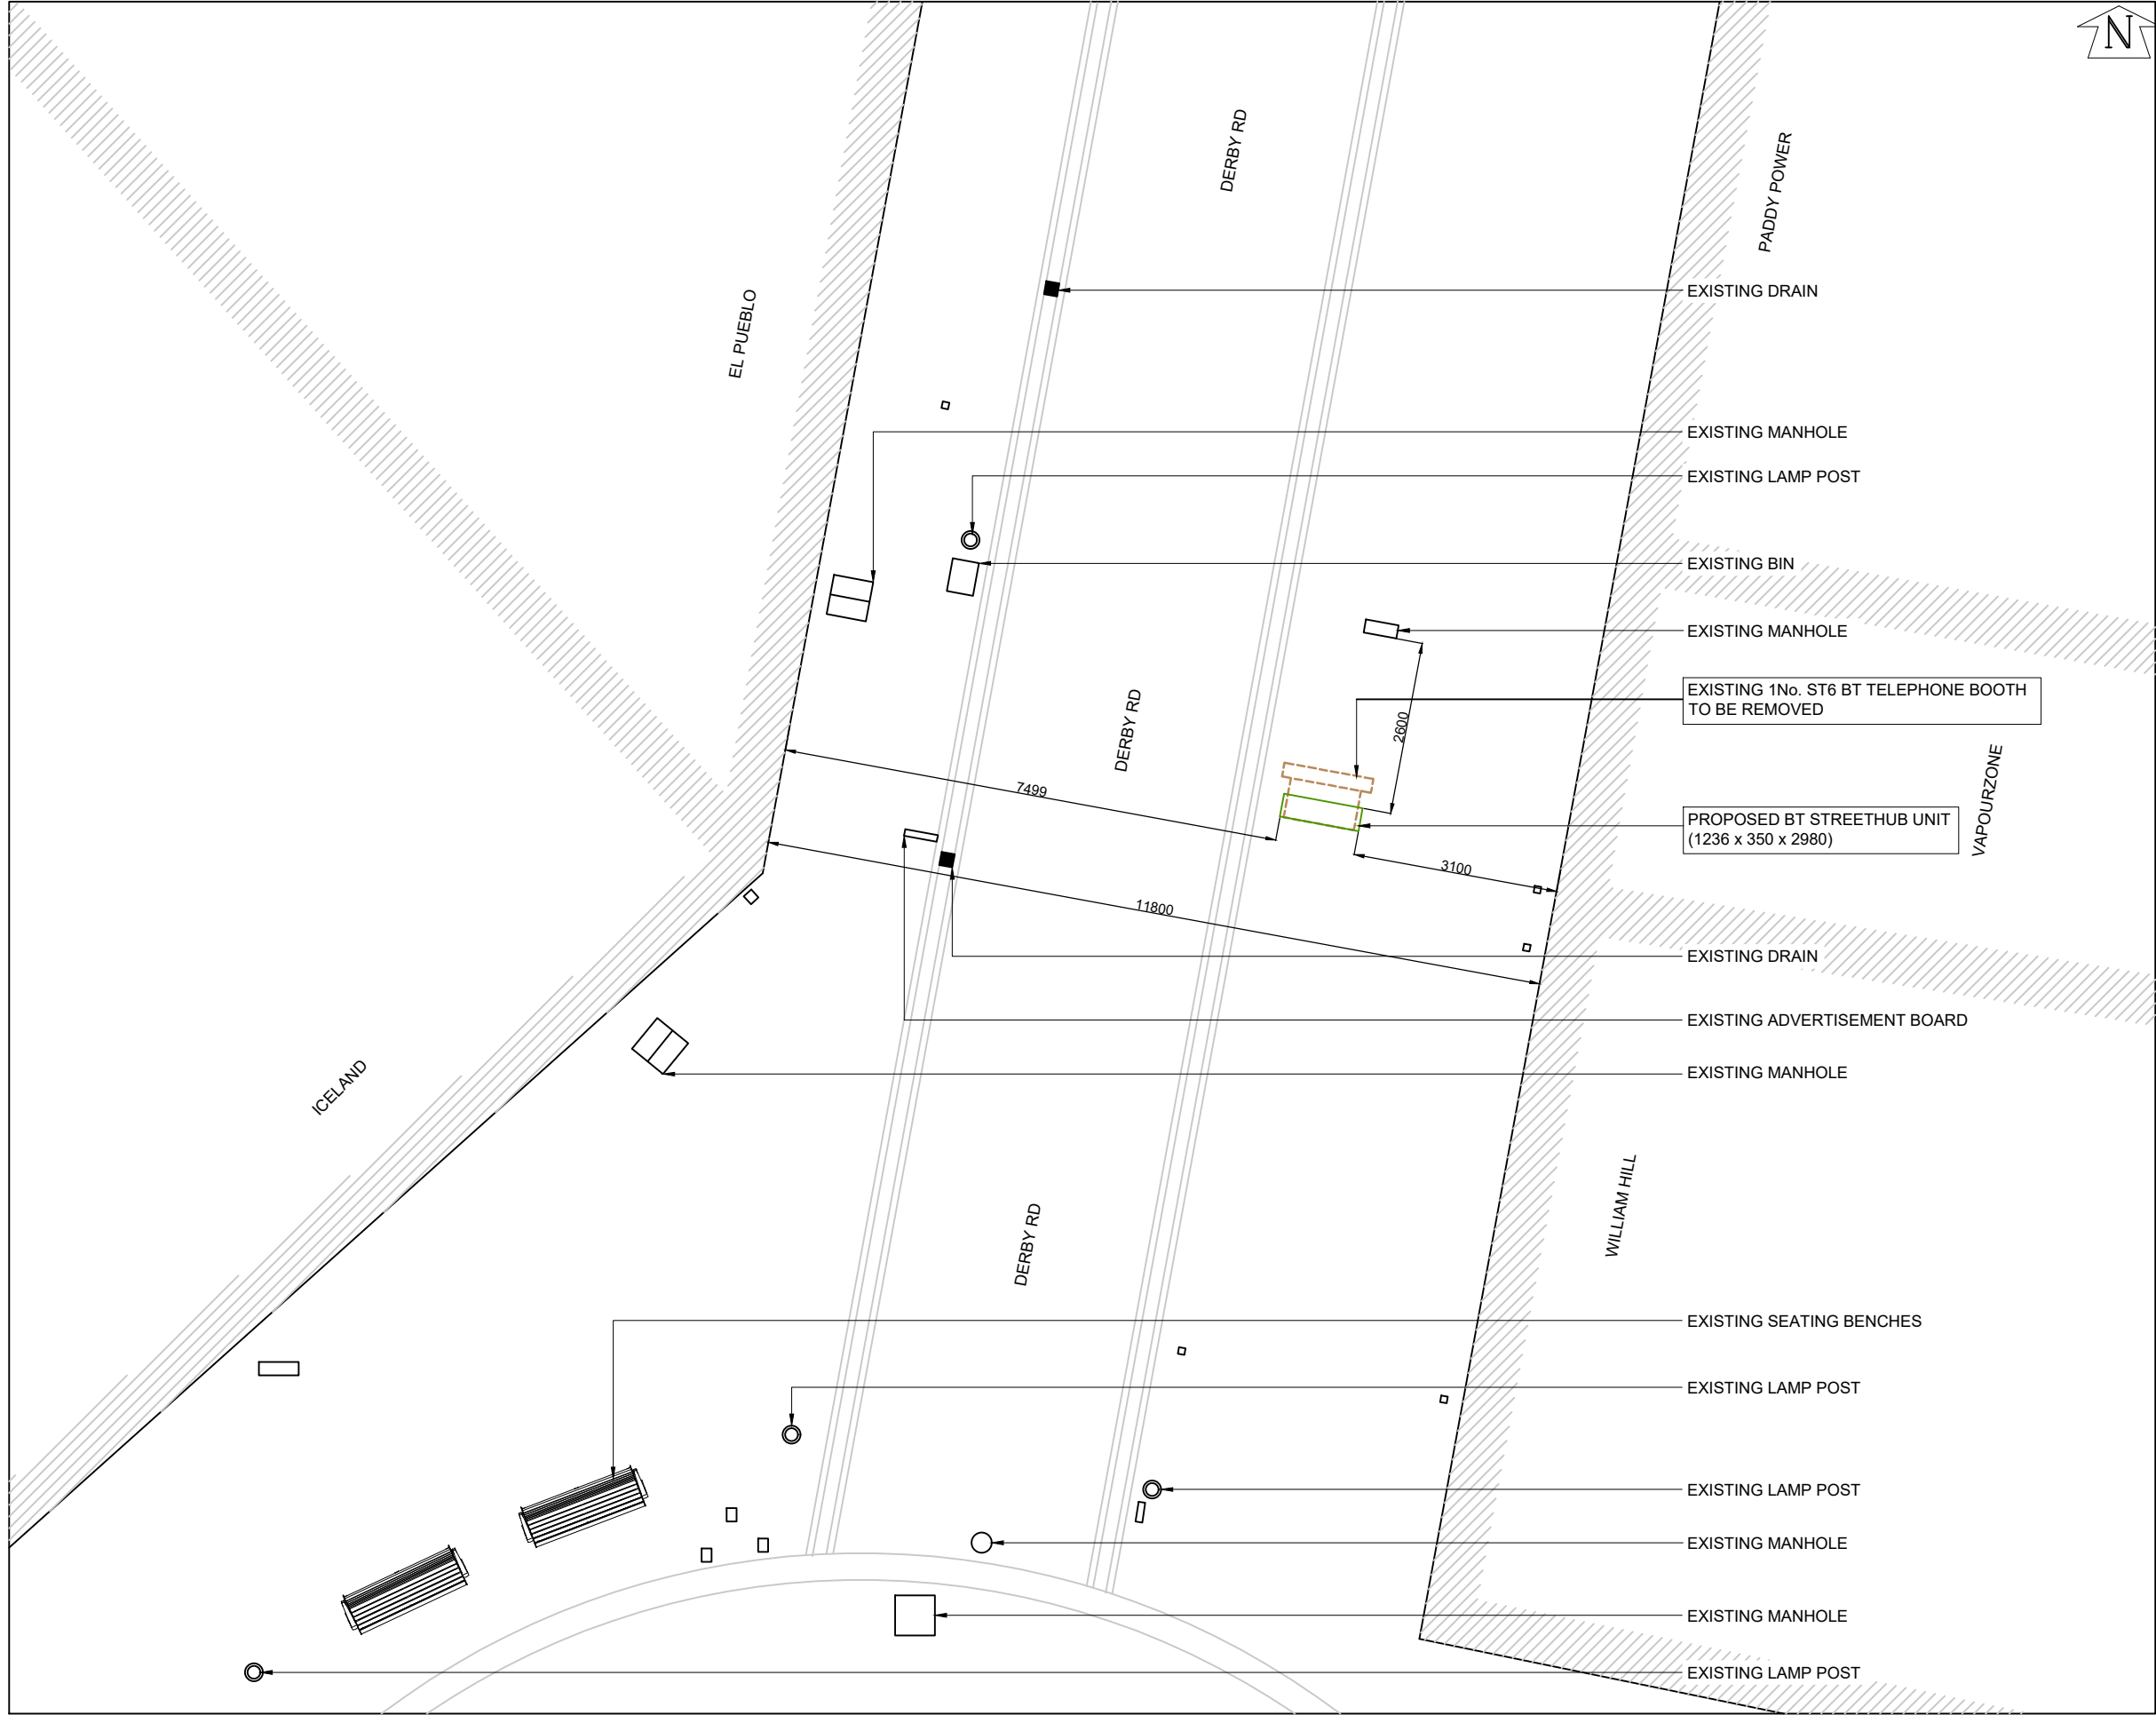


PROPOSED SITE PLAN
SCALE 1:100

GENERAL NOTES

Use written dimensions only, do not scale from drawing. Use latest revision of all referenced information.

Rev	Date	Description	Drawn	Chkd
A	21.02.22	New BT Streethub Structure	MD	JE

mono

#

MONO CONSULTANTS LIMITED
70-76 Steam Packet House
Cross Street
Manchester, M2 4JG
t. 44 (0)161 839 8839
www.monoconsultants.com



Drg Status
PLANNING

Cell No. & Name

KNOW001

Site Name & Address

Pavement o/s Paddy Power
Derby Road Huyton Liverpool
L36 9UQ

Drawing Title
PROPOSED SITE PLAN

Scale	1:100	Date	21.02.2022
Drawn By	MD	Checked By	JE
Drawing Number	002	Revision	A