
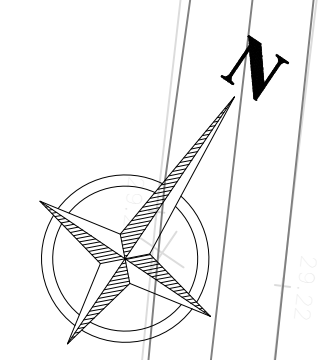


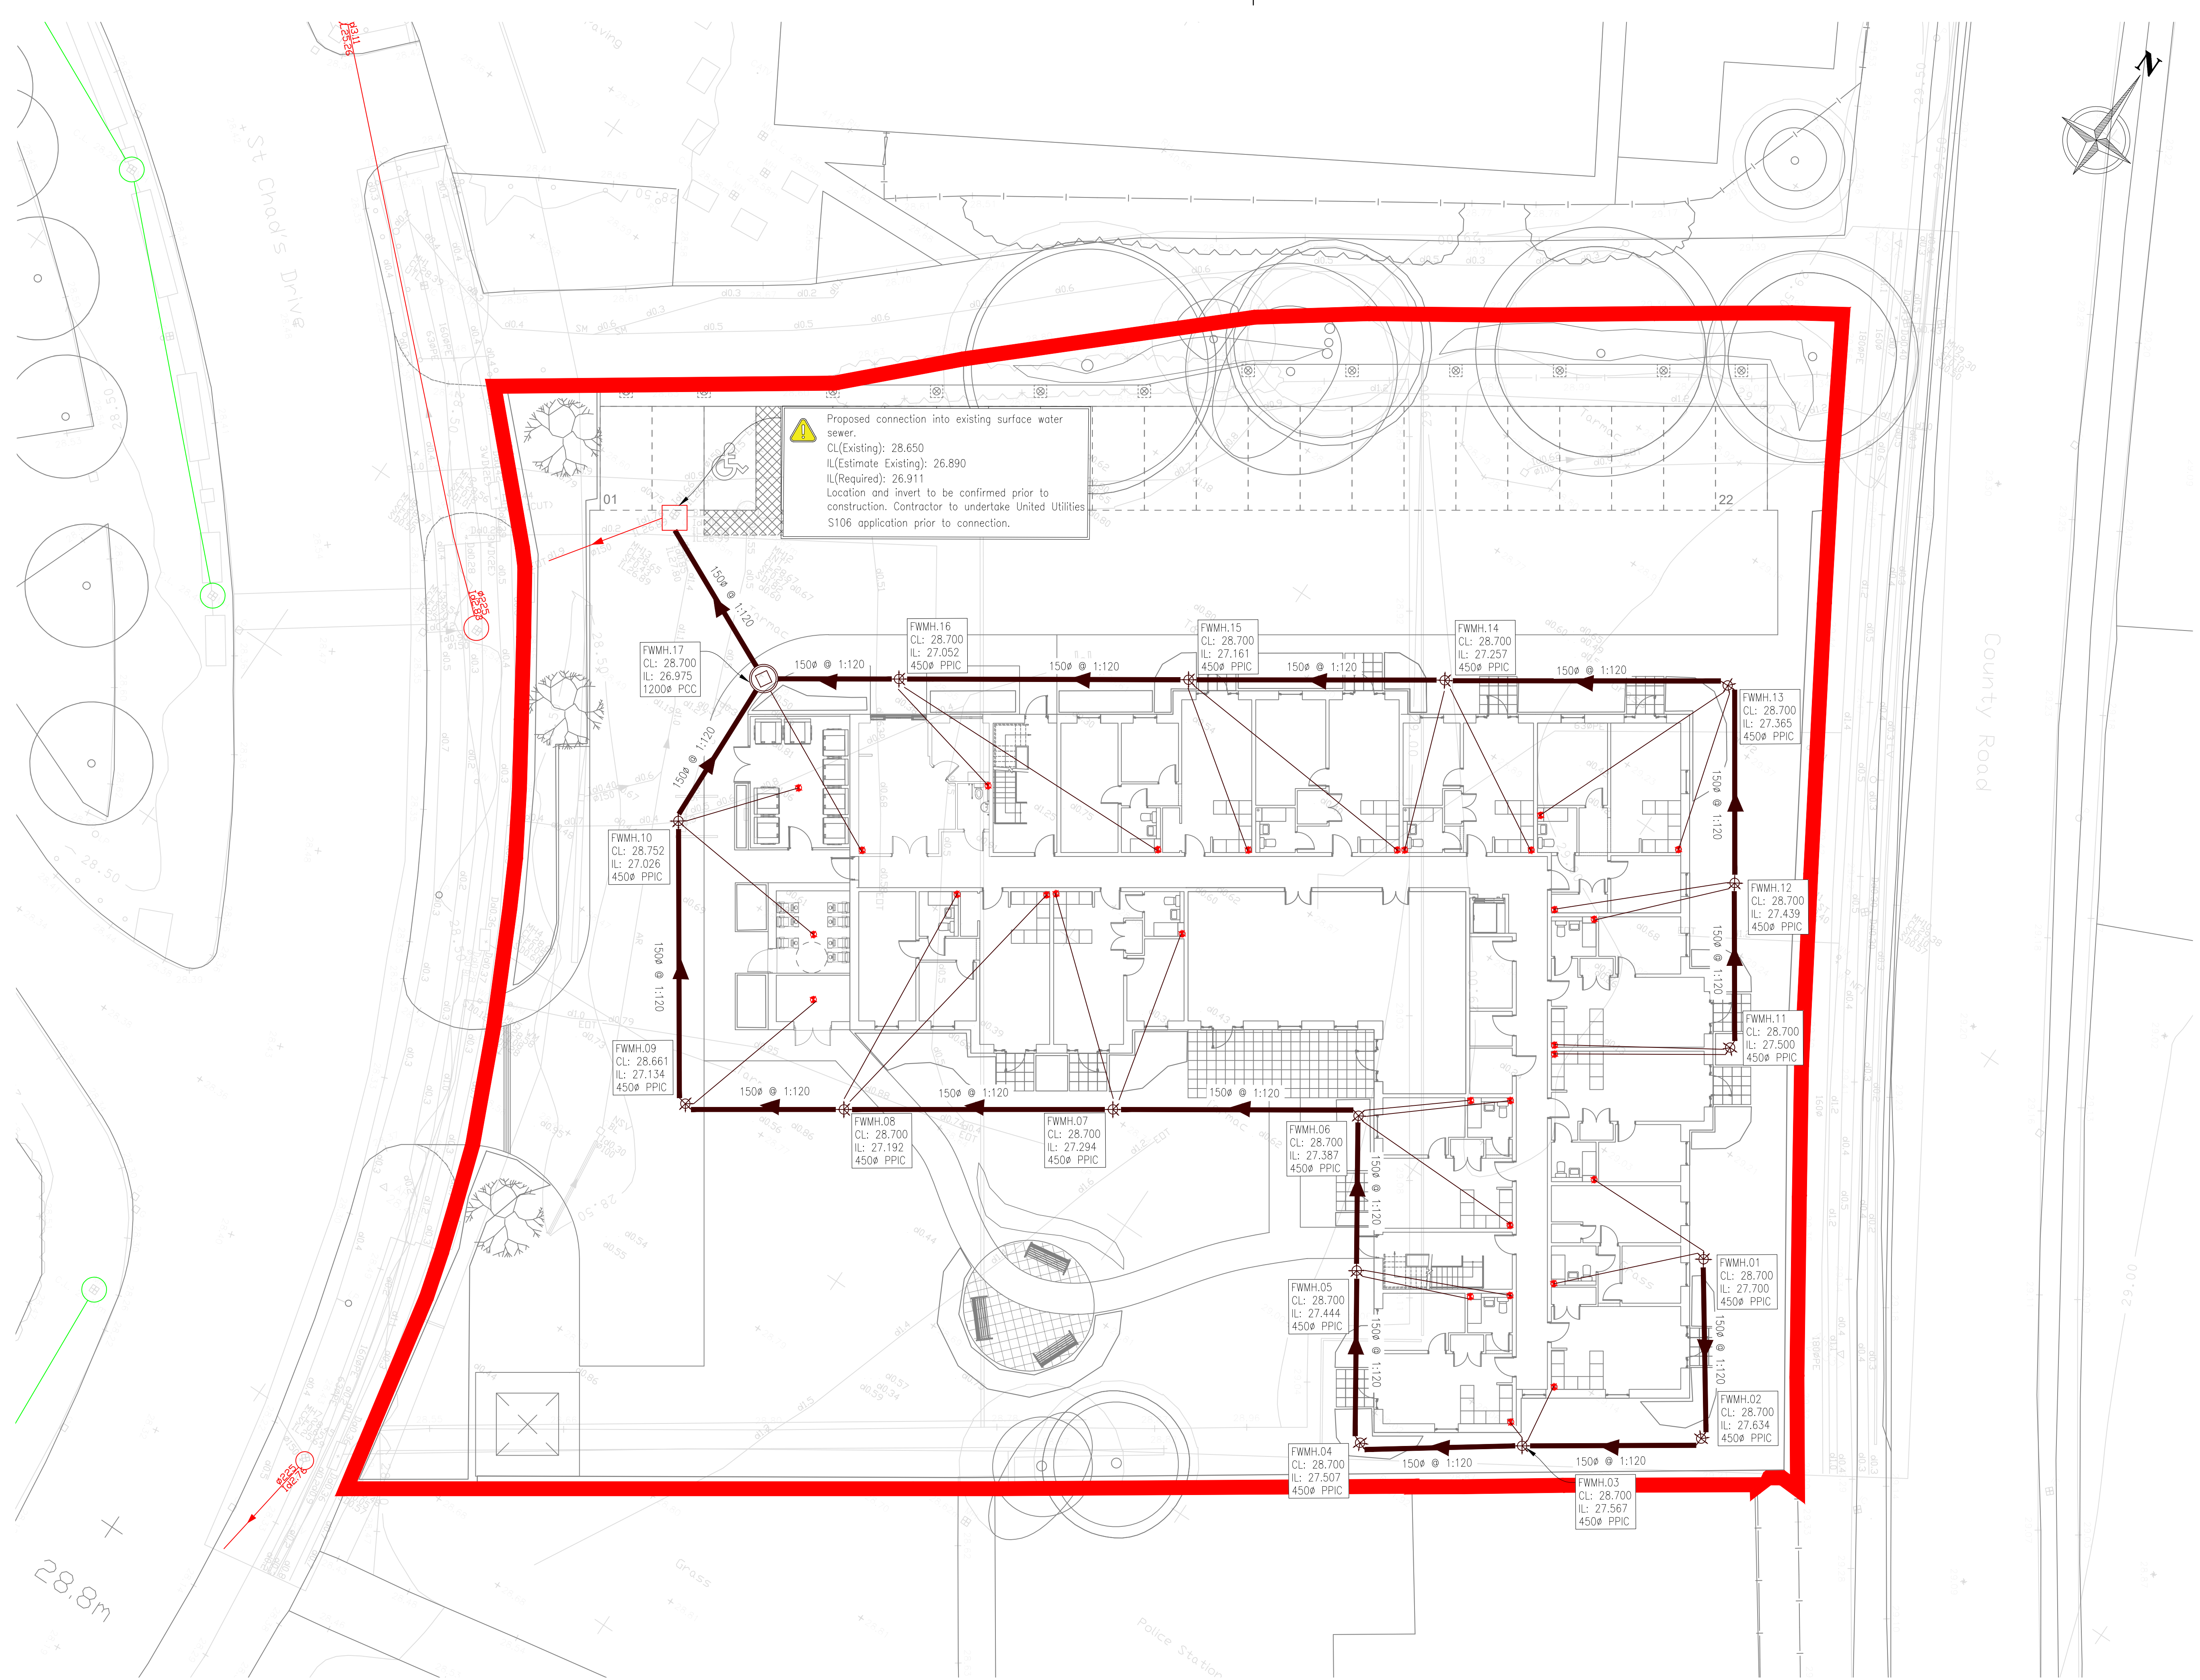

- NOTES:-
1. All dimensions must be checked on site and not scaled from this drawing.
 2. The Contractor shall make a survey of the site and shall be responsible for obtaining all dimensions and levels necessary for the proper fabrication of the structure as indicated.
 3. All levels shown on this drawing are relative to Agreed Datum.
 4. This drawing is to be read in conjunction with 29958/100 Series Drawings.
 5. All existing invert levels are to be confirmed by contractor prior to construction. Connection subject to approval.

- Denotes Site Boundary – 3,535m²
- Denotes Existing Surface Water Manhole
- Denotes Existing Surface Water Pipe
- Denotes Existing Foul Water Manhole
- Denotes Existing Foul Water Pipe
- Proposed Foul Water Sewer
- Proposed Foul Water Concrete Chamber
- Proposed Foul Water PPIC Chamber
- Proposed Soil Vent Stack

B	27/11/23	ISSUED FOR APPROVAL	WP	WP
A	20/11/23	ISSUED FOR APPROVAL	WP	WP
Rev	Date	Description	DR	CH

© copyright

GGP CONSULT
CONSULTING ENGINEERS
ARCHITECTS
PROJECT MANAGEMENT
2 Hallam Road
Priory Park East
HULL HU4 7DY
United Kingdom
Telephone(+44) 01482 627963
Fax (+44) 01482 641736
Email info@ggpconsult.co.uk

Client **McCARTHY STONE**
Life, well lived

Job Title
Kirkby,
St Chad's Drive,
Liverpool,
L32 8RH

Drawing Title
**Proposed Foul Water
Drainage Plan**

Status	APPROVAL		
Scale	1:150 @ A1	Date	Nov' 2023
Drawn By	K. Thompson	Checked	W.B
		Approved	J.H.C

Drw. No.	29958 / 105	Rev	B
----------	-------------	-----	---

NOT FOR CONSTRUCTION