


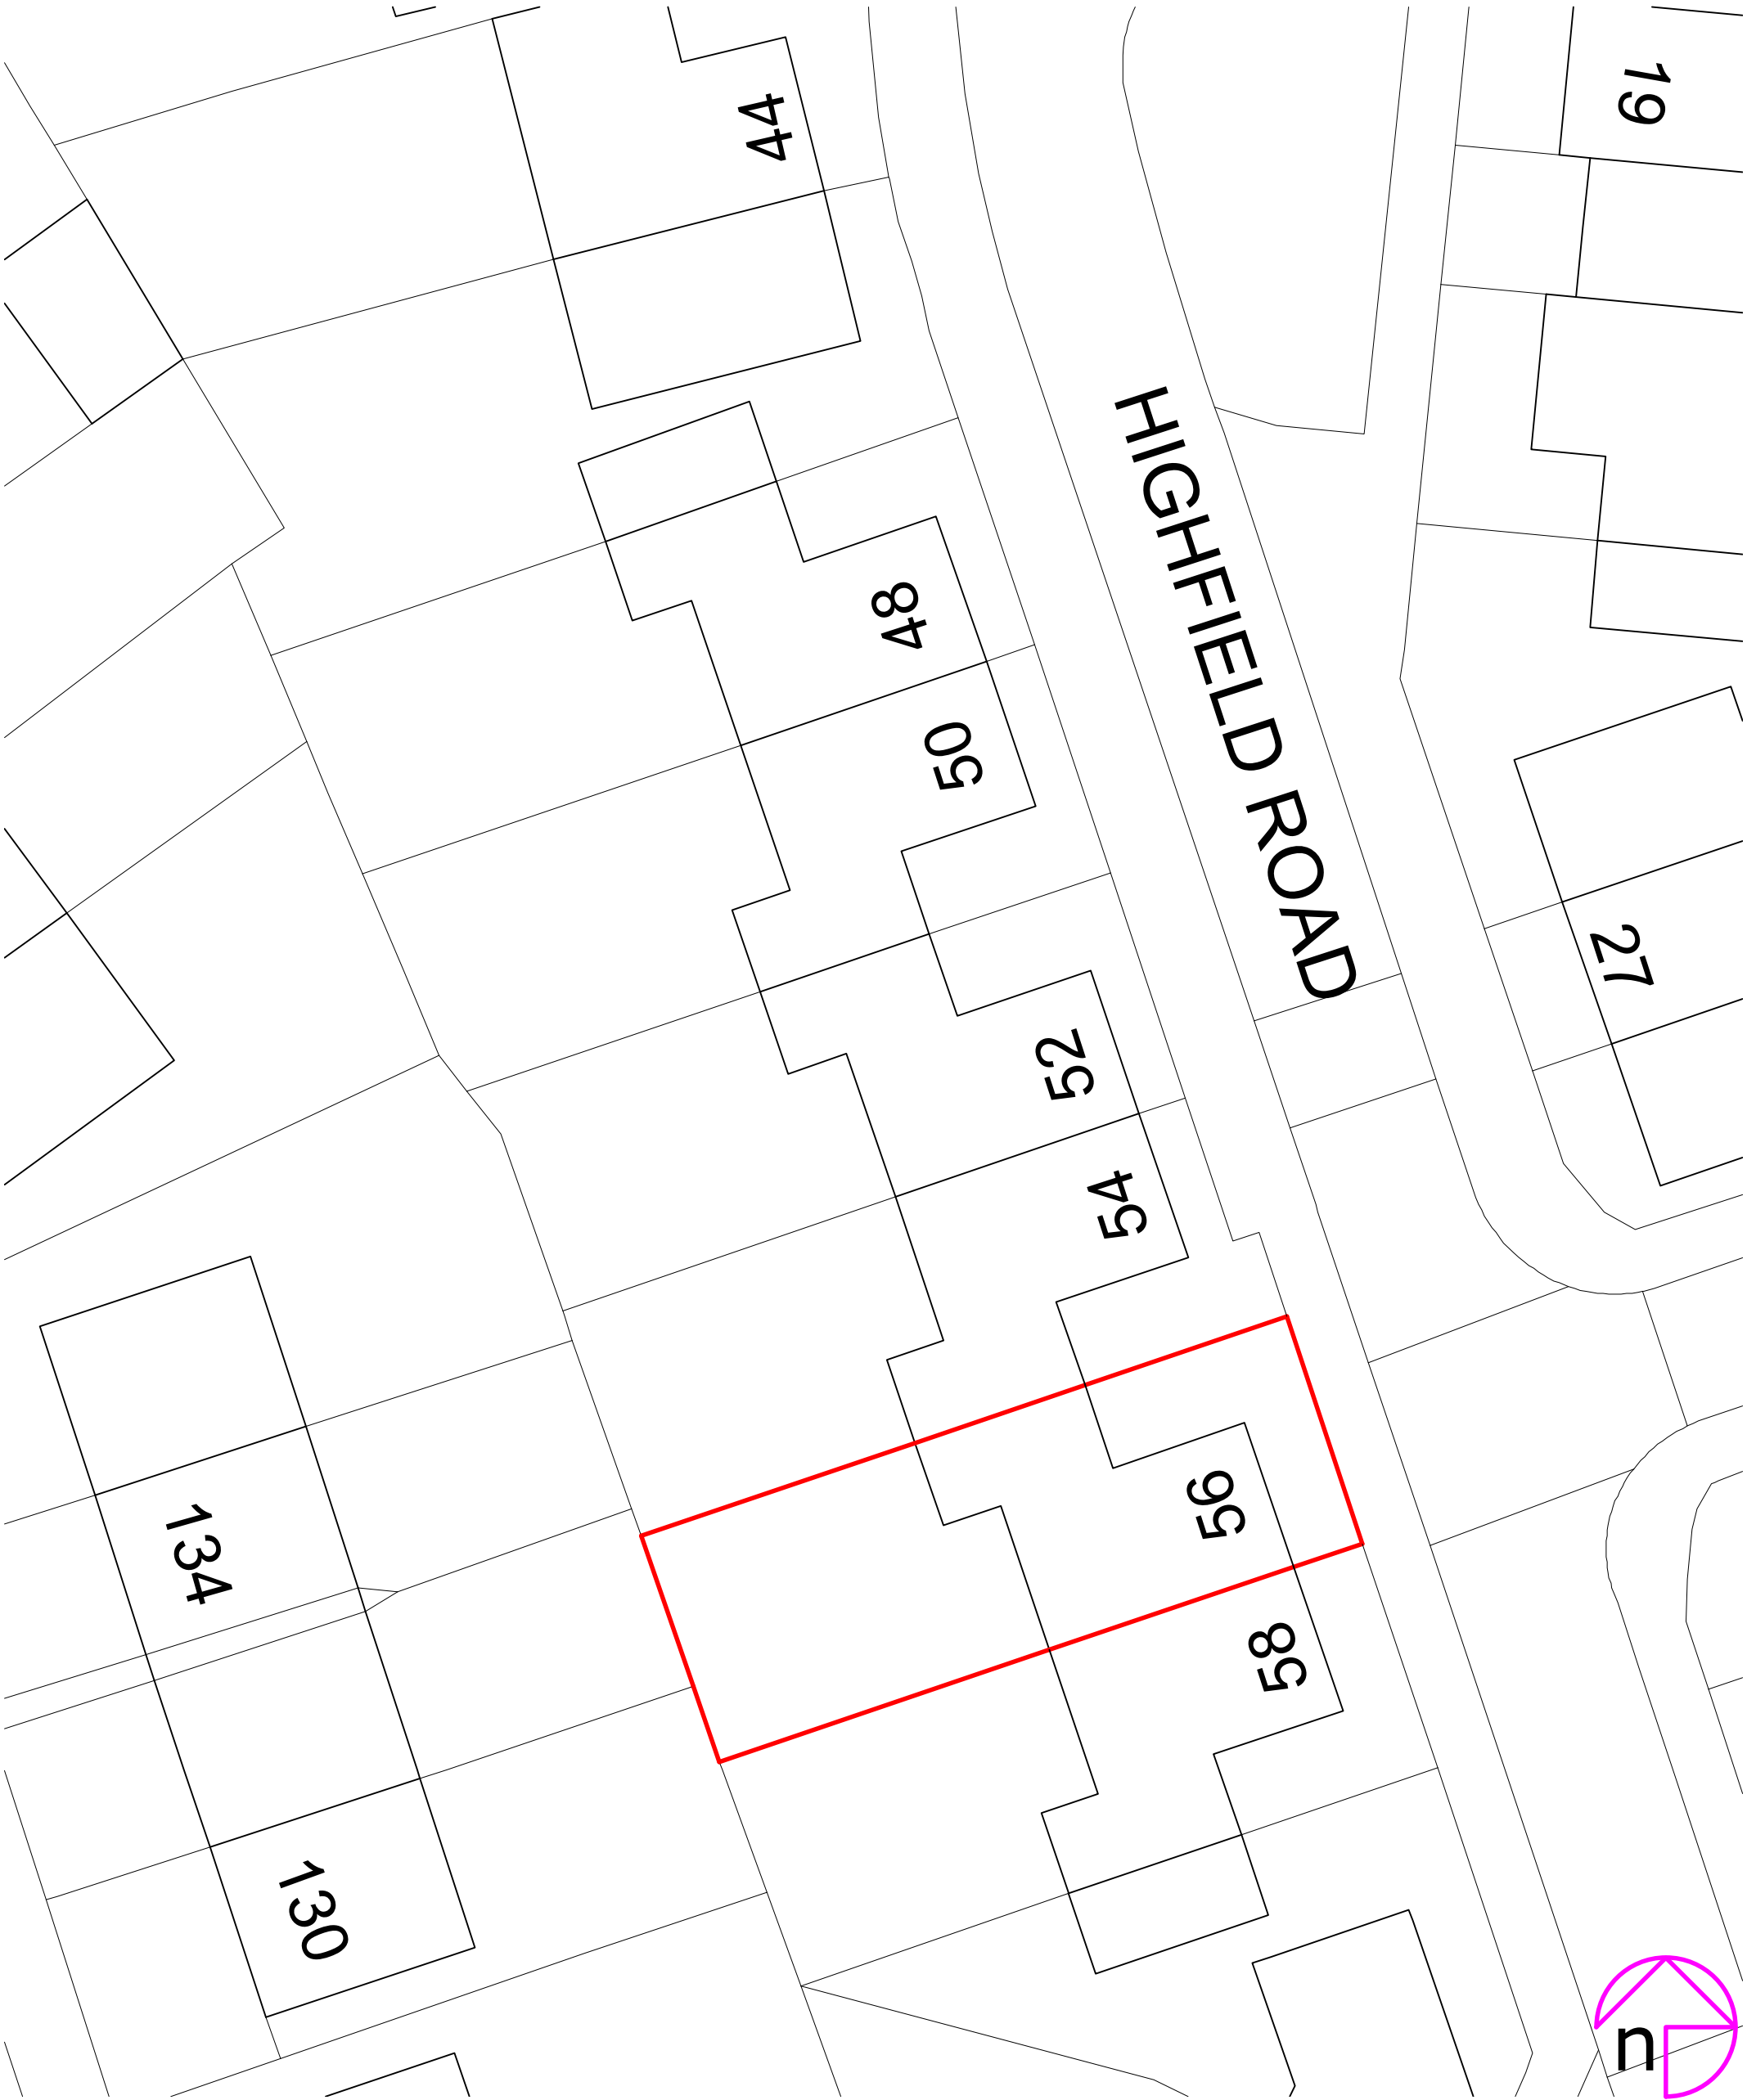

Drawing title:
Site plan as existing

Project status:
PLANNING (installation of air source heat pump)

Rev:	Description:	By:	Date:
------	--------------	-----	-------



octopusenergy
services

Accredited by:


Client/Project:
Ged Sys
56 Highfield Road, Huyton
Liverpool, L36 3XR

Scale: 1:200	Paper Size: A3	Drawn: O Sage	Checked: Joe Walker
Project ID: J-1DAC8156	Drawing No: 01	Revision:	Date: 27.08.25