



Unit 6b

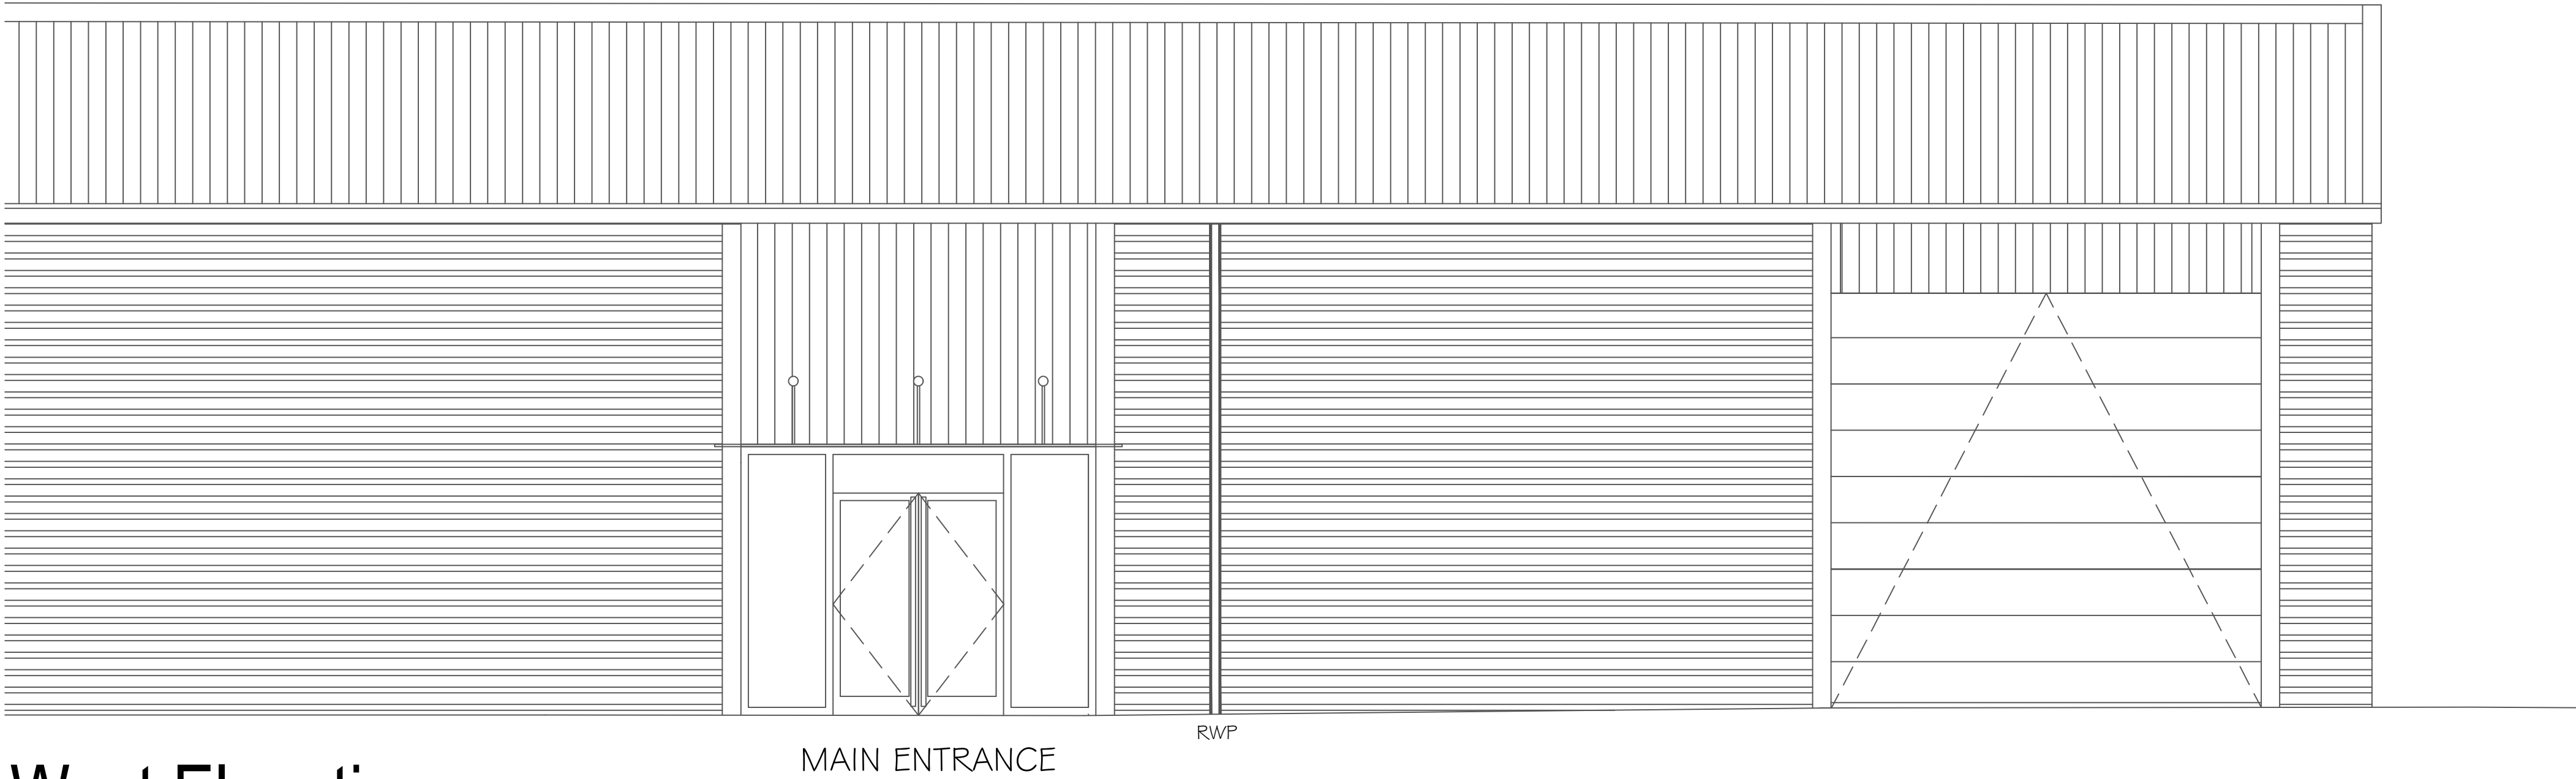


West Elevation

Unit 6b

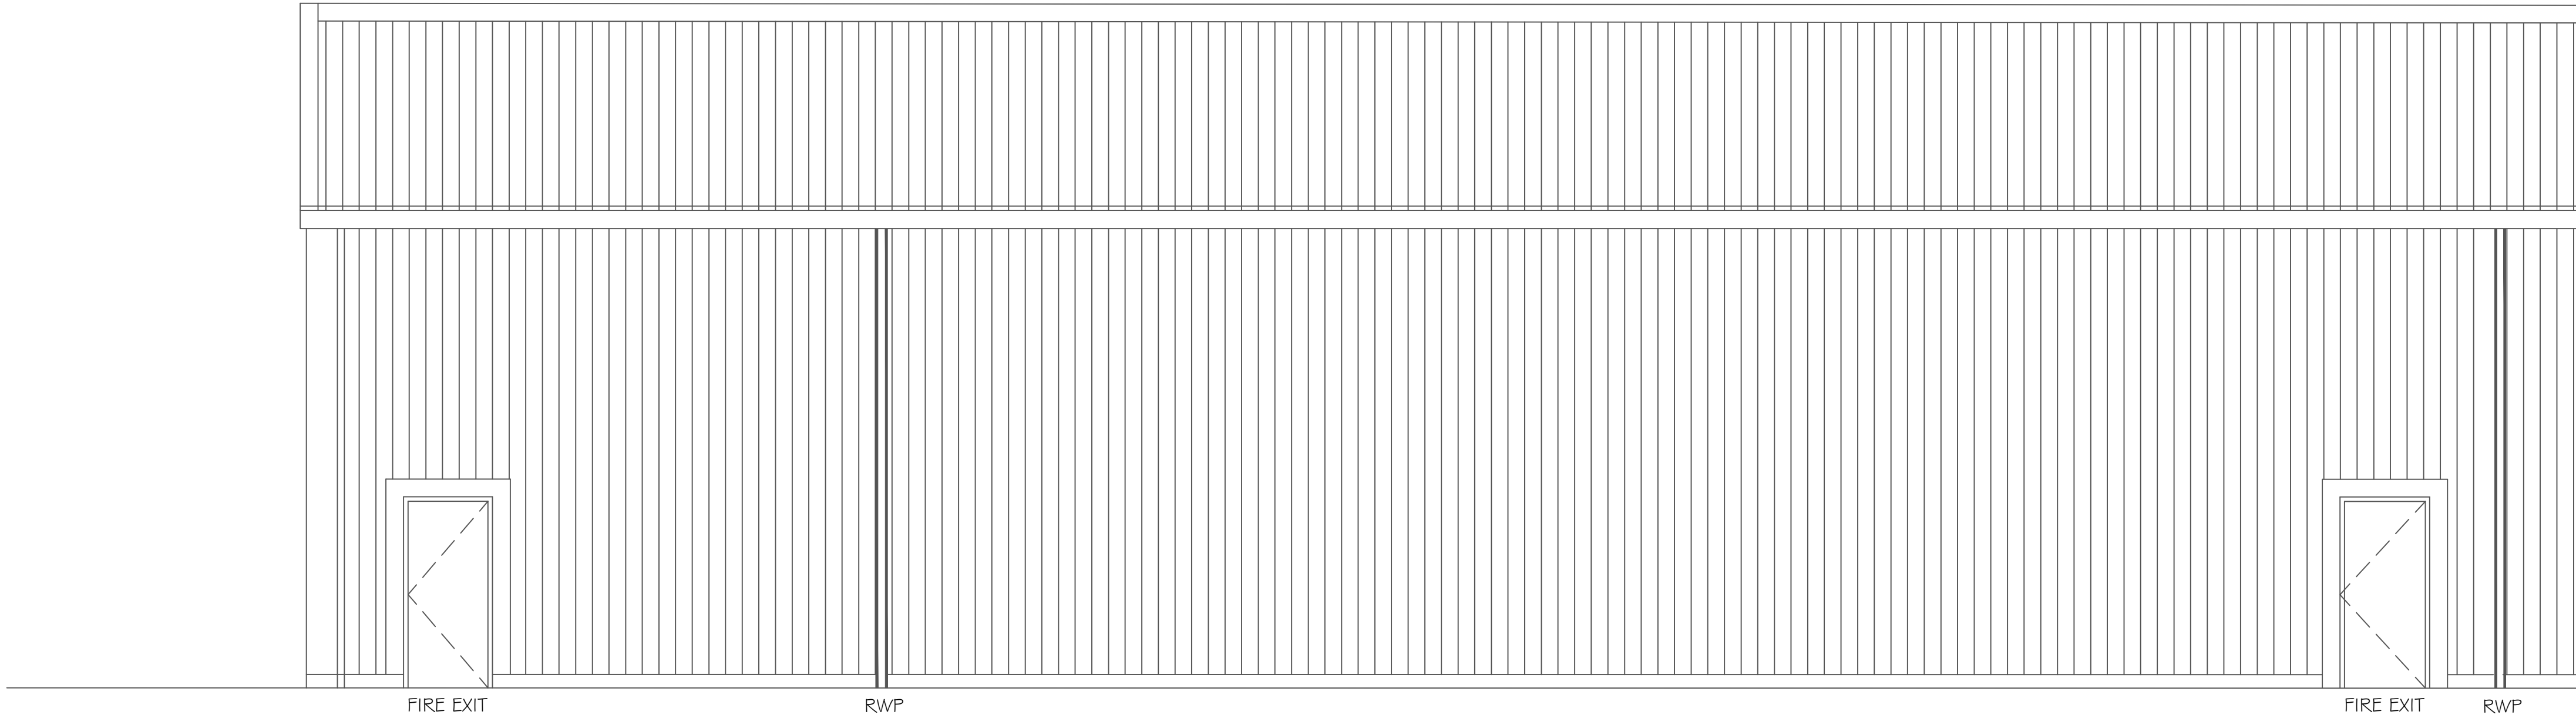


Proposed East Elevation

Unit 6b

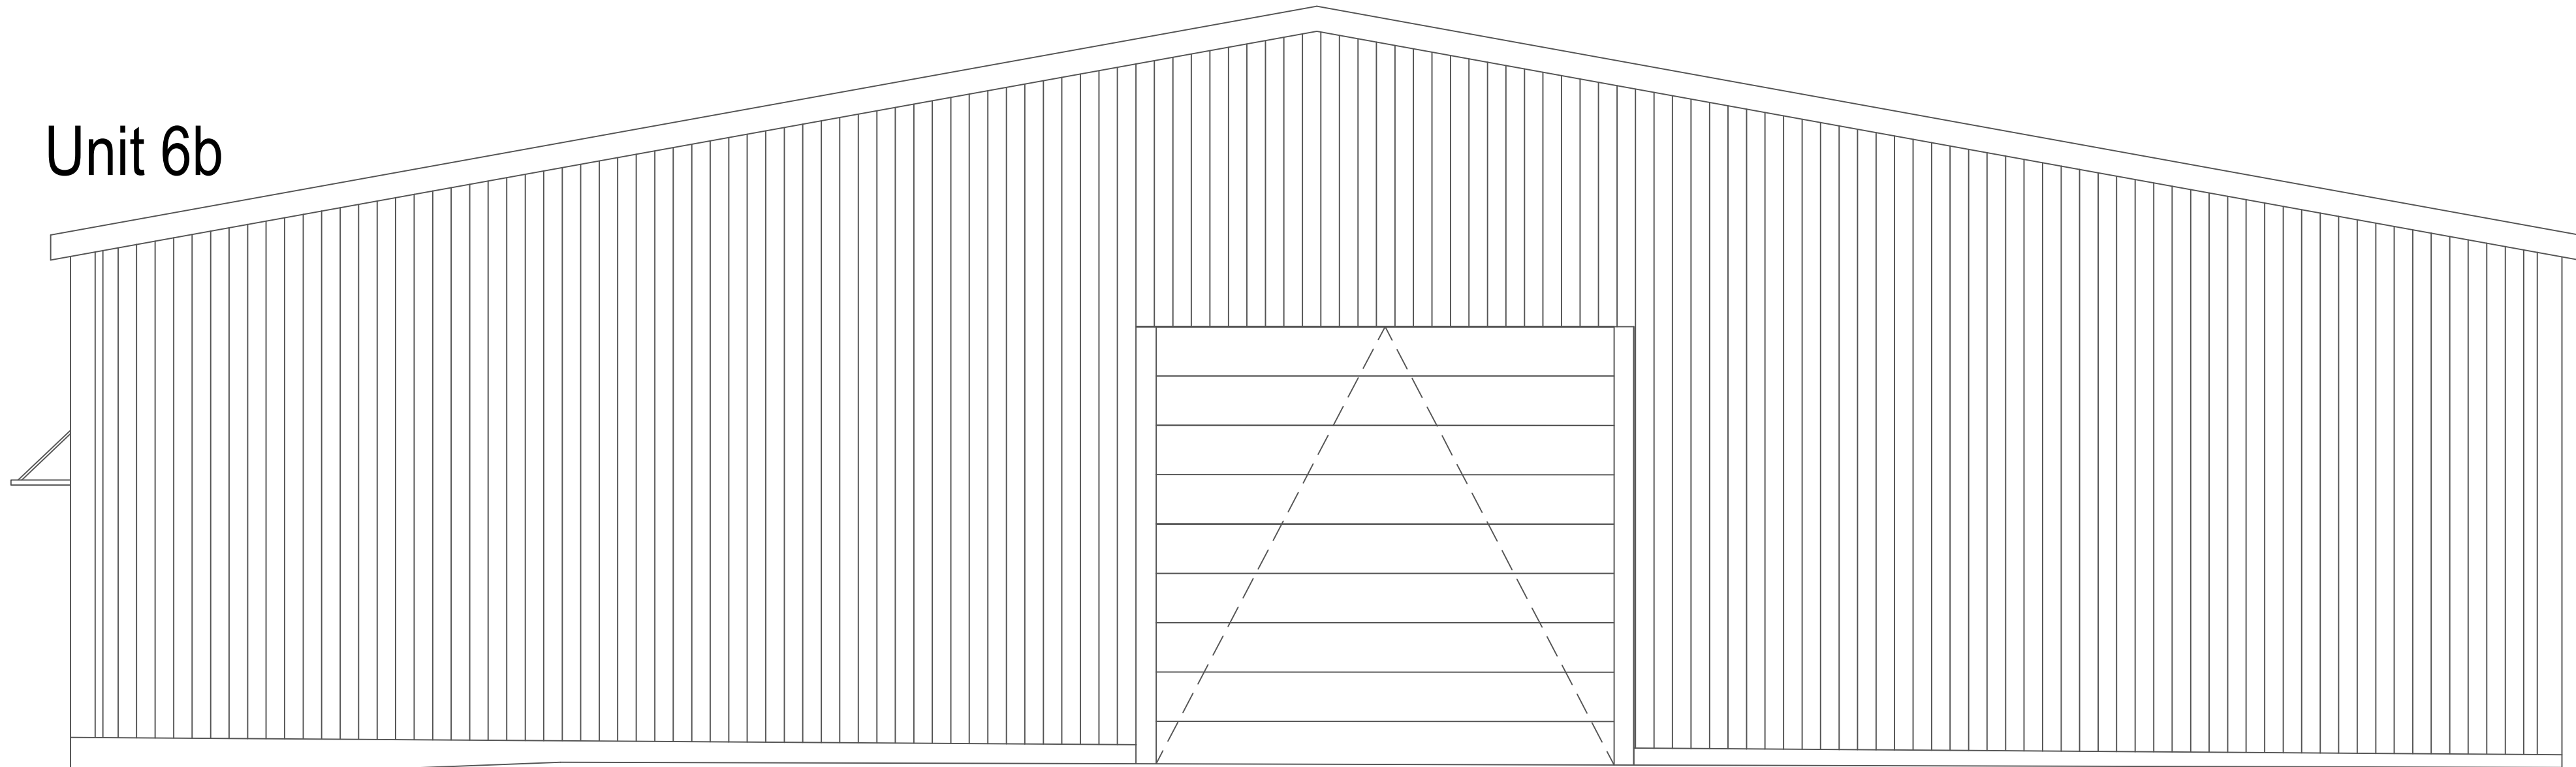

Proposed South Elevation

SITE PHOTOGRAPHS

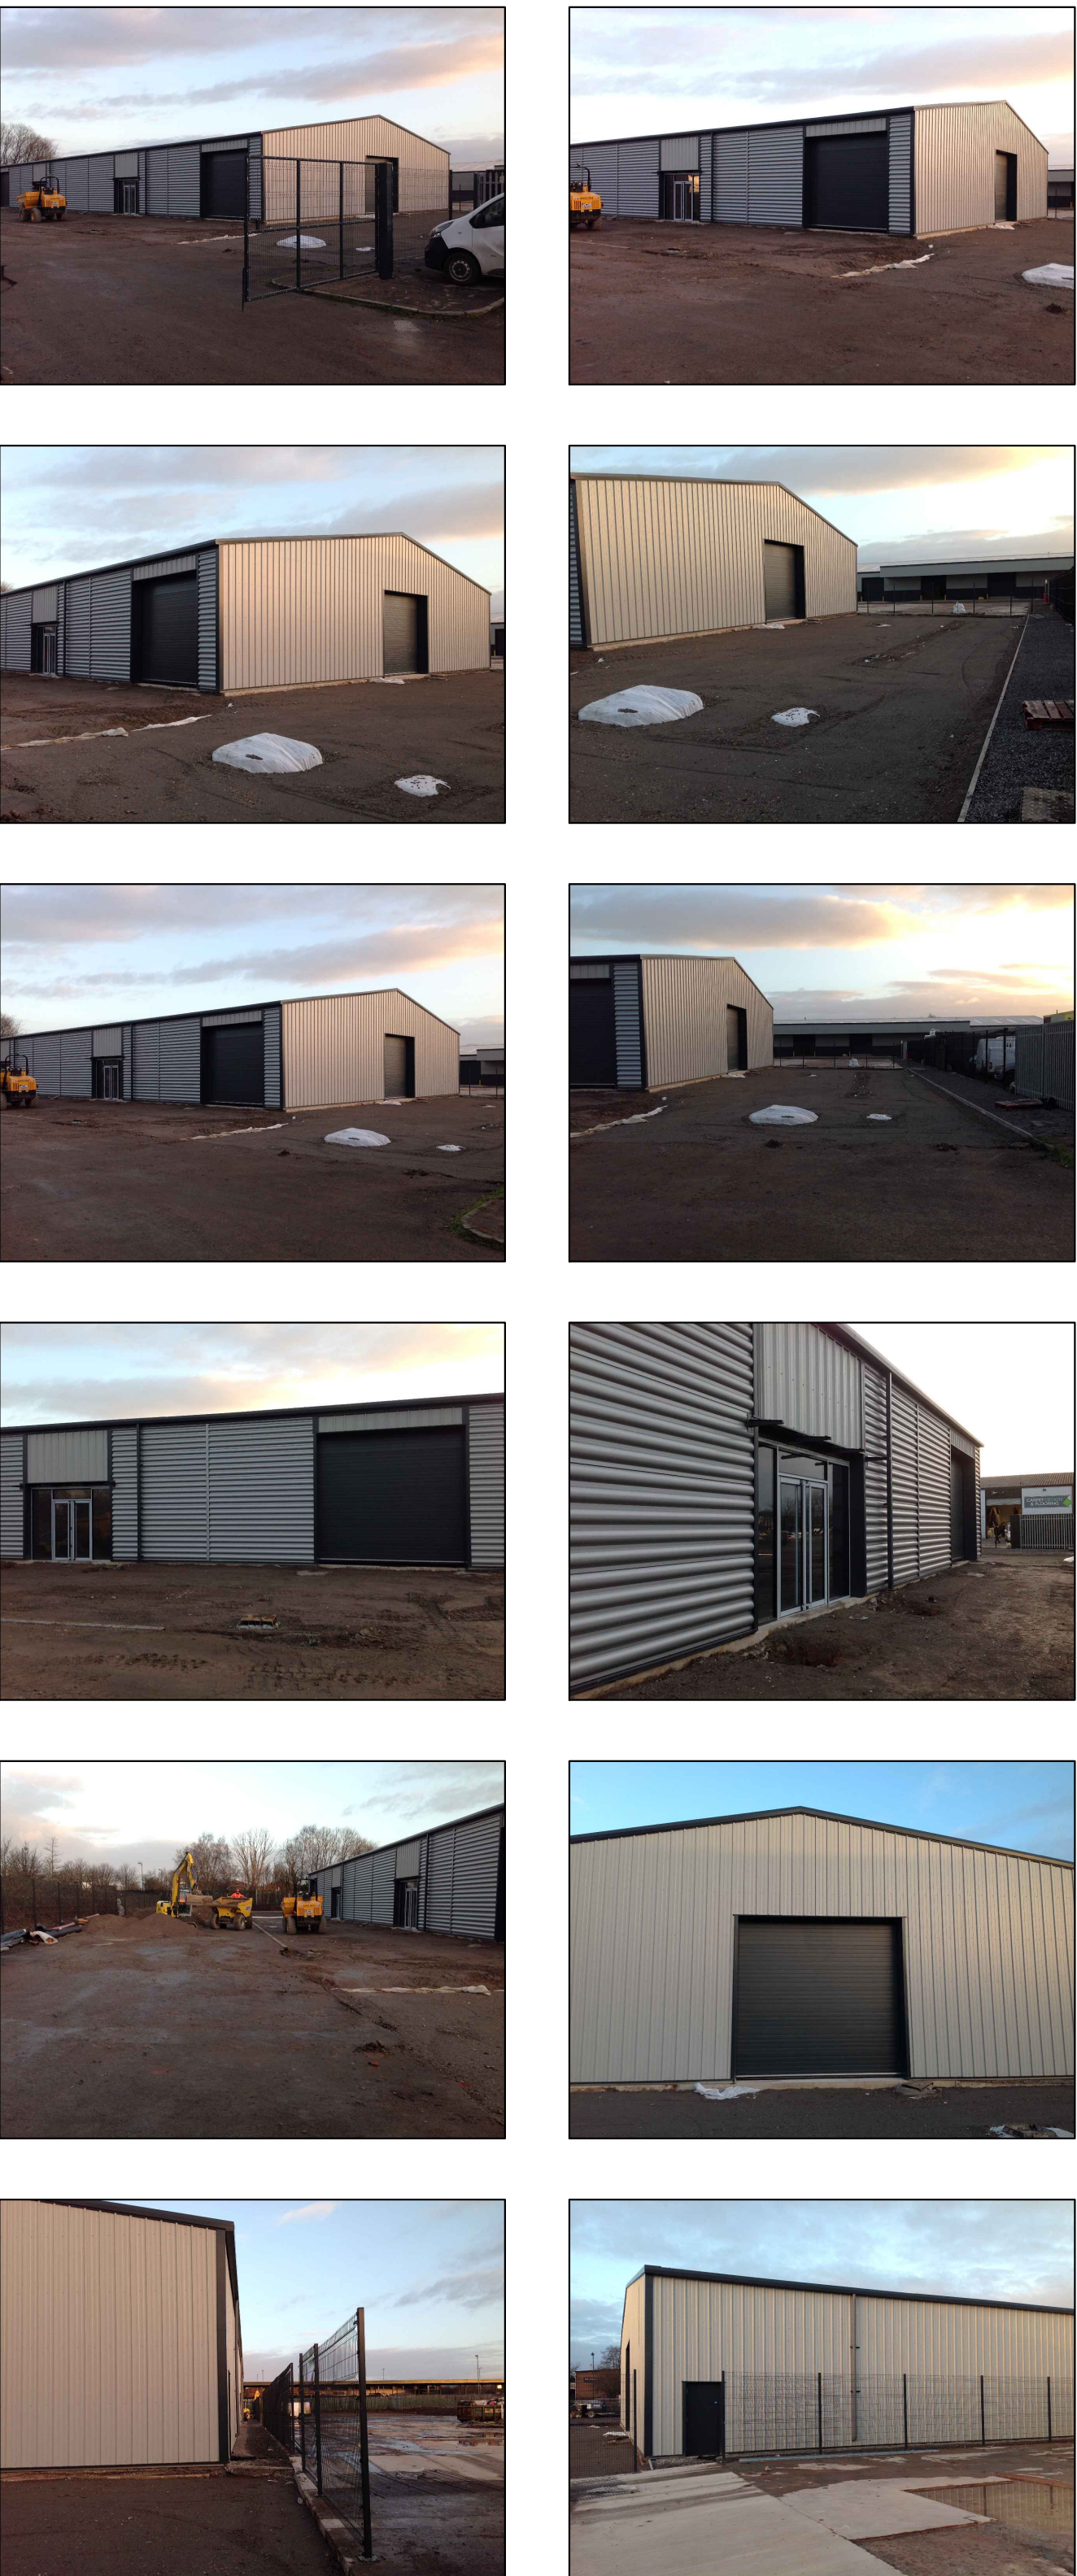

EXISTING DRAWING
ELEVATIONS
STAGE 3

Site Address

CITY PLUMBING SUPPLIES LTD
Unit 6b
Interchange Trade Counter,
Huyton Business Park,
L36 6JF

0m 5m 10m

NOTES: 1. All Dimensions to be checked on site, prior to manufacture and installation. Drawings subject to planning permission approval.		CLIENT: CITY PLUMBING SUPPLIES PROJECT: NEW PROJECT 2022 PROJECT LOCATION: CPS LIVERPOOL HUYTON Unit 6B TITLE: Existing Elevations General Layout STAGE 3 DATE: January 2022 SCALE: 1:75 @ A0 PROJECT NO.: LIVERPOOL HUYTON - 01		DRAWN: L.D. PAPER SIZE: A0 SHIRT: 4 REV: /	
James Sifton (TP Group Head Of Format) E: james.sifton@travisperkins.co.uk T: 012352 180000 This drawing should not be copied or used in any way without prior permission from City Plumbing Supplies Ltd. Always refer to the drawing version register at City Plumbing Supplies Ltd.		lee dixon interior design 152 Newhall Street, Newcastle, Leeds, LS16 4DT 01924070970 leedson@leedson.co.uk CITY PLUMBING City Plumbing Supplies Limited, Head Office, Eldon Way, Cock Industrial Estate, Clix, Northampton, NN6 7SL		REVISIONS: Rev: Date: Description: By:	