




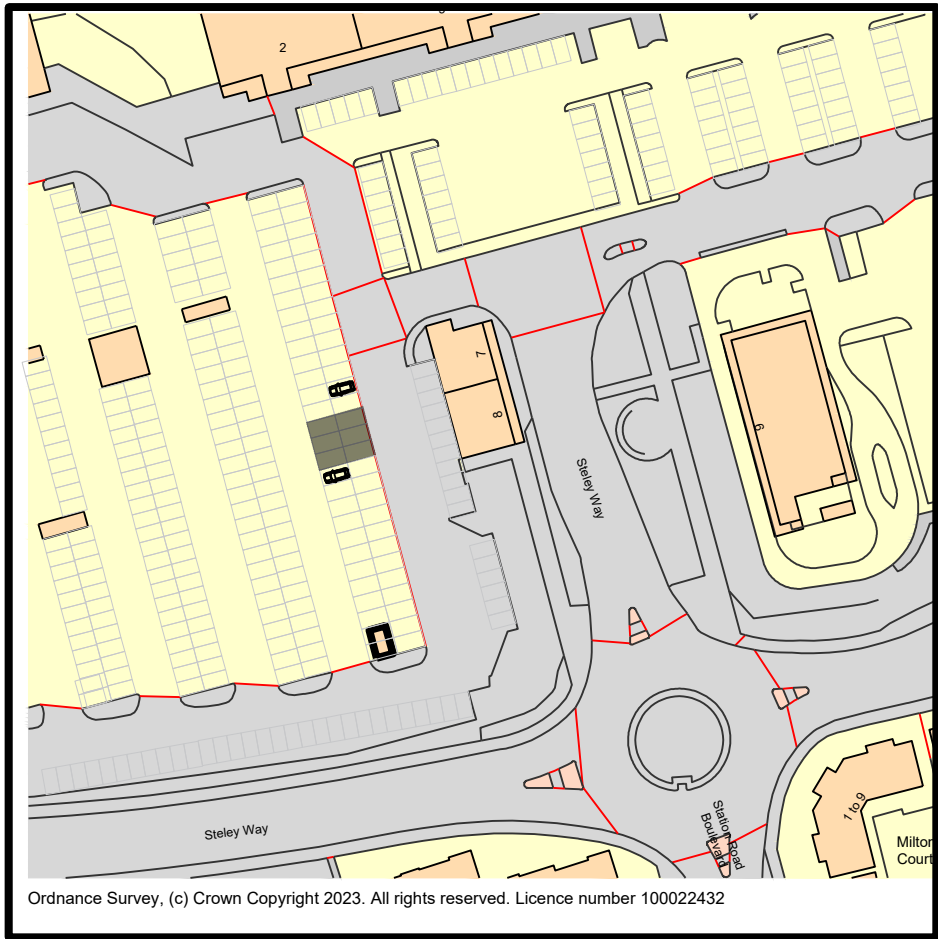

Ordnance Survey Licence Number:
100022432
LOCATION PLAN
Scale 1:1250

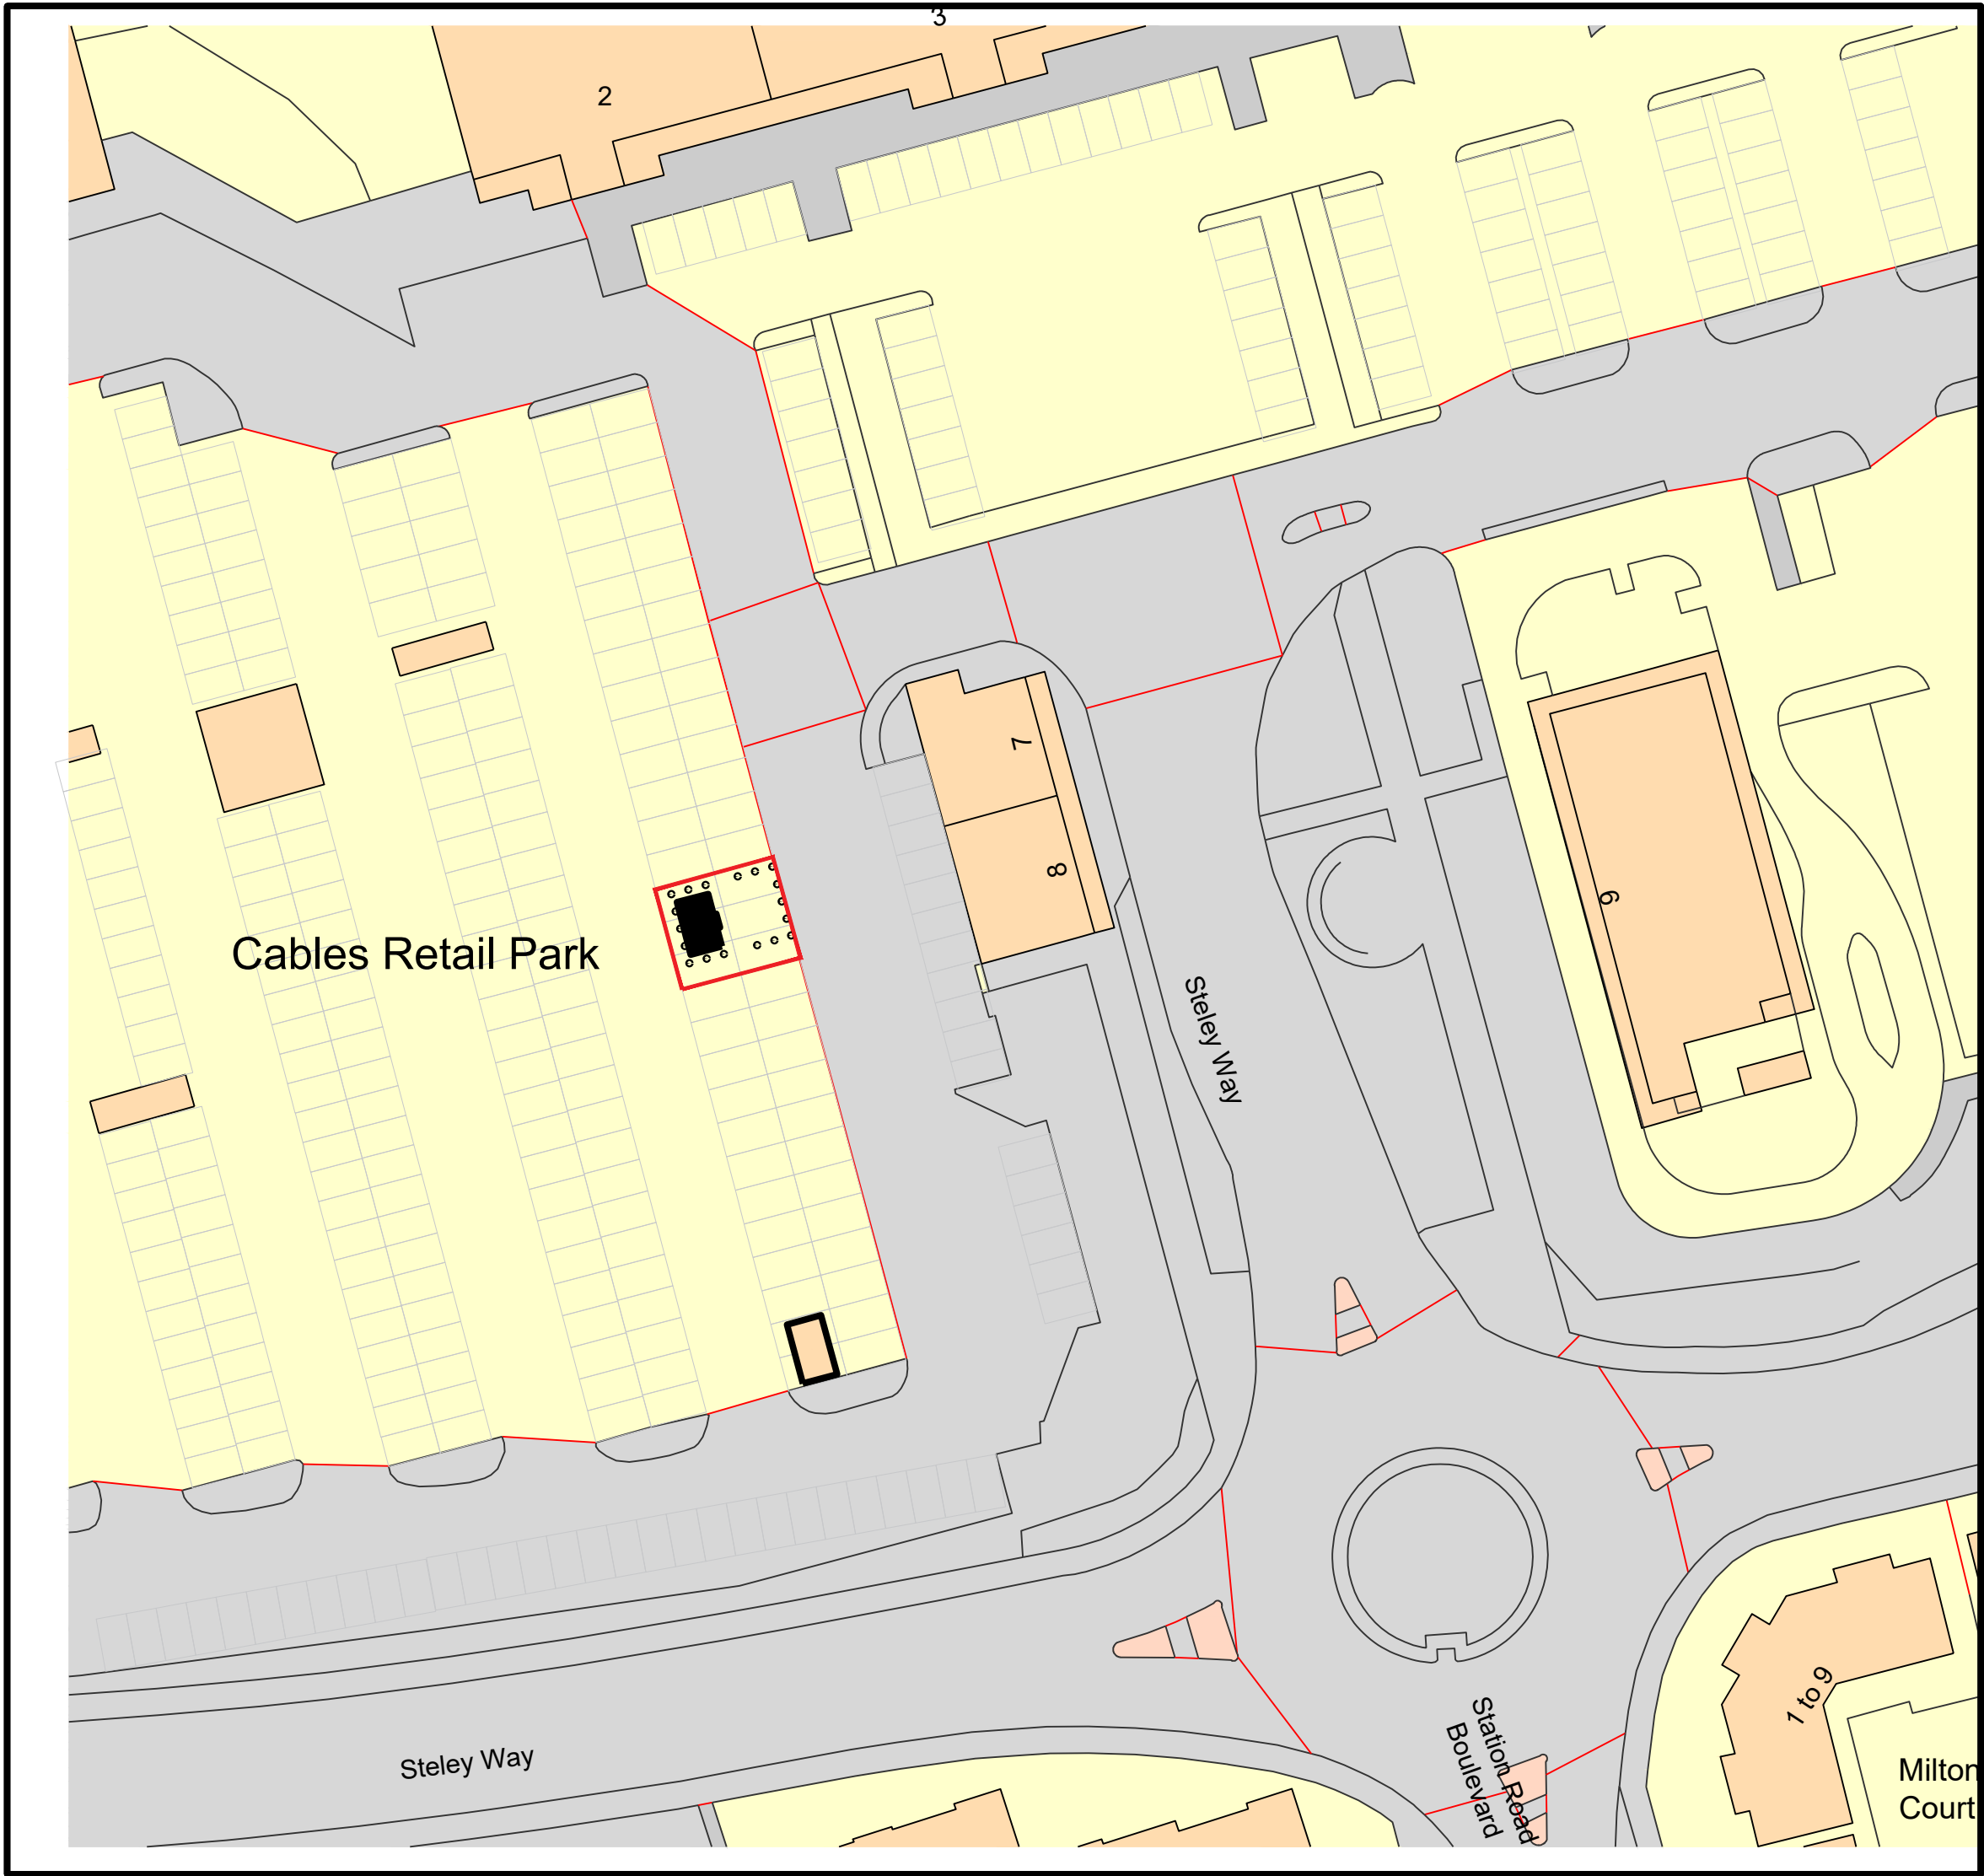

PROPOSED SITE PLAN
Scale 1:500

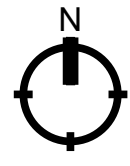

PLANNING

Notes:

Revisions

DATE:	06/11/23	REV:	A	DRAWN:	TM	CHECKED:	DAS
NOTES:	Relocation of POD						
DATE:	05/12/23	REV:	B	DRAWN:	TM	CHECKED:	DAS
NOTES:	Adjustments to site plan						
DATE:		REV:		DRAWN:		CHECKED:	
NOTES:							

Project Ref: N7583

L & H

Architecture

Lewis & Hickey Ltd
2 St. Peter's Gate
Nottingham
NG1 2JG
Tel: 0115 962 9000
Email: nottingham@lewishickey.com

Edinburgh | Guildford | London | Manchester | Nottingham

Project

Mobile Banking POD

Cables Retail Park
Steley Way
Prescot L34 5NQ
PIM NO. -

Drawing Title			
Location Plan/ Site Plan EXISTING/ PROPOSED			
Branch Sort Code	Branch ID	Supplier Project No	
Scale	Drawn	Checked	Date
@A1	TM	DS	12/10/23
Architectural Practice:			REV B
Lewis & Hickey Ltd			