


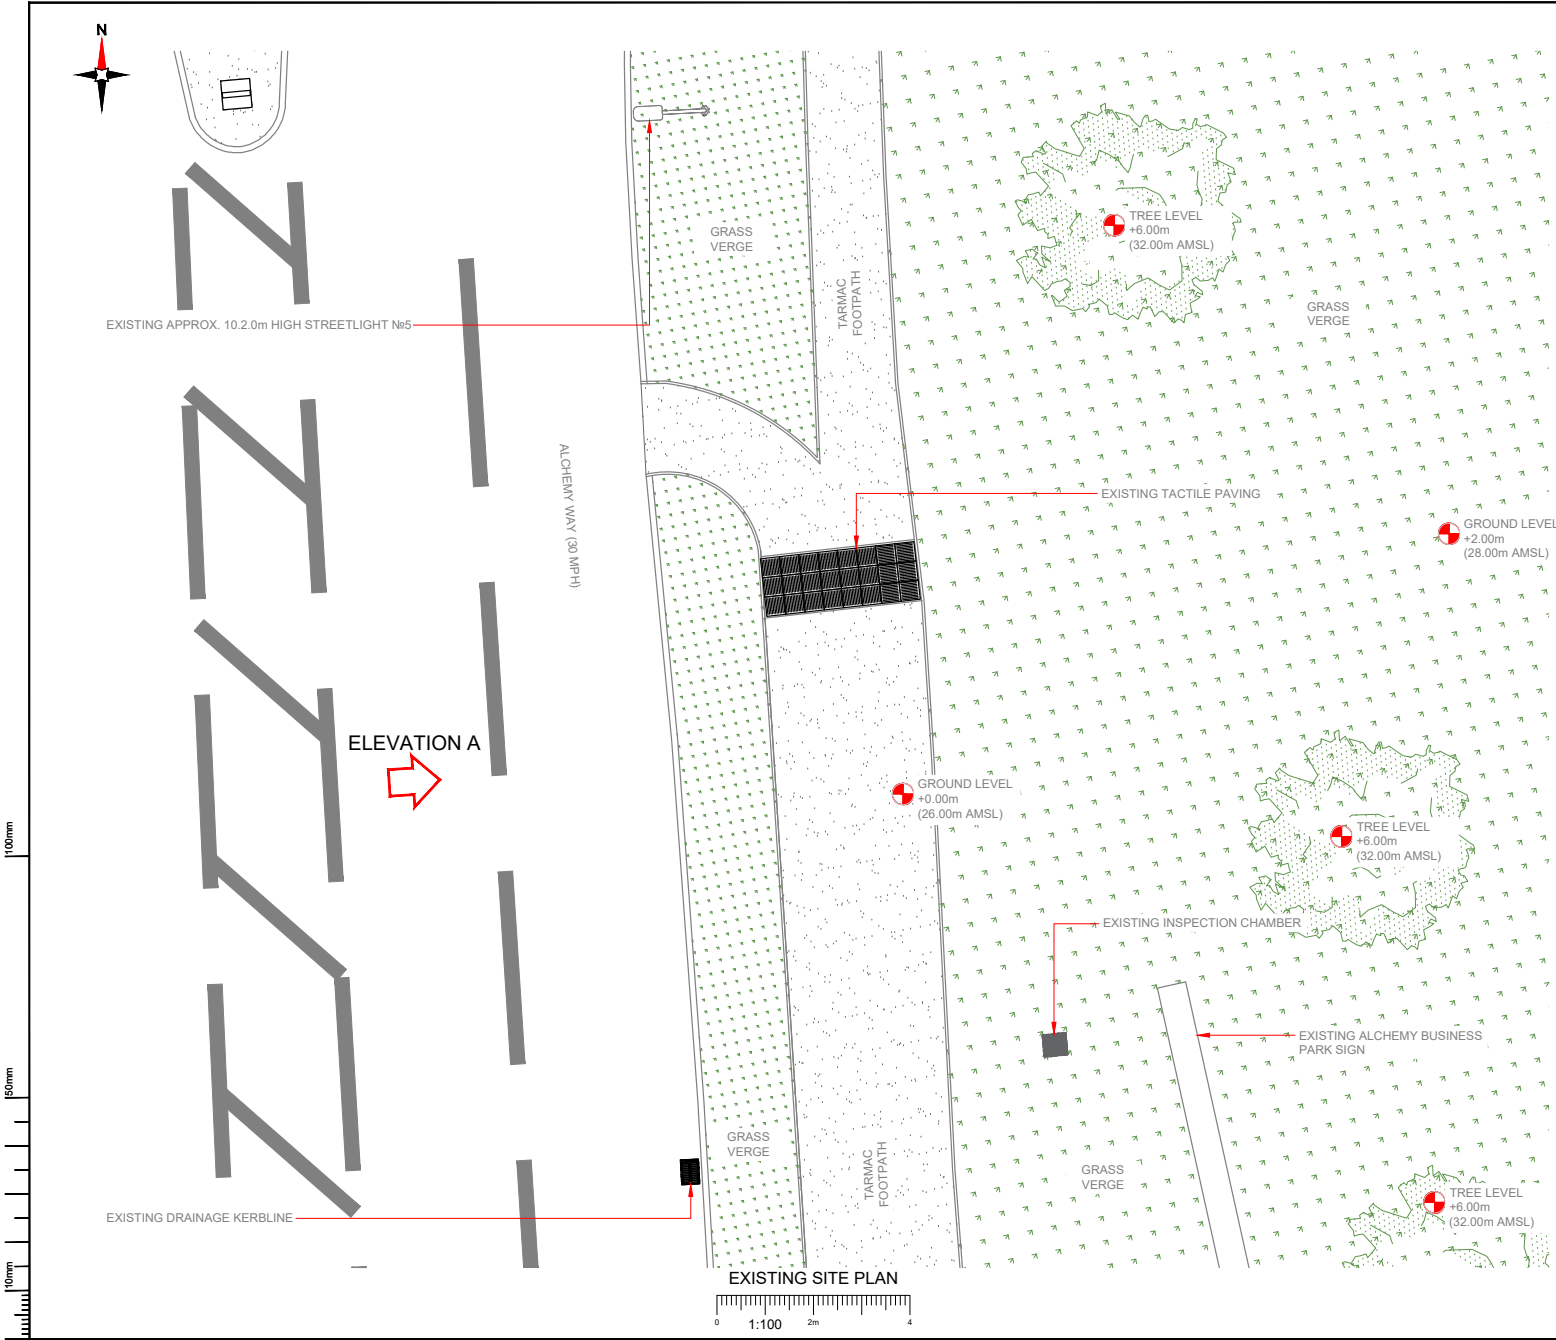

NOTES:
1. ALL DIMENSIONS IN MM UNLESS OTHERWISE NOTED.

Sheet:	M001 (of 1030)	Project:	DENSIFICATION SW	Revision:	Planning	Issue:	A
Date:	25/04/2023	Revision / Update Description:					
Drawn:	A.Lemos	First Issue					
Checked:	G.Thomas						
Approved:	G.Thomas						



Cignal Infrastructure UK Limited (formerly known as CK Hutchison Networks (UK) Limited) (a company registered in England and Wales with company number 12855914) (a Hutchison 3G UK Limited (a company registered in England & Wales with company number 03055486))
Green Park, 450 Longwater Avenue
Reading, RG2 6GF
Tel: 01628 785 000
Fax: 01628 785 001
H3G Base Station Information line:
0845 6043000
Available 8am-8pm Monday to Friday

Design Consultant & Principal Contractor:



Unit E, Madison Place, Northampton Road,
Manchester, M40 5AG
Tel: 0161 785 4500 Fax: 0161 785 4501
Web: www.clarke-telecom.com

Site Name: **ALCHEMY WAY SW'S**

Site ID: **KSY25684**

Address: **ALCHEMY WAY,
KIRKBY,
LIVERPOOL,
MERSEYSIDE
L33 7AH**

Title: **100 EXISTING H3G SITE PLAN**

Project: **H3G DENSIFICATION STREETWORKS**

Purpose of Issue: **PLANNING**


MBNL Cell ID:	SUK Cell ID:
KSY106	L1030

Master Drawing No: **KSY25684_KSY106_L1030_M001_H3G_DNSW_GA_A** Issue: **A**

100mm

50mm

10mm

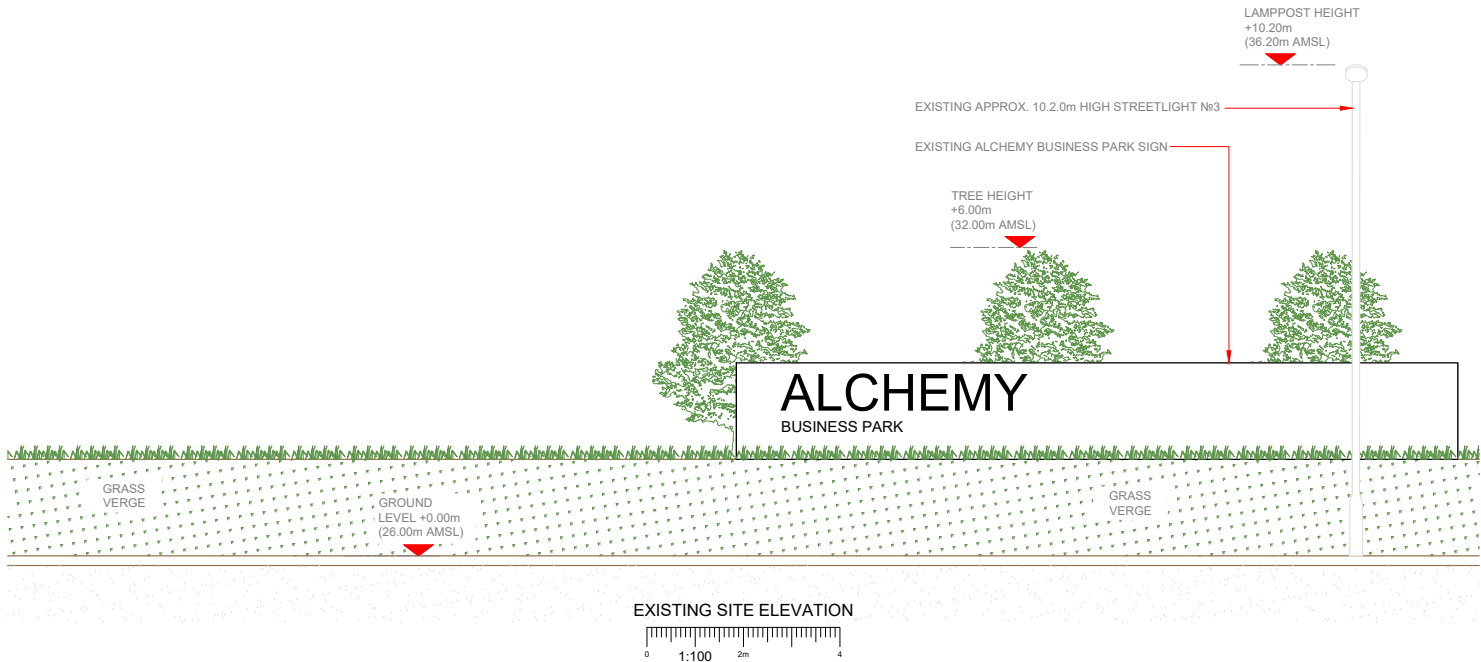

NOTES:
1. ALL DIMENSIONS IN MM UNLESS OTHERWISE NOTED.

Sheet:	MBNL Cell ID:	Project:	Purpose of Issue:	Issue:
M001	H3G	DENSIFICATION SW	Planning	A
Date:	25/04/2023	Revision / Describe Description:		
Drawn:	A.Lemos	First Issue		
Checked:	G.Thomas			
Approved:	G.Thomas			



Signal Infrastructure UK Limited (formerly known as CK Hutchison Networks (UK) Limited) (a company registered in England and Wales with company number 1286914) (a company registered in England & Wales with company number 03055486)
Green Park, 450 Longwater Avenue
Reading, RG2 6GF
Tel: 01628 765 000
Fax: 01628 765 001
H3G Base Station Information line: 0845 6043000
Available 8am-8pm Monday to Friday

Design Consultant & Principal Contractor:



Unit E, Madison Place, Northampton Road,
Manchester, M40 5AG
Tel: 0161 785 4500 Fax: 0161 785 4501
Web: www.clarke-telecom.com

Site Name: ALCHEMY WAY SW'S

Site ID: KSY25684

Address: ALCHEMY WAY,
KIRKBY,
LIVERPOOL,
MERSEYSIDE
L33 7AH

Title: 150 EXISTING H3G ELEVATION A


Project: H3G DENSIFICATION STREETWORKS


Purpose of Issue: PLANNING

MBNL Cell ID:	SUK Cell ID:
KSY106	L1030

Master Drawing No: KSY25684_KSY106_L1030_M001_H3G_DNSW_GA_A

Issue: A

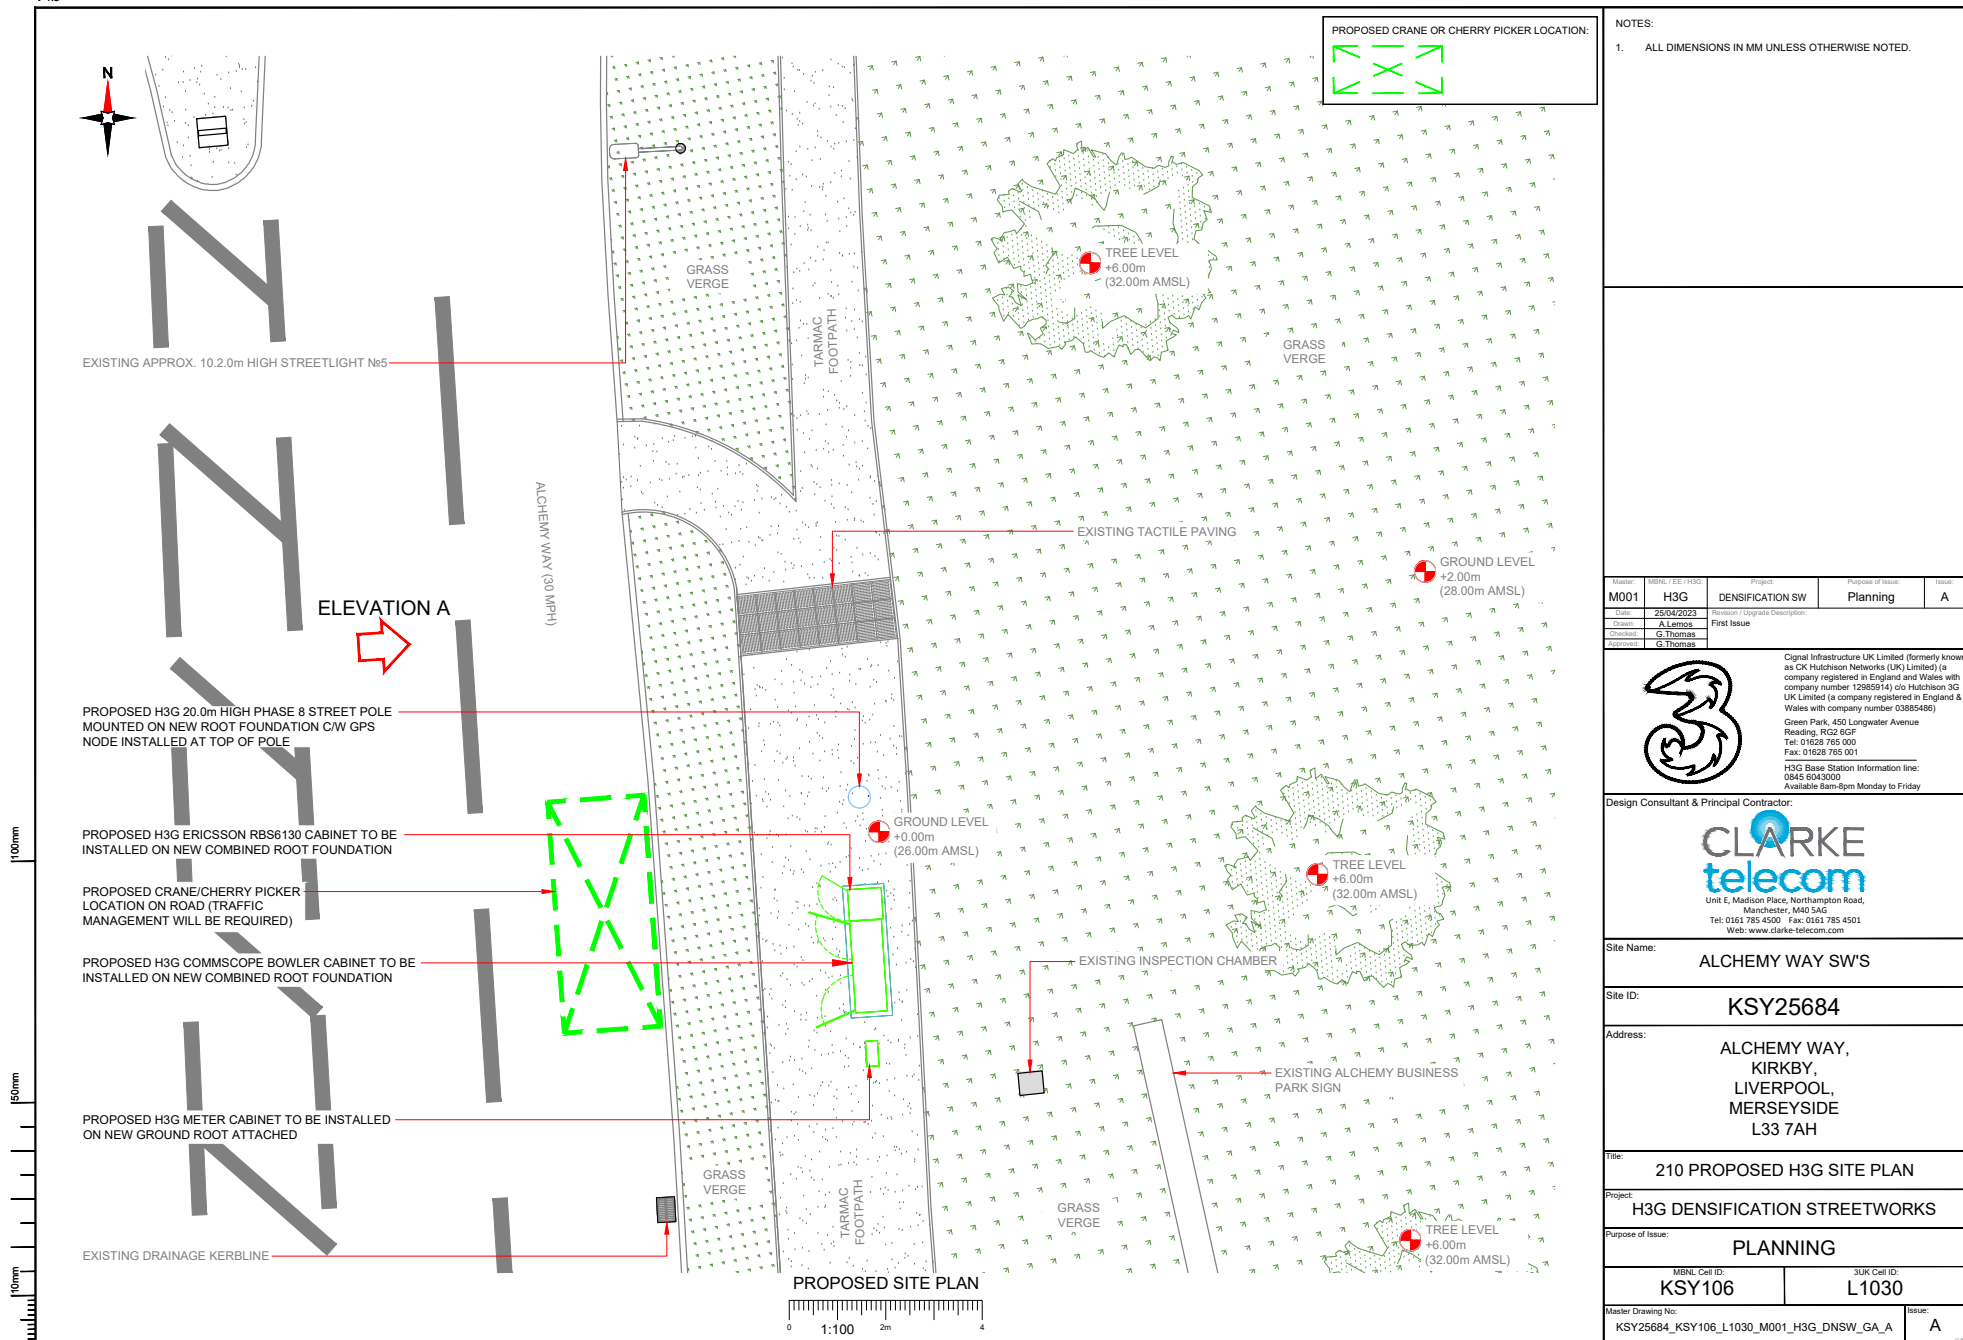

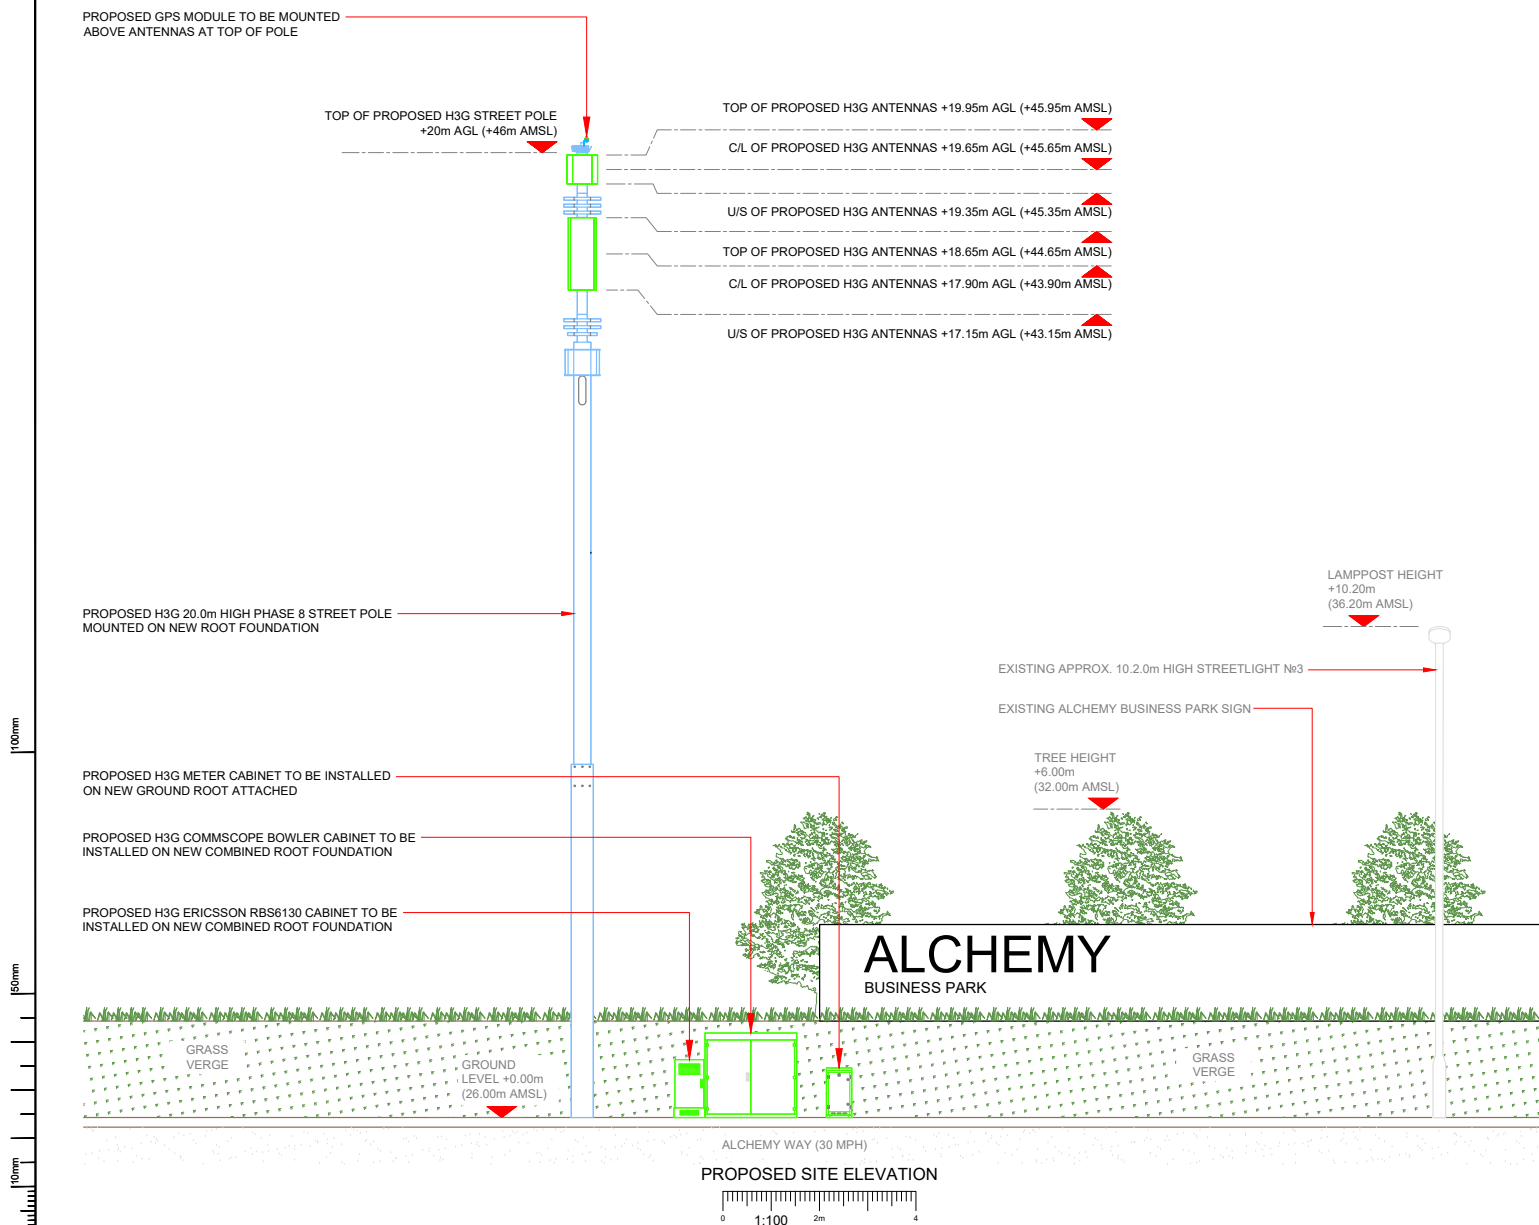

NOTES:

- ALL DIMENSIONS IN MM UNLESS OTHERWISE NOTED.

Sheet	Model	Project	Project of Issue	Issue
M001	H3G	DENSIFICATION SW	Planning	A
Date	25/04/2023	Revision / Update Description:		
Drawn	A.Lemos	First Issue		
Checked	G.Thomas			
Approved	G.Thomas			

3

Cignal Infrastructure UK Limited (formerly known as CK Hutchison Networks (UK) Limited) (a company registered in England and Wales with company number 12855914) (a company registered in England and Wales with company number 03055486)

Green Park, 450 Longwater Avenue
Reading, RG2 6GF
Tel: 01628 785 000
Fax: 01628 785 001

H3G Base Station Information line:
0845 6043000
Available 8am-8pm Monday to Friday

Design Consultant & Principal Contractor:

CLARKE telecom

Unit E, Madison Place, Northampton Road,
Manchester, M40 5AG
Tel: 0161 785 4500 Fax: 0161 785 4501
Web: www.clarke-telecom.com

Site Name: ALCHEMY WAY SW'S

Site ID: KSY25684

Address: ALCHEMY WAY,
KIRKBY,
LIVERPOOL,
MERSEYSIDE
L33 7AH

Title: 260 PROPOSED H3G ELEVATION A

Project: H3G DENSIFICATION STREETWORKS

Purpose of Issue: PLANNING

MBNL Cell ID:	3UK Cell ID:
KSY106	L1030

Master Drawing No: KSY25684_KSY106_L1030_M001_H3G_DNSW_GA_A

Issue: A