
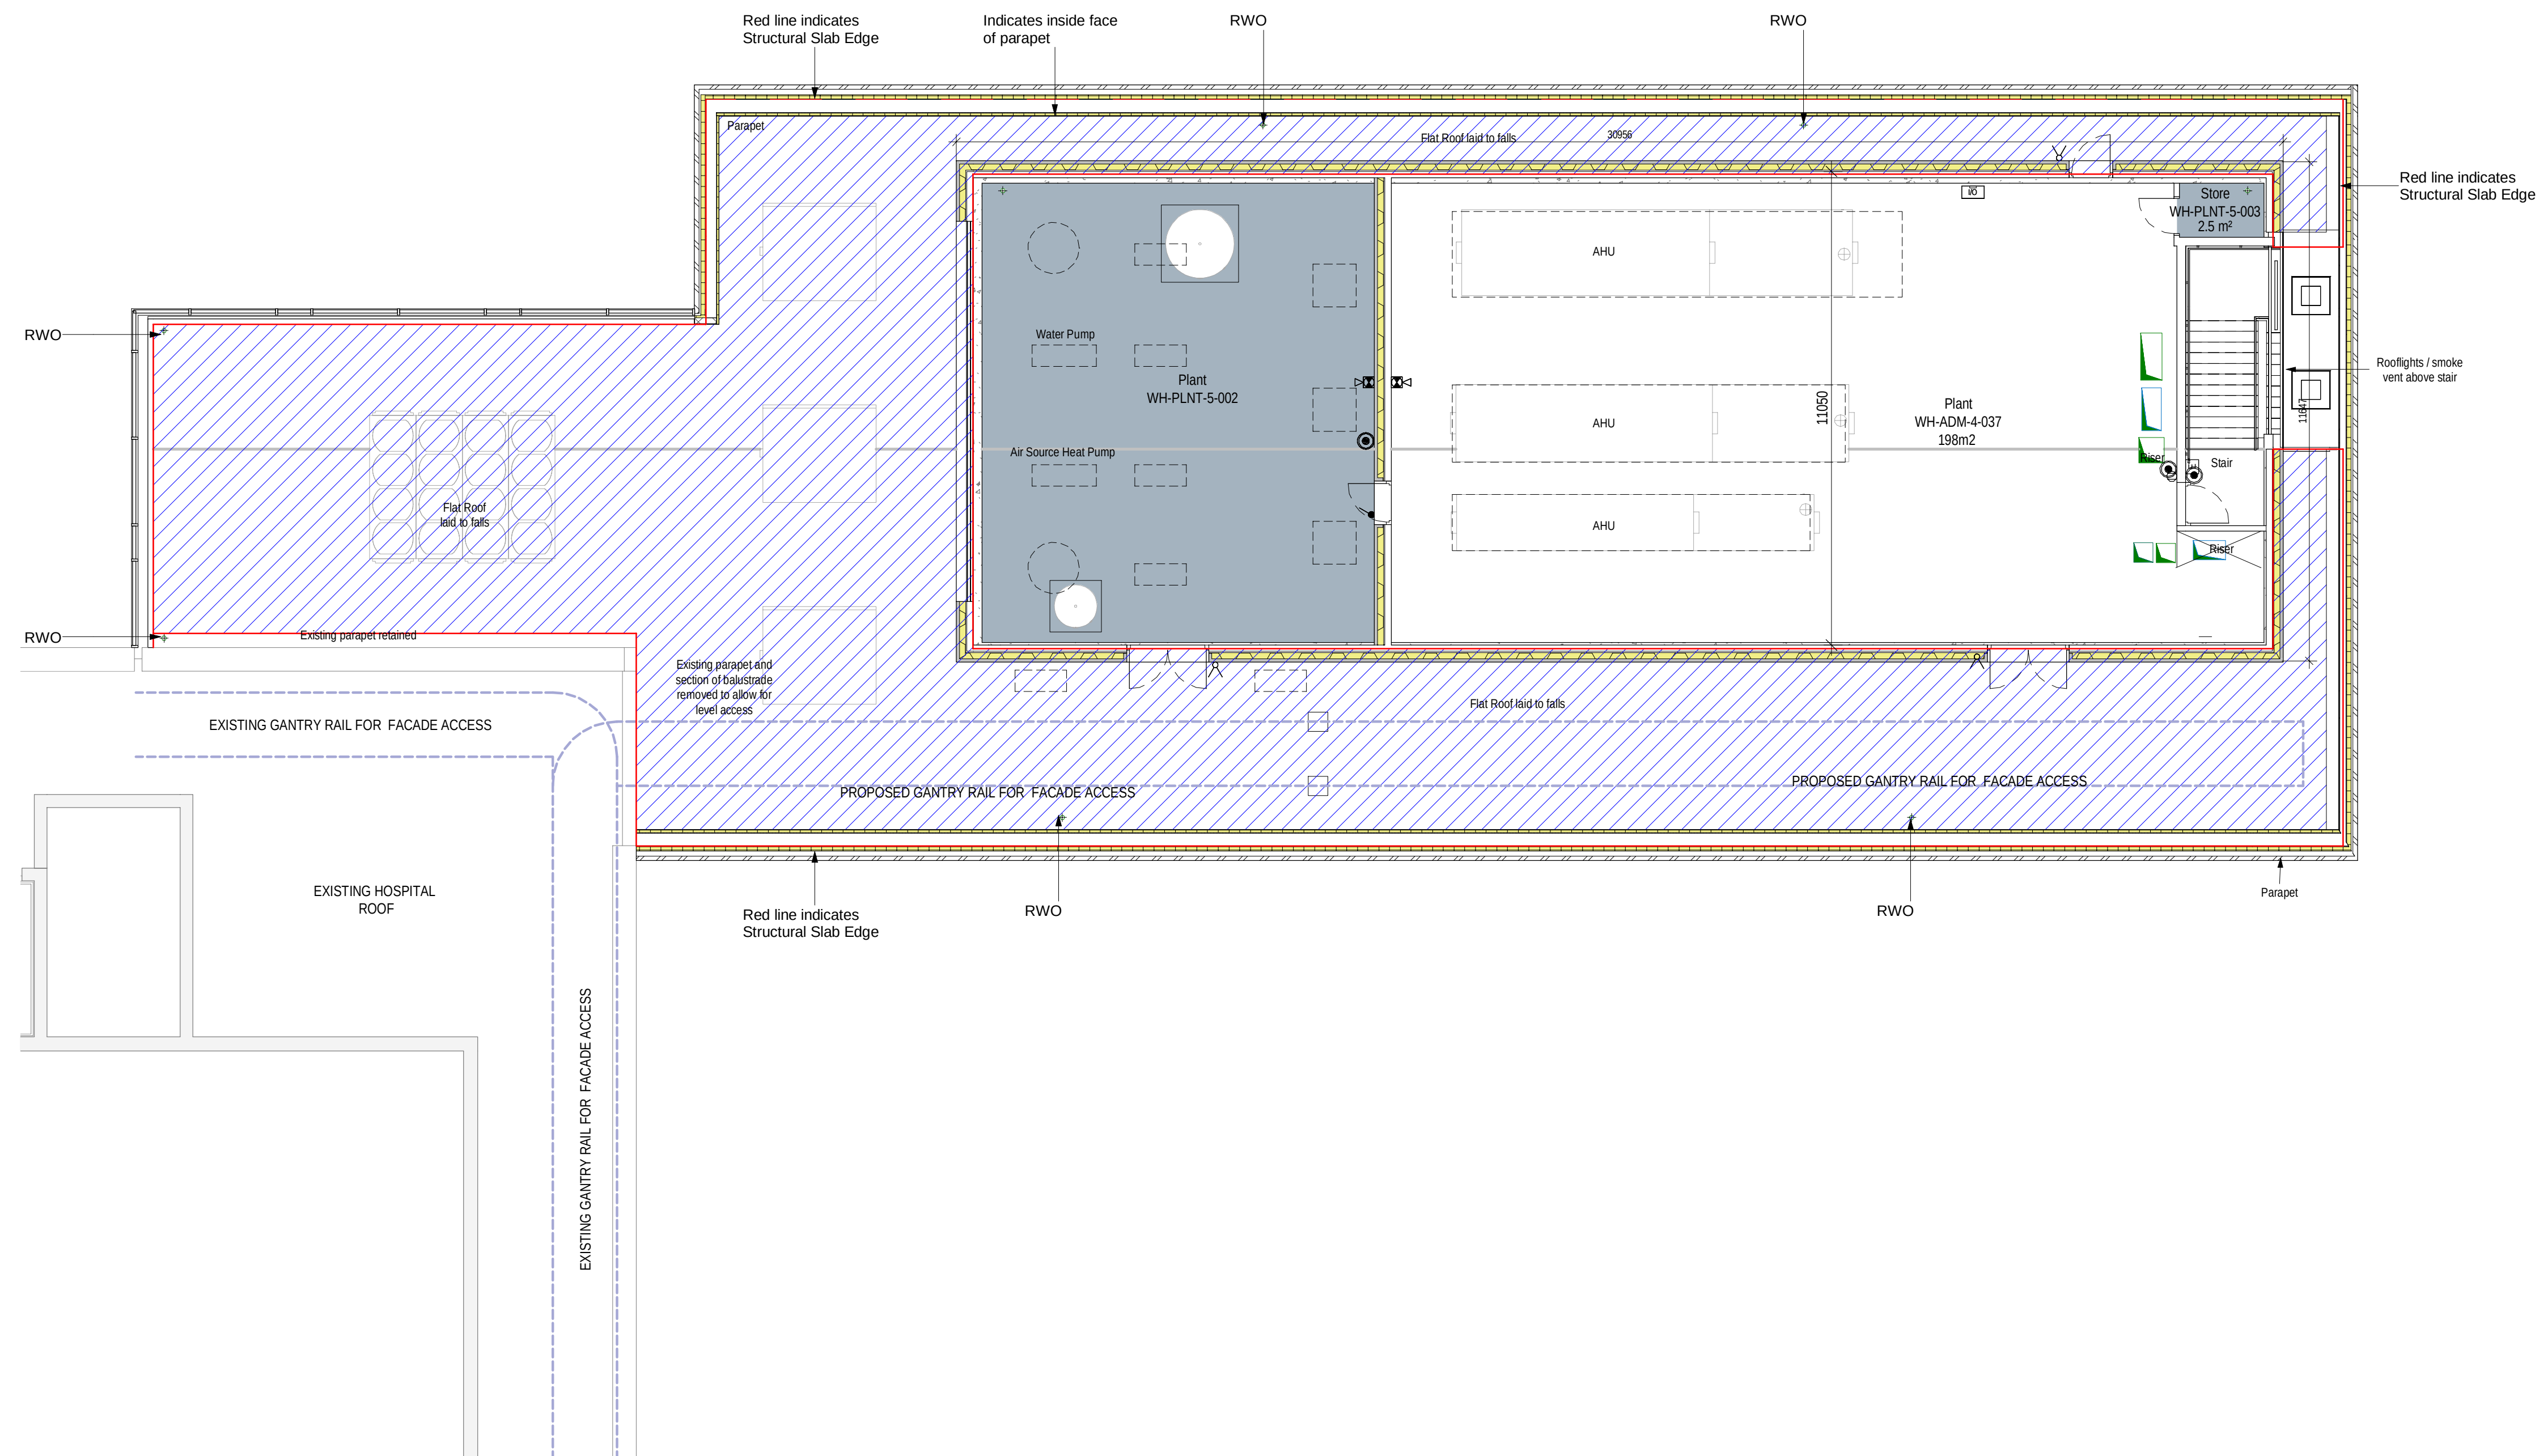


© Copyright: All rights reserved. This drawing must not be reproduced without permission.
Do not scale from this drawing. All dimensions are in millimetres unless otherwise stated.
Any discrepancies should be reported to the Architect.

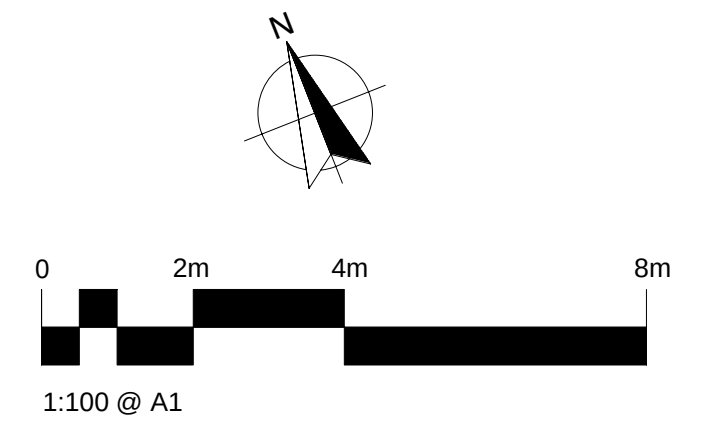

Level 5 GA

1 : 100 @ A1

F	Scale Bar and North Arrow added.	25.04.23	PC	TM
E	Stage 3 issued for information	13.10.22	TM	OC
D	Plan footprint increased and revised inline with clients comments.	19.05.22	CB	TM
C	Plan updated in line with client comments.	12.01.22	CB	TM
B	Plan updated with room & door numbers.	14.12.21	CB	TM
-	First issue. For Comment/Approval.	-	-	-
PRELIMINARY				
Revision	Description	Date	Drawn	Checked

Halliday Meecham Architects Limited

111 Piccadilly Manchester M1 2HY
+44 (0)161 661 5566

4 Devonshire Street London W1W 5DT
+44 (0)203 440 5175

hma@hallidaymeecham.com
www.hallidaymeecham.com



Client:		Vinci			
Project:		Endoscopy Suite Extension			
Phase/ Location:		Whiston Hospital, Warrington Rd, Prescott, L35 5DR			
Drawing:		Proposed Level 05 Floor Plan			
Scale @ A1	Scale @ A3	Date:	Drawn:	Checked:	Job No.
1:50	1:100	17.10.21	CB	TM	5293
Drawing Ref.					00206
5293-HMA-ES-L5-A-00206					Revision E