
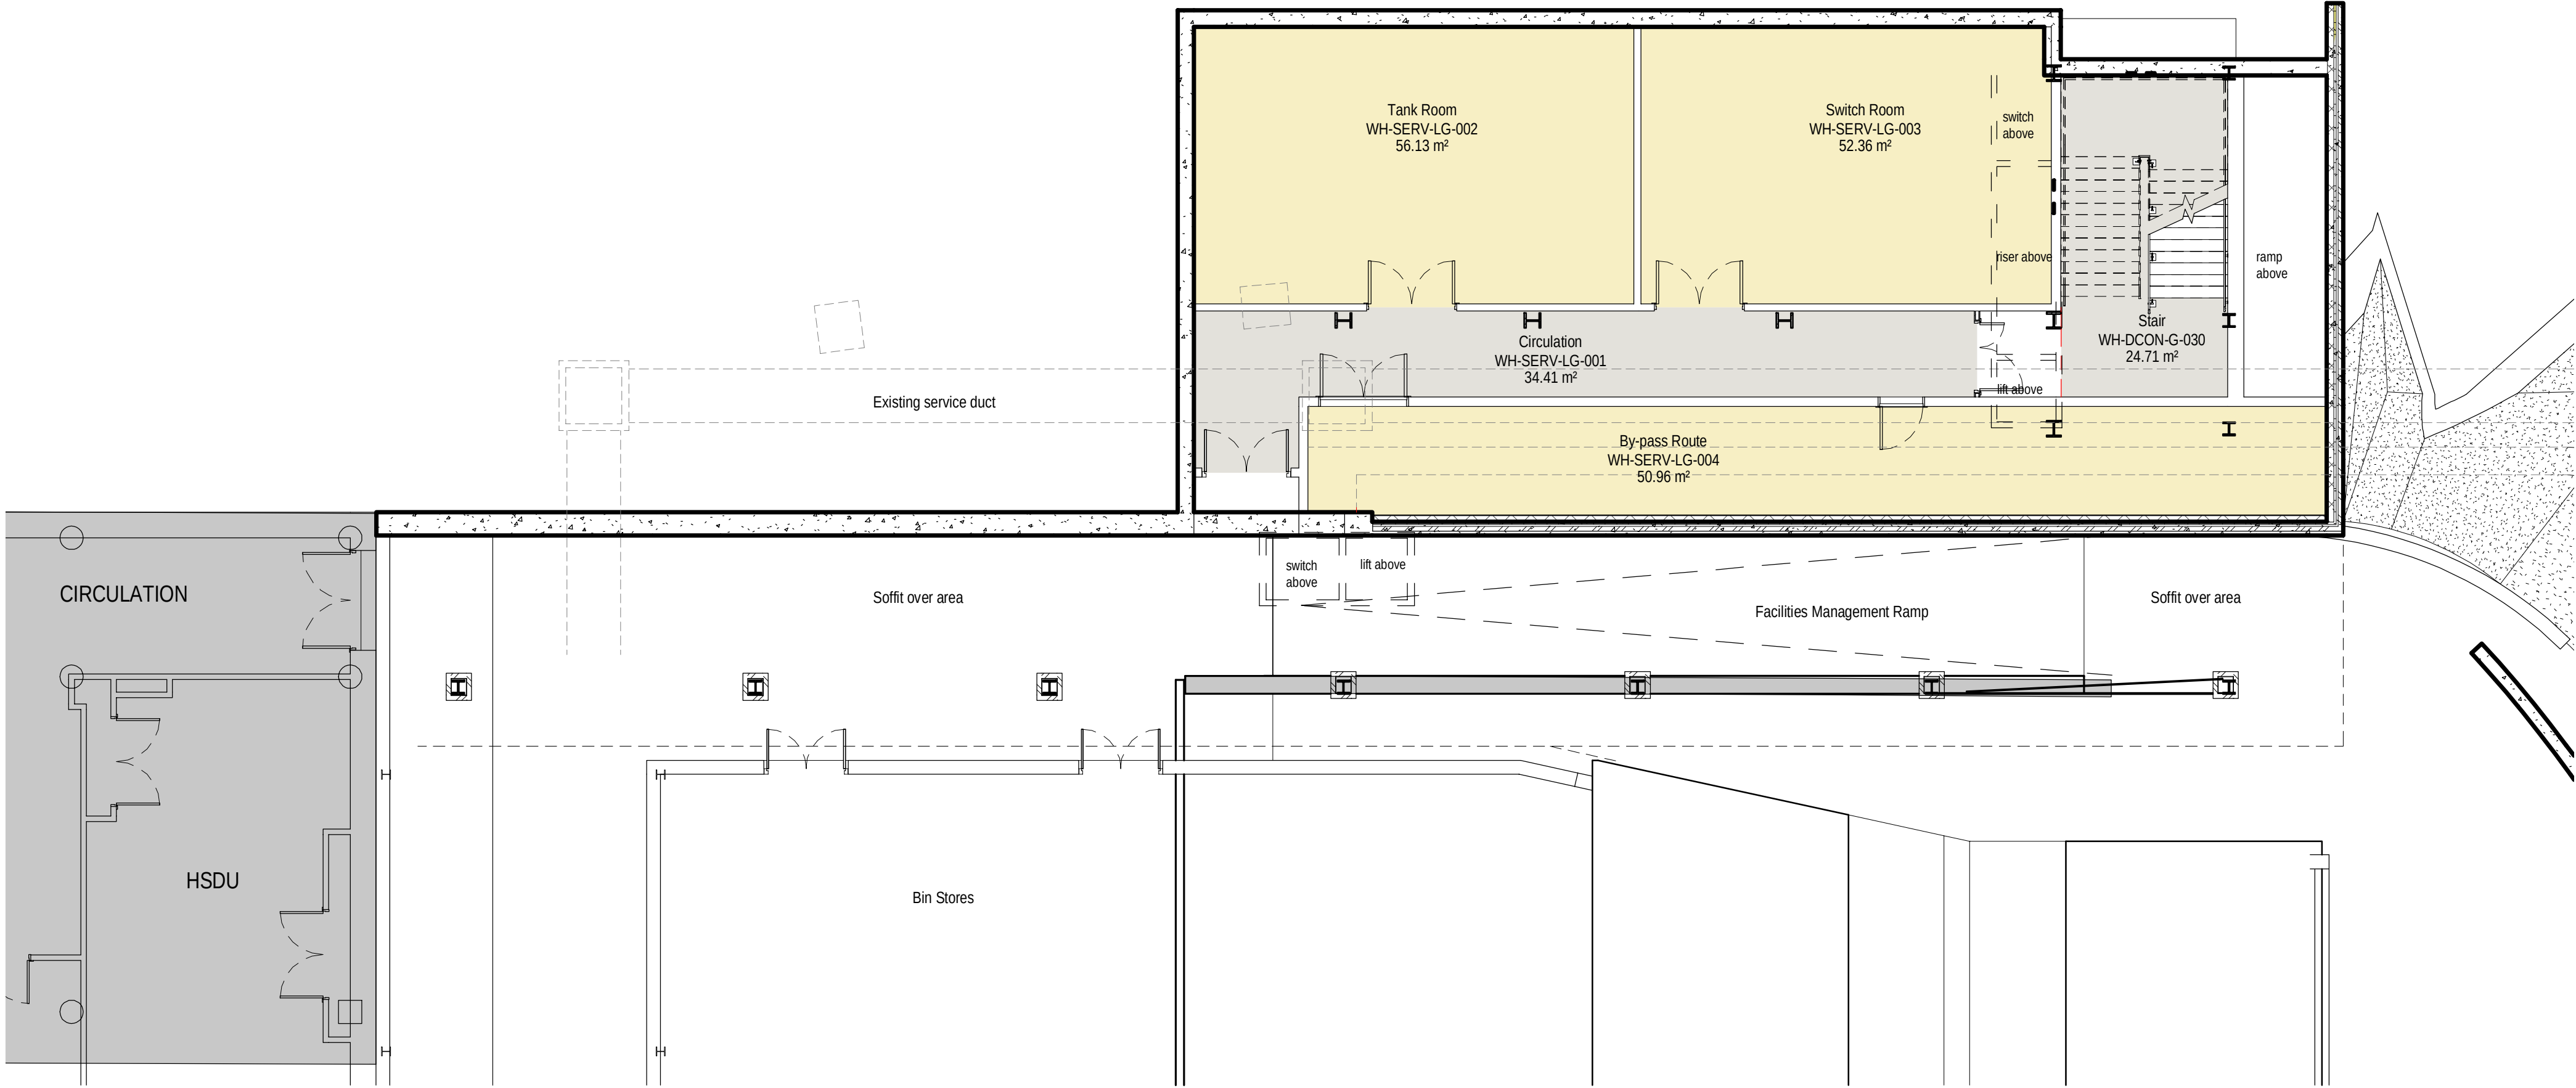


© Copyright: All rights reserved. This drawing must not be reproduced without permission.
Do not scale from this drawing. All dimensions are in millimetres unless otherwise stated.
Any discrepancies should be reported to the Architect.

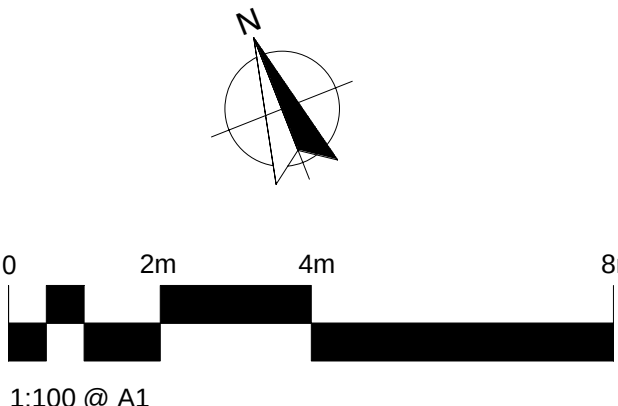

Level LG GA
1 : 100 @ A1

E	Scale Bar and North Arrow added.	24.04.23	PC	TM
D	Stage 3 issued for information	13.10.22	TM	OC
C	Plan footprint increased and revised inline with clients comments.	19.05.22	CB	TM
B	Plan updated with room & door numbers.	14.12.21	CB	TM
A	Plan updated with client comments. Room and door numbers added.	09.12.21	CB	TM
-	First issue. For Comment/Approval.	-	-	-
PRELIMINARY				
Revision	Description	Date	Drawn	Checked

Halliday Meecham Architects Limited

111 Piccadilly Manchester M1 2HY
+44 (0)161 661 5566

4 Devonshire Street London W1W 5DT
+44 (0)203 440 5175

hma@hallidaymeecham.com
www.hallidaymeecham.com



Client:		Vinci				
Project:		Endoscopy Suite Extension				
Phase/ Location:		Whiston Hospital, Warrington Rd, Prescot, L35 5DR				
Drawing:		Proposed Lower Ground Floor Plan				
Scale @ A1	Scale @ A3	Date:	Drawn:	Checked:	Job No.	Drawing No.
1:100	1:200	17.10.21	CB	TM	5293	00201
Drawing Ref.						Revision
5293-HMA-ES-LG-DR-A-00201						E