
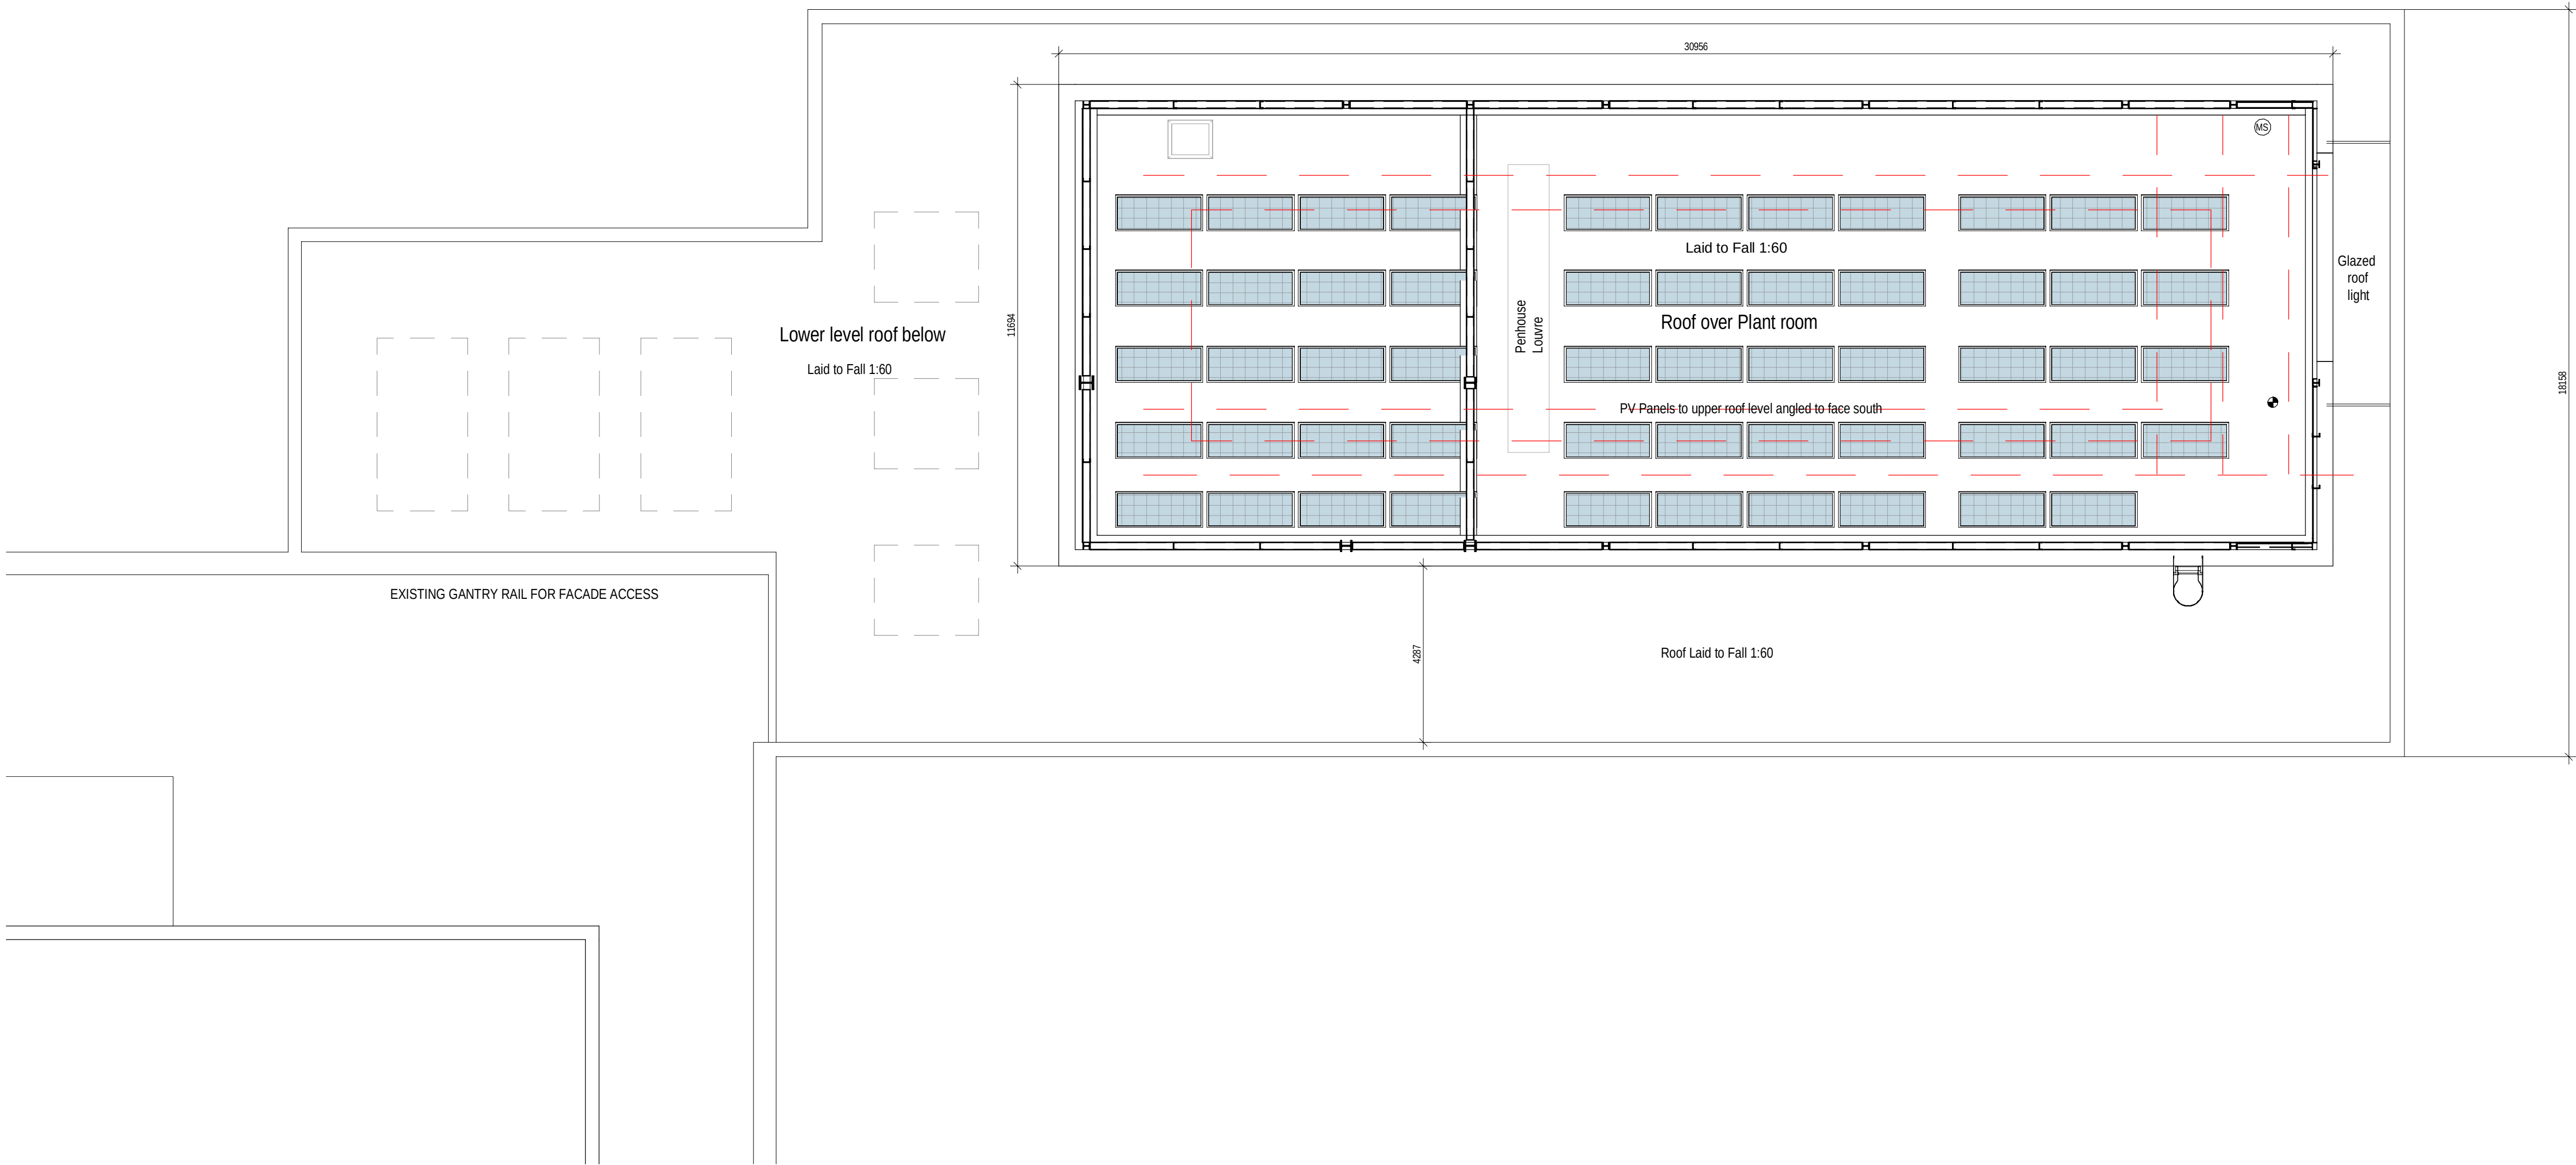


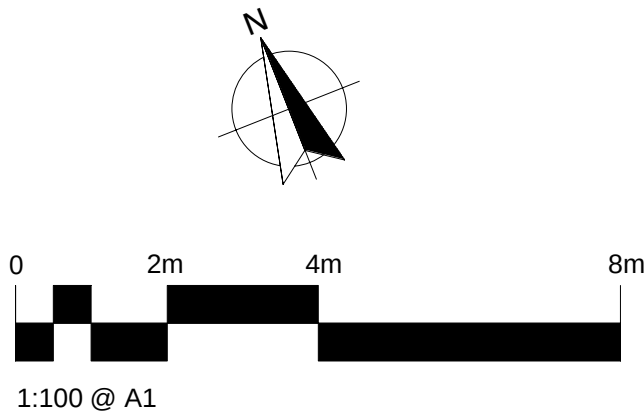

Level RF GA
1 : 100 @ A1

E	Scale Bar and North Arrow added.	24.04.23	PC	TM
D	Stage 3 issued for information	13.10.22	TM	OC
C	Plan footprint increased and revised inline with clients comments.	19.05.22	CB	TM
B	Plan updated in line with client comments.	12.01.22	CB	TM
-	First issue. For Comment/Approval.	-	-	-
PRELIMINARY				
Revision	Description	Date	Drawn	Checked

Halliday Meecham Architects Limited

111 Piccadilly Manchester M1 2HY
+44 (0)161 661 5566

4 Devonshire Street London W1W 5DT
+44 (0)203 440 5175

hma@hallidaymeecham.com
www.hallidaymeecham.com



Client:	Vinci					
Project:	Endoscopy Suite Extension					
Phase/ Location:	Whiston Hospital, Warrington Rd, Prescott, L35 5DR					
Drawing:	Proposed Roof Plan					
Scale @ A1	Scale @ A3	Date:	Drawn:	Checked:	Job No.	Drawing No.
1:100	1:200	17.10.21	CB	TM	5293	00207
Drawing Ref. 5293-HMA-ES-RF-DR-A-00207						
Revision E						