


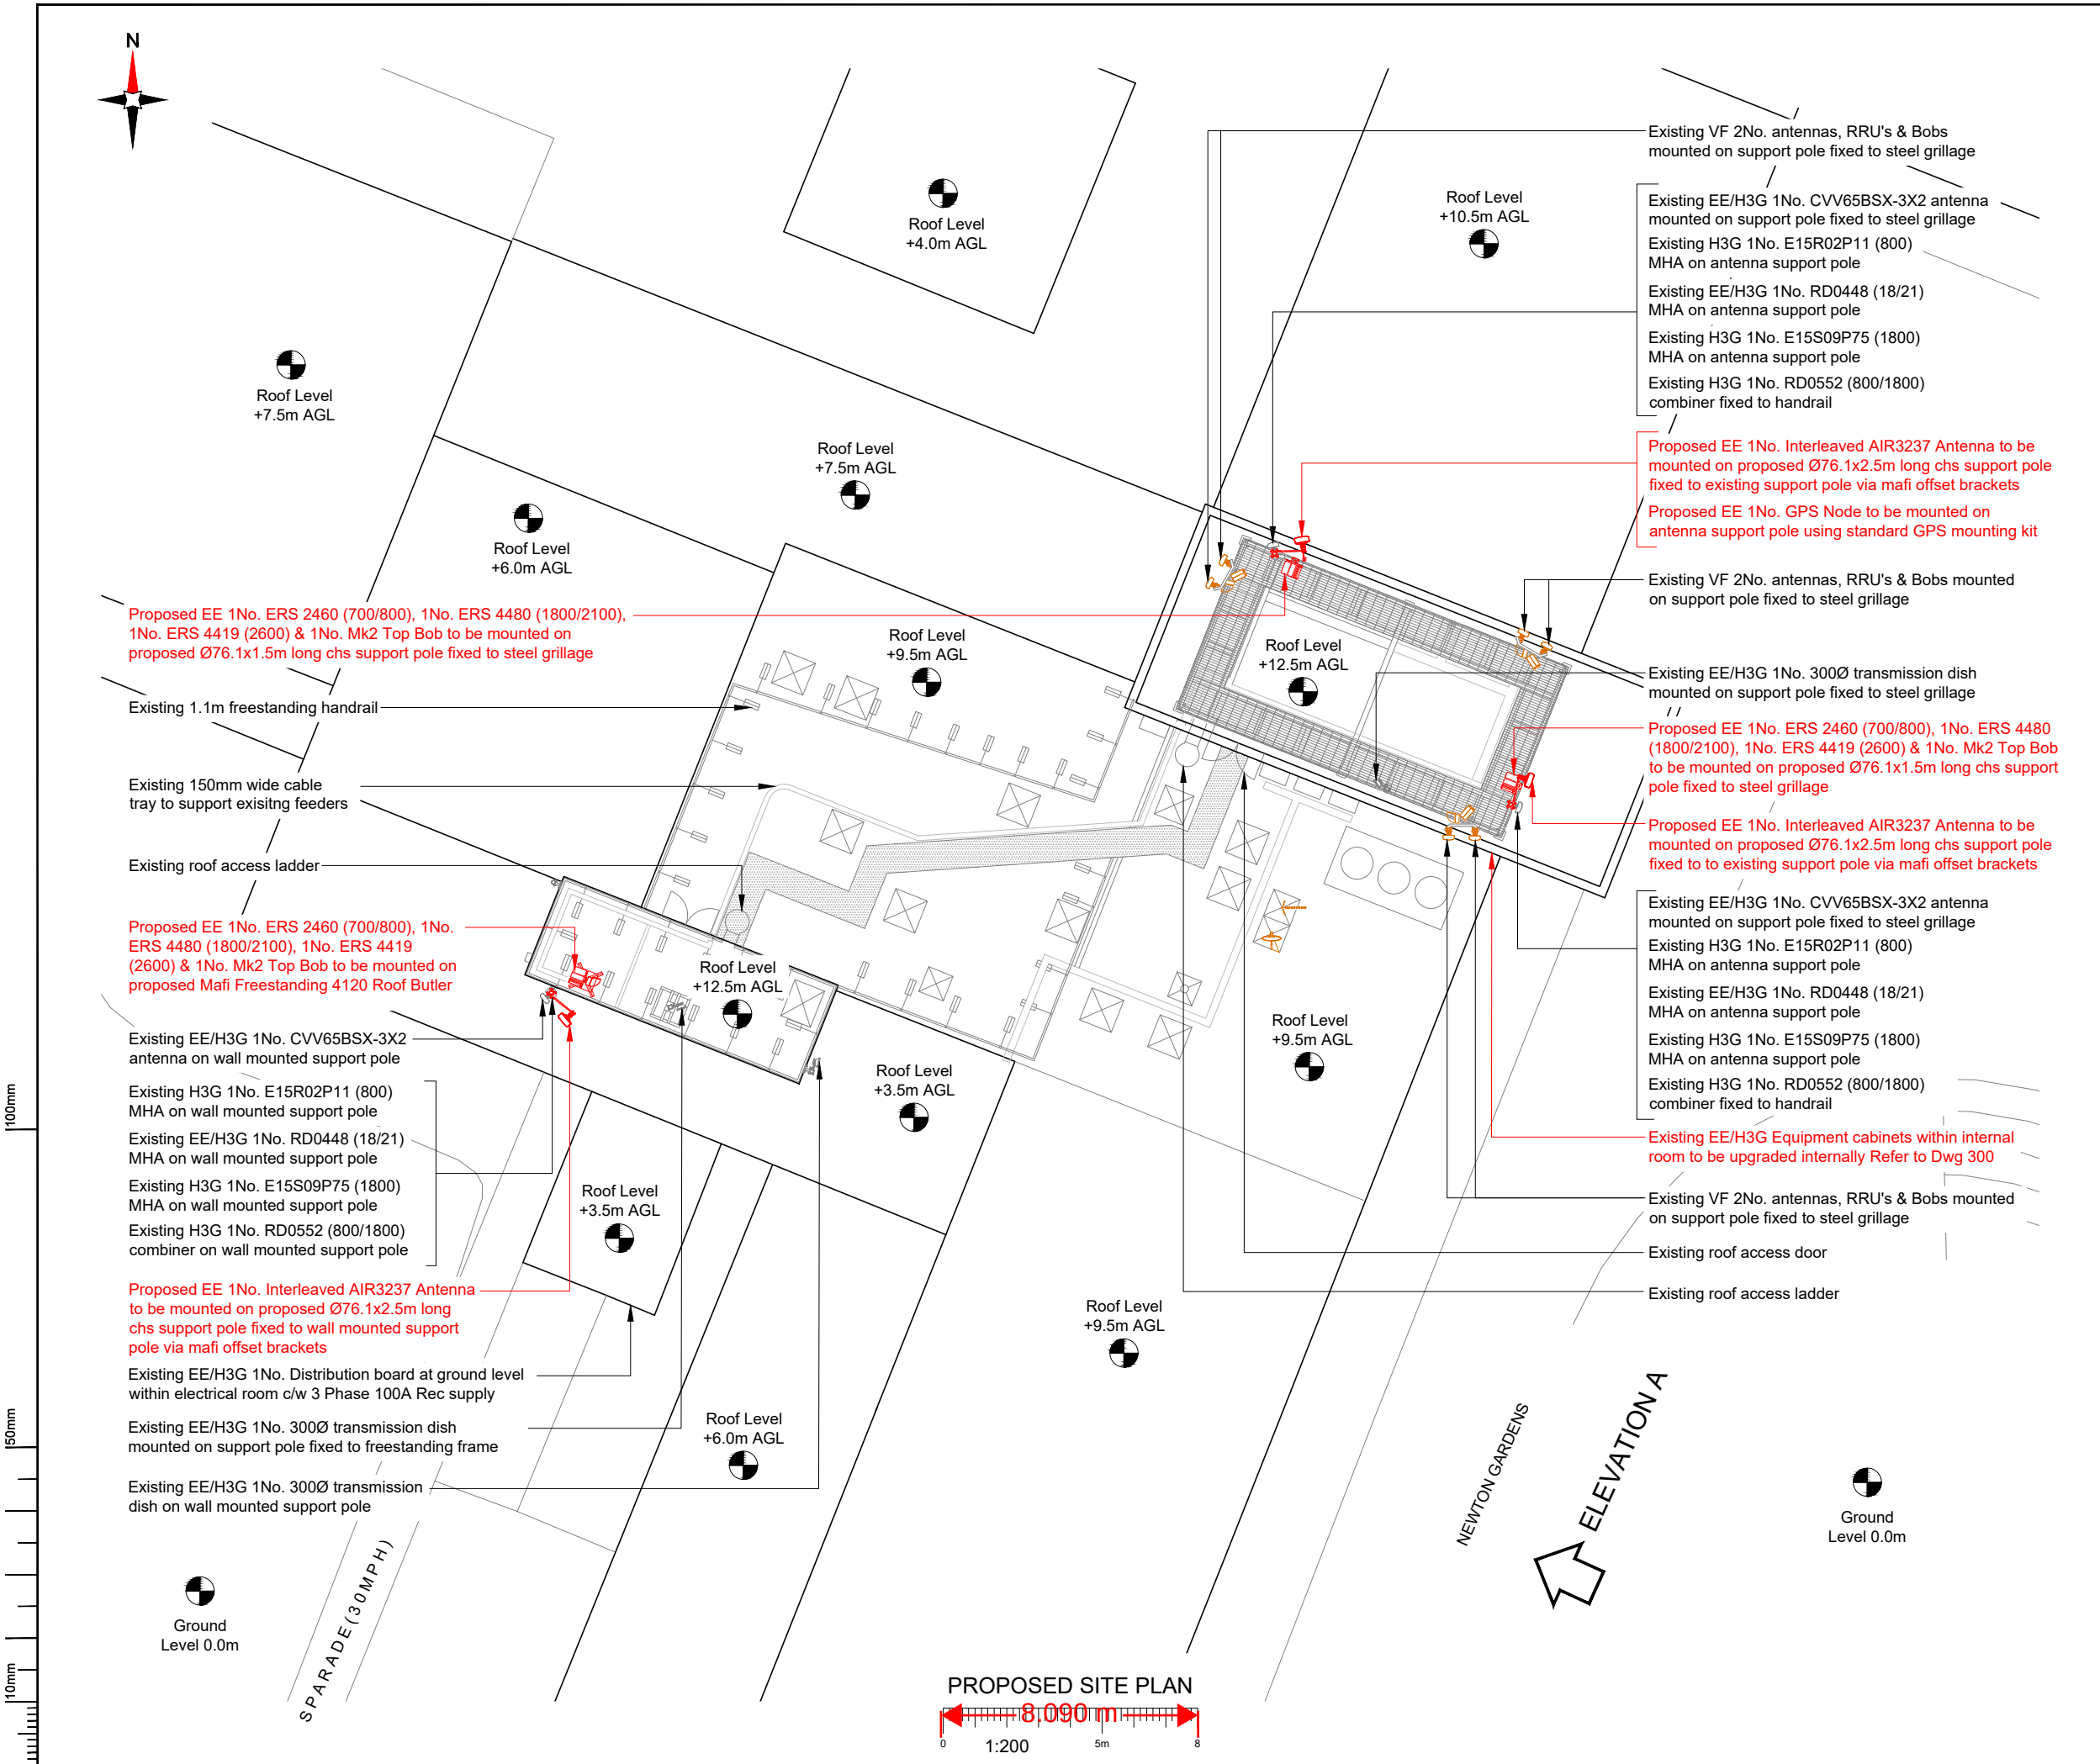

NOTES:

1. ALL DIMENSIONS IN MM UNLESS OTHERWISE NOTED.

Note;
All existing fibre / feeder cables to be re-used. Subject to testing. Un-used feeder cables to be removed

Master:	MBNL / EE / H3G:	Project:	Purpose of Issue:	Issue:
M002	EE	VENDOR SWAP	General Arrangement	B
Date:	14/08/2023	Revision / Upgrade Description:		
Drawn:	CF	E/// Rejection Comments Addressed - Antenna name revised, FL		
Checked:	CF	FIXIT raised, BBU weight revised		
Approved:	CF			
Master:	MBNL / EE / H3G:	Project:	Purpose of Issue:	Issue:
M001	EE	VENDOR SWAP	General Arrangement	A
Date:	31/07/2023	Revision / Upgrade Description:		
Drawn:	GS	First Issue		
Checked:	JC			
Approved:	CF			



Hatfield Business Park
Hatfield
Hertfordshire
AL10 9BW

Tel: 01707 315000
Fax: 01707 319001

Design Consultant & Principal Contractor:



Unit 27F-G
Hartlebury Trading Estate
Crown Lane
Hartlebury
Worcestershire
DY10 4JD

Site Name: KIRKBY SHOPPING CENTRE

Site ID: 1167420

Address: ST CHADS PARADE
KIRKBY
LIVERPOOL
MERSEYSIDE
L32 8RD

Title: 150 PROPOSED SITE PLAN

Project: VENDOR SWAP

Purpose of Issue: GENERAL ARRANGEMENT

EE Cell ID:	MBNL Cell ID:	3UK Cell ID:
28002	KSY046	L0306

Master Drawing No:	Issue:
1167420_KSY046_28002_L0306_M002	B