



EV Charge Point Schedule		
7.4 kW EV Charge Parking Bays		
EV Parking	Quantity	Unit 03
EV Car Parking Bays	54	
Disabled EV Car Parking Bays	2	
Total EV Parking Bays	56	



7.4kW Type 2 Mode 3
EV Charge Point

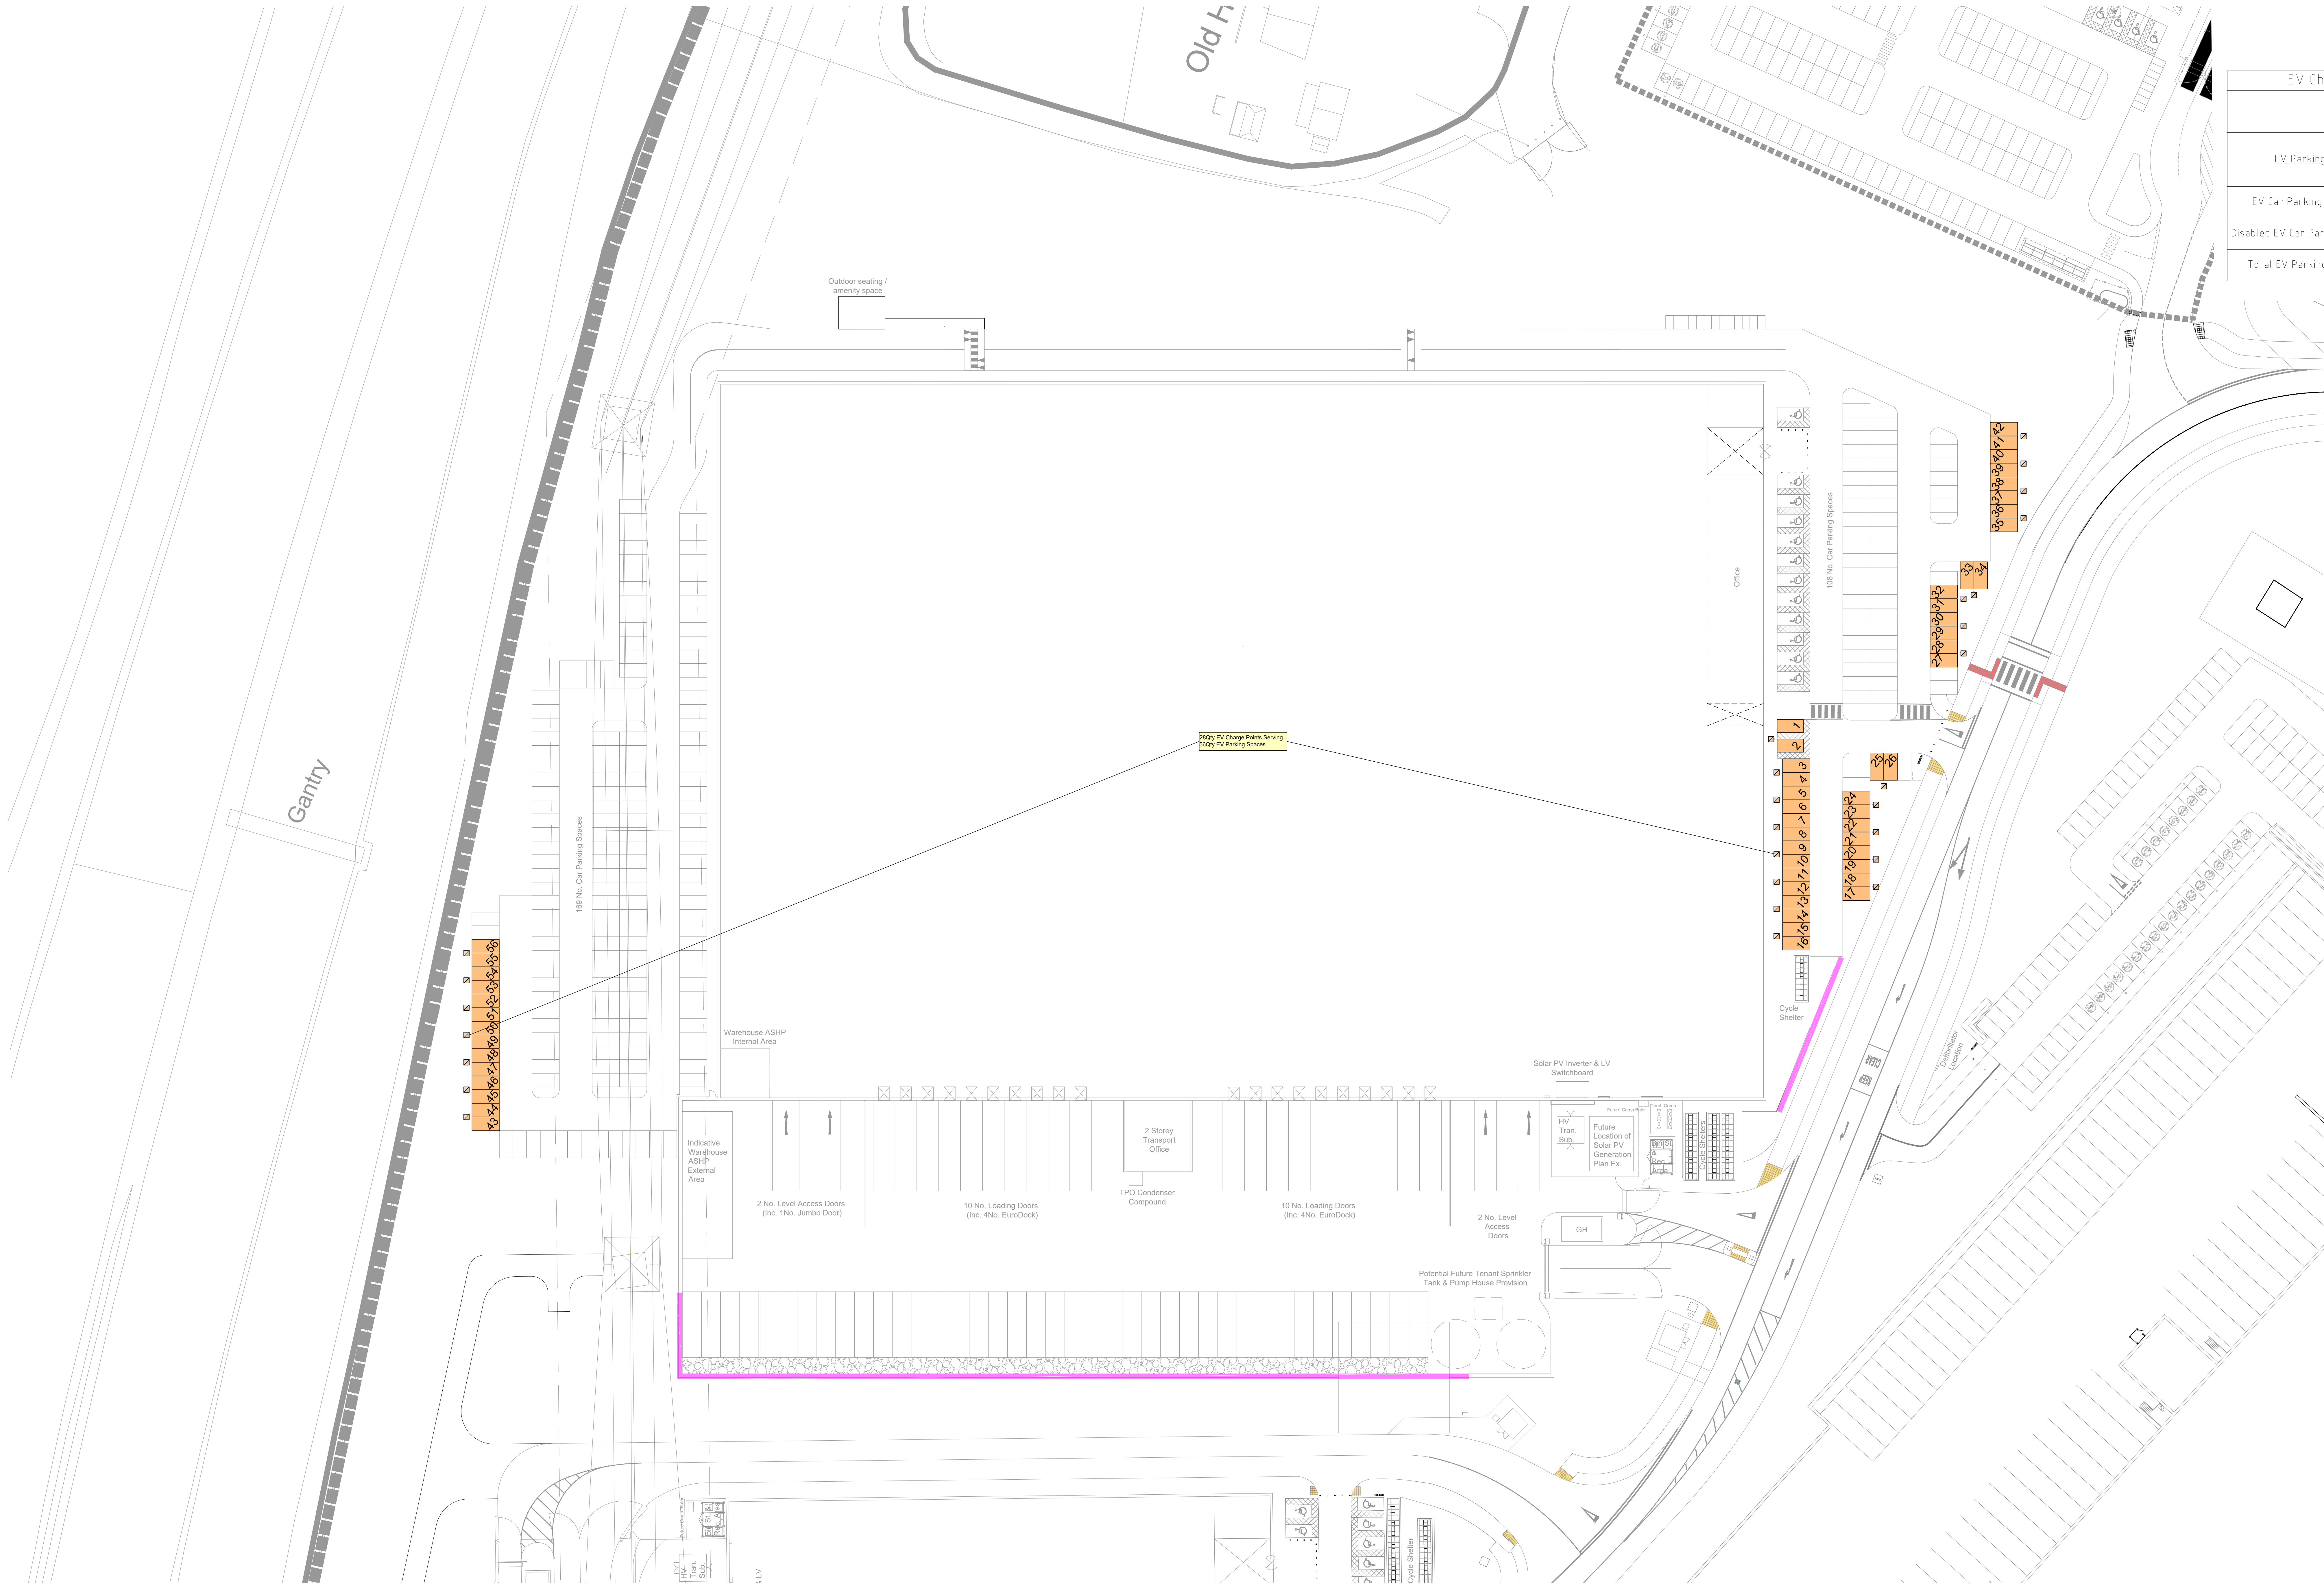

01	Updated To Sul Architects Masterplan Drawing Number	TRF	JW
08	23055-UMC-XXXX-03-DR-A-007- illustrative Masterplan-P18 FOR APPROVALS		
25			
26	Updated To Sul Architects Masterplan Drawing Number	TRF	JW
02	23055-UMC-XXXX-03-DR-A-007- illustrative Masterplan-P09 FOR APPROVALS		
24			
28	FOR APPROVALS	TRF	JW
1			
11			
23			
Rev	Description	Date	Revised

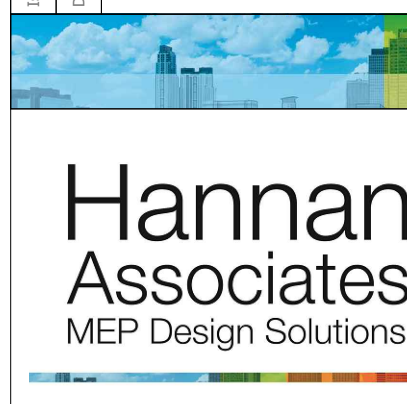

Hannan Associates
MEP Design Solutions

Hannan Associates Ltd
Beta House
Alphington Drive
Manchester Road
Denton
M34 5SH
Tel: +44 (0)161 337 2200
Email: info@hannan-uk.com
Web: www.hannan-uk.com



TRITAX SYMMETRY
A TRITAX BIG BOX COMPANY

Project: **Symmetry Park
Merseyside**

Design Stage: **Planning**

Drawing Title: **Site Plan - Unit 03
Electrical Services
EV Charge Strategy**

Draw Project Number: **4032** Scale: **1:400**

Drawing Number: **02514 - HAN - PL - 03 - DR - E - 009051**