




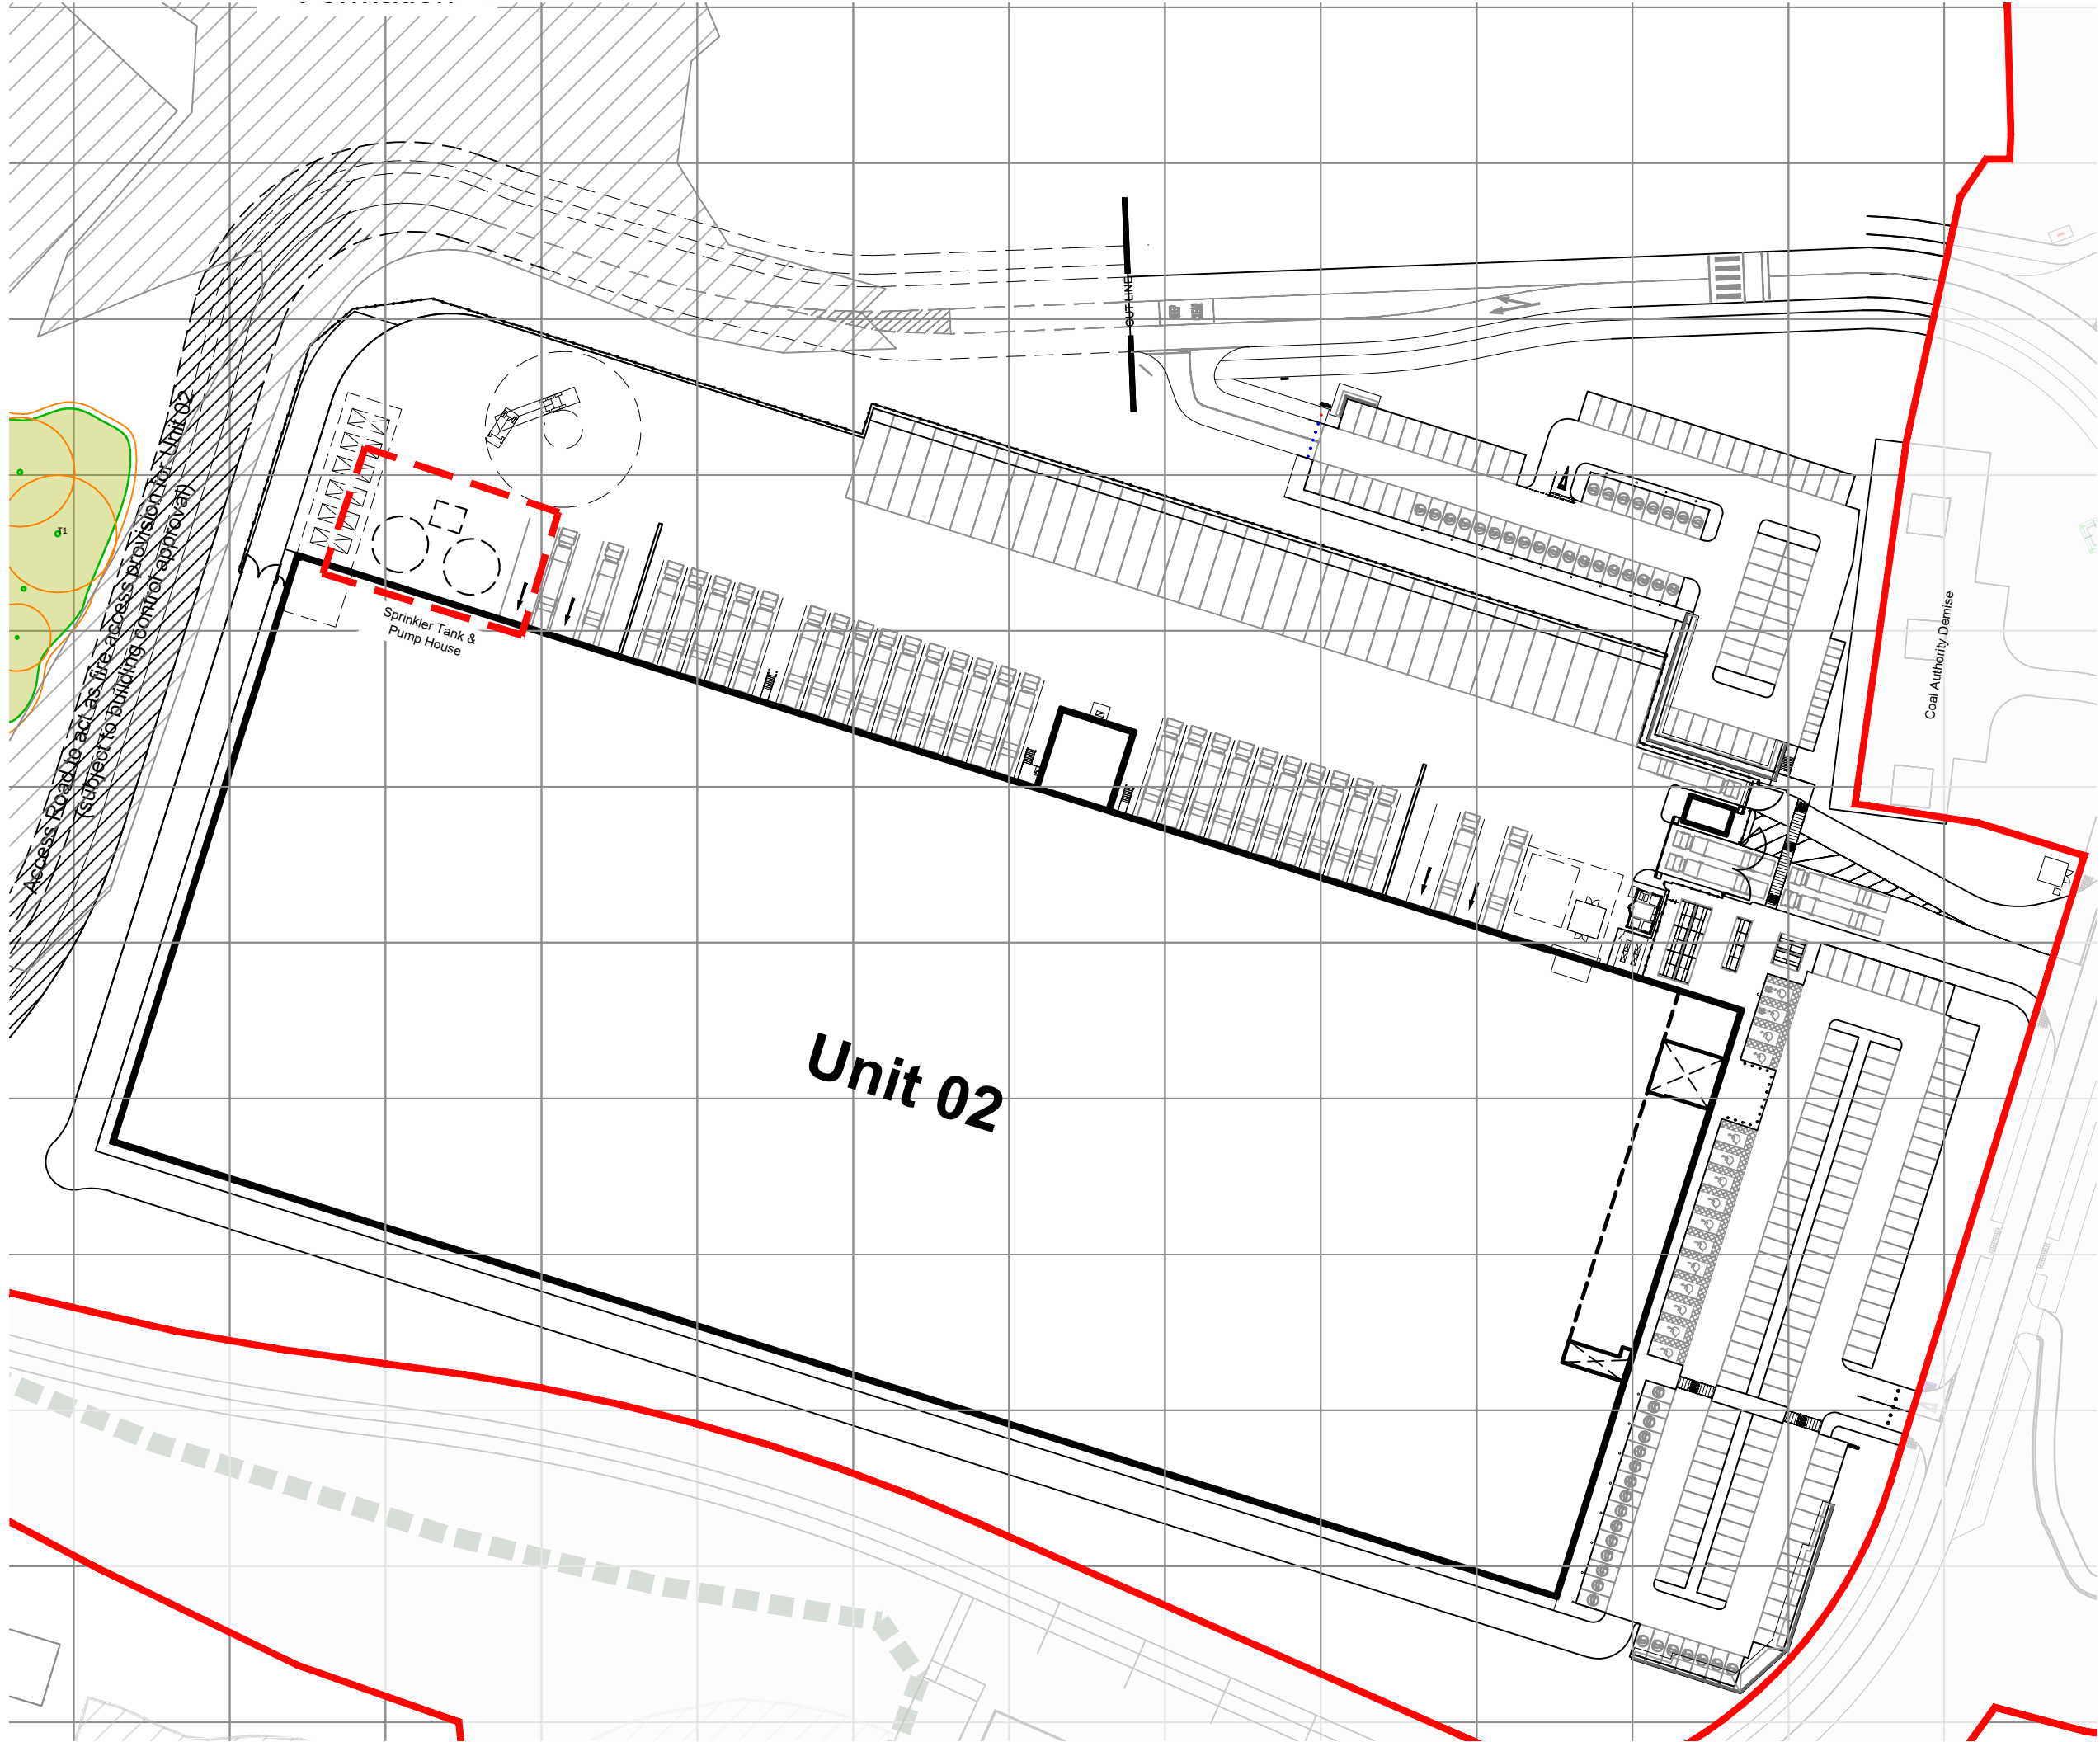


Site Plan
Scale 1:1000

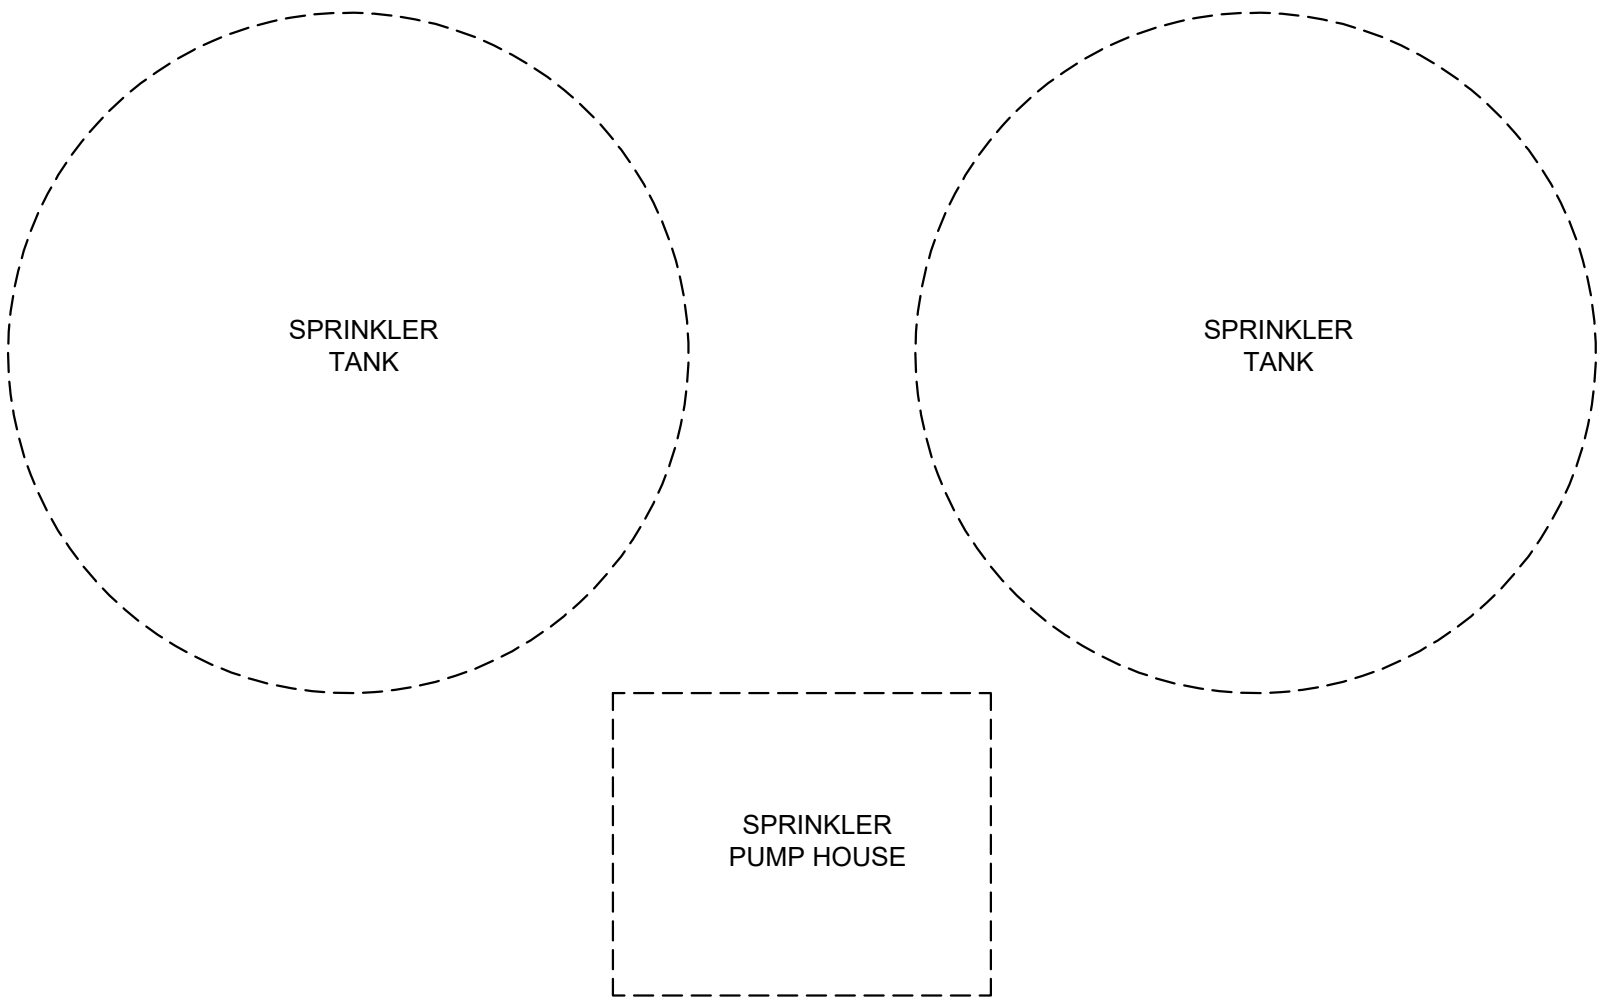

Sprinkler Tanks and Pump House Layout
Scale 1:100

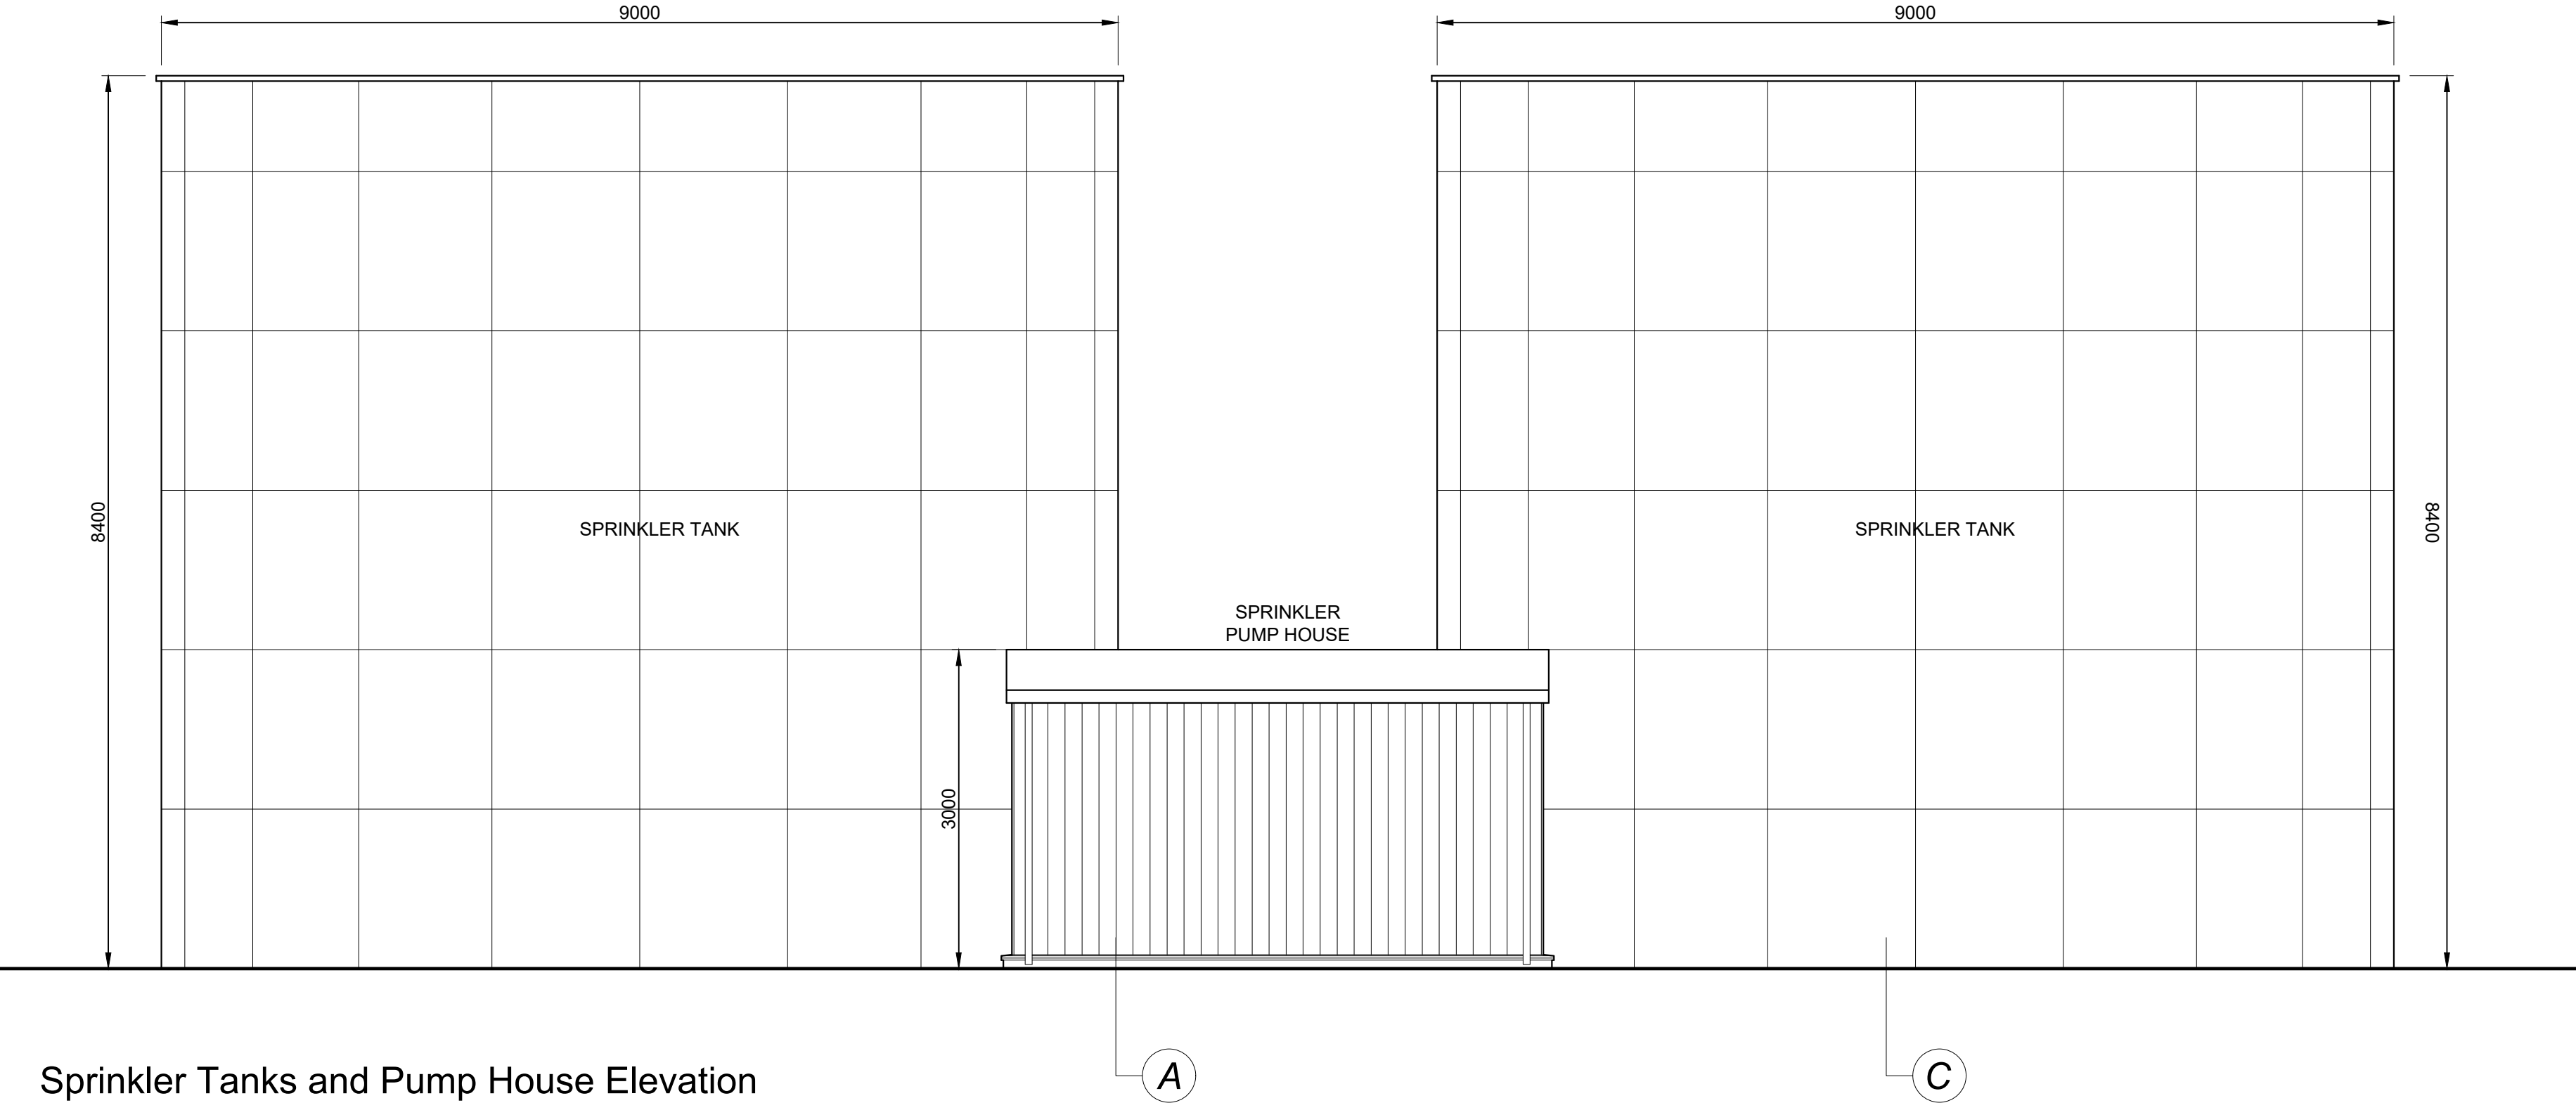


Sprinkler Tanks and Pump House Elevation
Scale 1:50

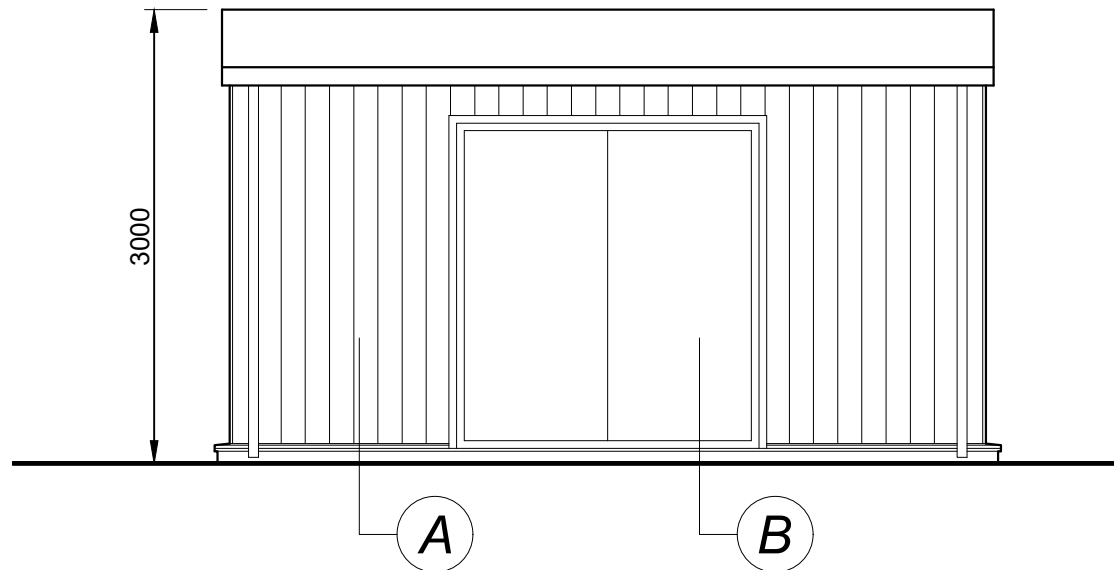

Pump House Elevation
Scale 1:50

External Finishes

- A** Vertically laid
Profiled wall cladding system.
Finish: Tata Colorcoat HPS 200 Ultra.
Colour: Alaska Grey (RAL 7000)
- B** Steel insulated personnel door & frame
Finish: Factory applied polyester powder
coat paint finish.
Colour: Anthracite (RAL 7016)
- C** Galvanised steel water storage tanks
Finish: Factory applied polyester powder
coat paint finish
Colour: Metallic Silver (RAL 9006)

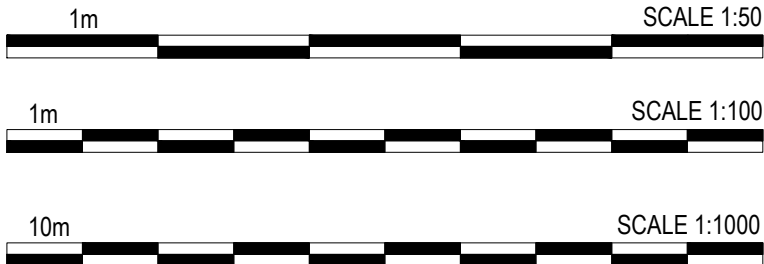

PLANNING

THIS DRAWING IS TO BE USED FOR THE STATED PURPOSE ONLY AND SHOULD NOT BE USED FOR ANY OTHER

rev	amendments	by	ckd	date
Unit 02, Symmetry Park, Merseyside				
Unit 02 Indicative Sprinkler Tank and Pump House Details				
LOD 2		LOI 2		
 A TRITAX BIG BOX COMPANY				
				
3rd Floor, Manchester Club, 81 King Street, Manchester, M2 4AH e. +44 (0)161 413 0590 e. info@umcarchitects.com				
RIBA PoW Stage:		2 - Concept Design		
Document Suitability:		S2		
Drawn / Checked:		MY / DEB		
Date:		08/05/2024		
Scale:		As Noted@ A1		
UMC Project Number:		22604		
Tritax Reference:				
02514 - U02 Planning - U02 NMA - UMC				
Document Reference:		Drawing no:		Revision:
22604 - UMC - SI02 - SI - DR - A		0705		P06