

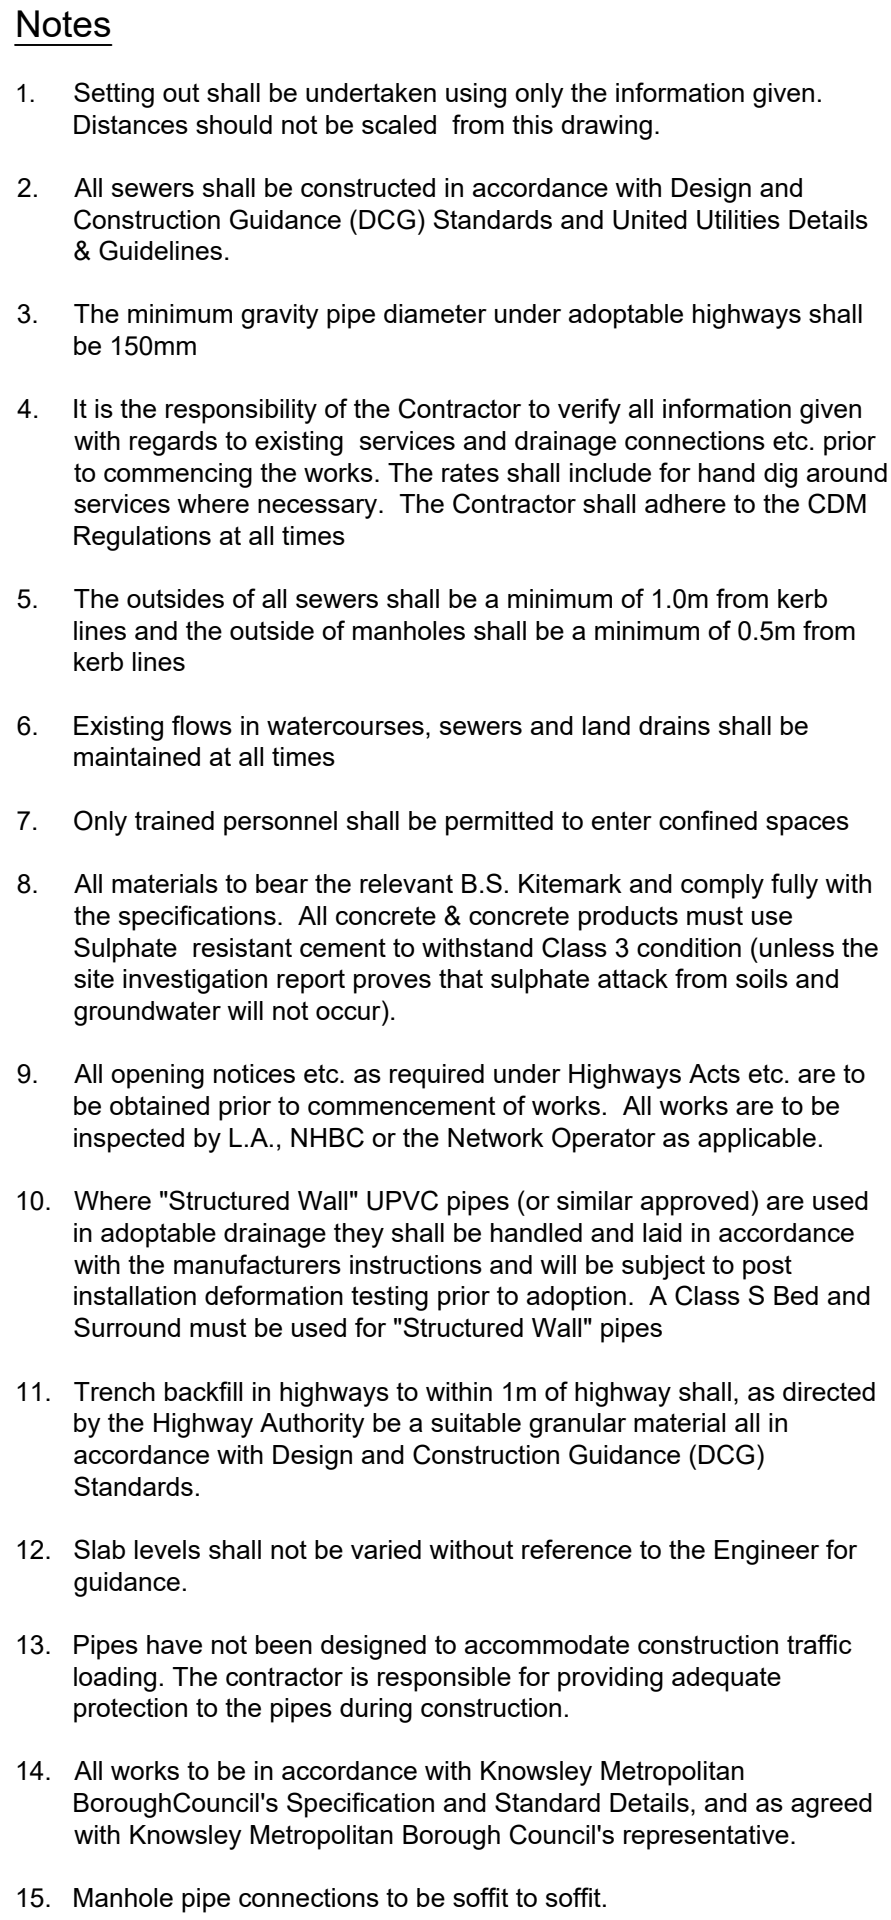
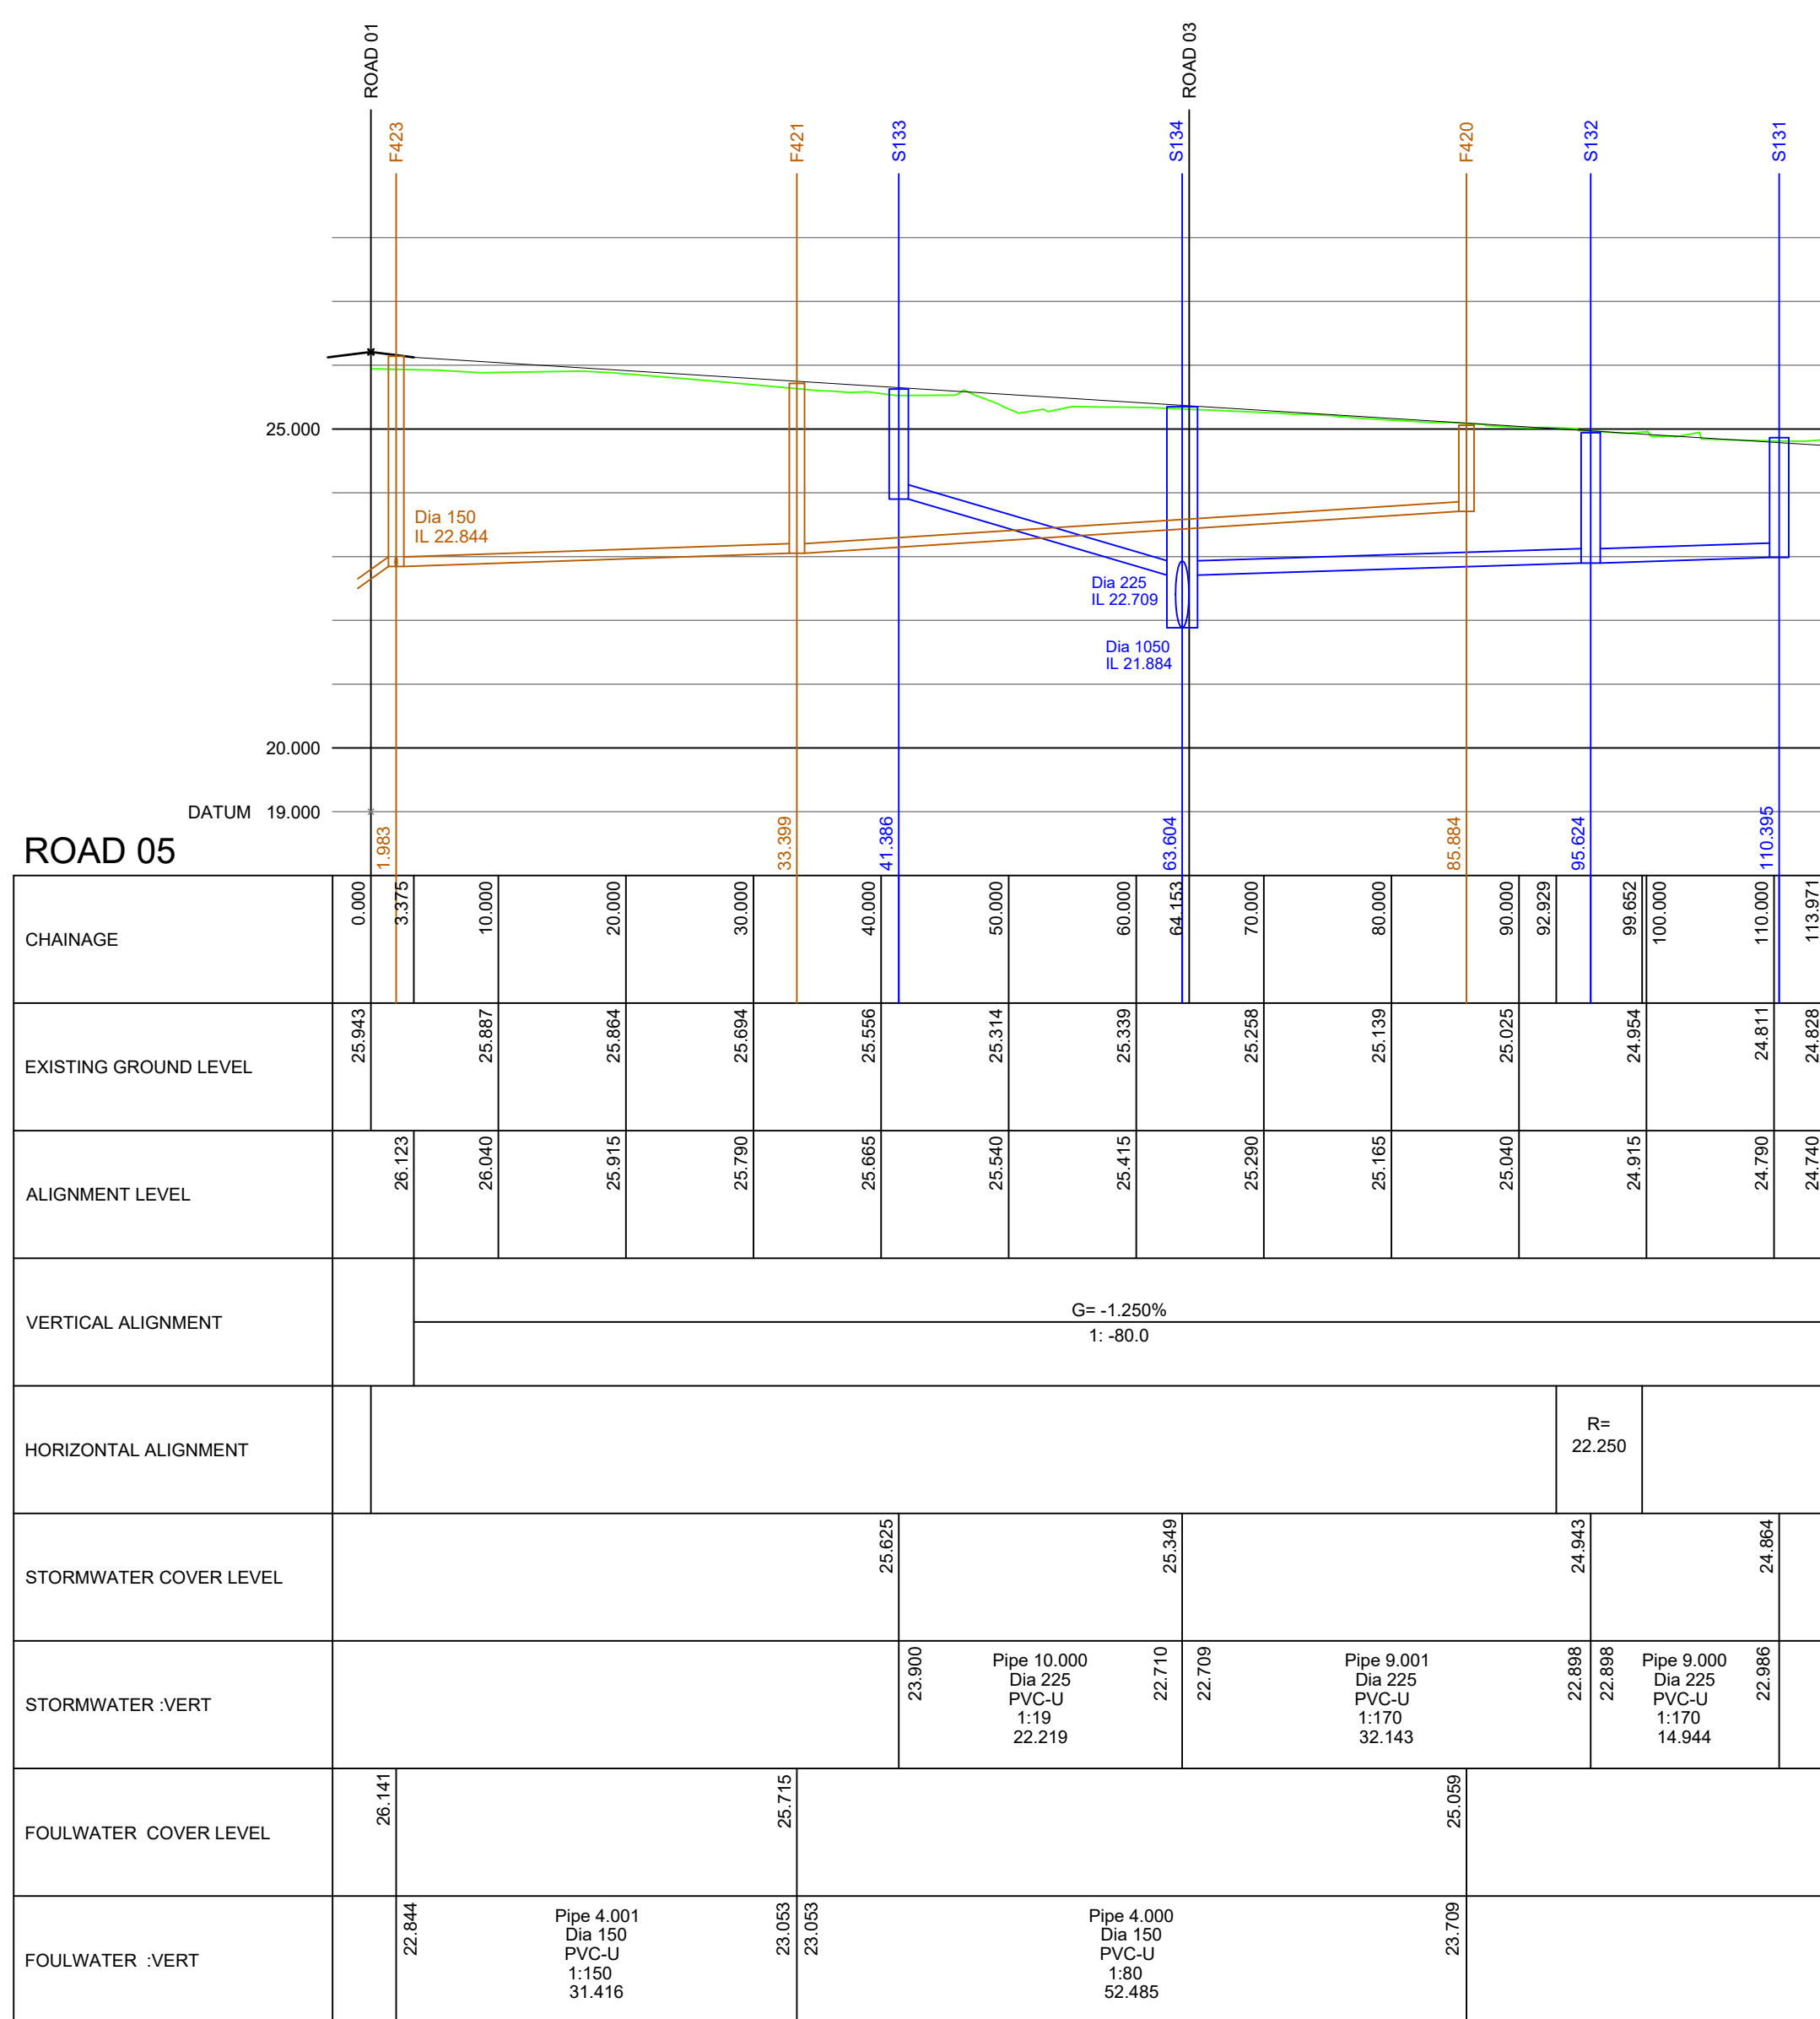
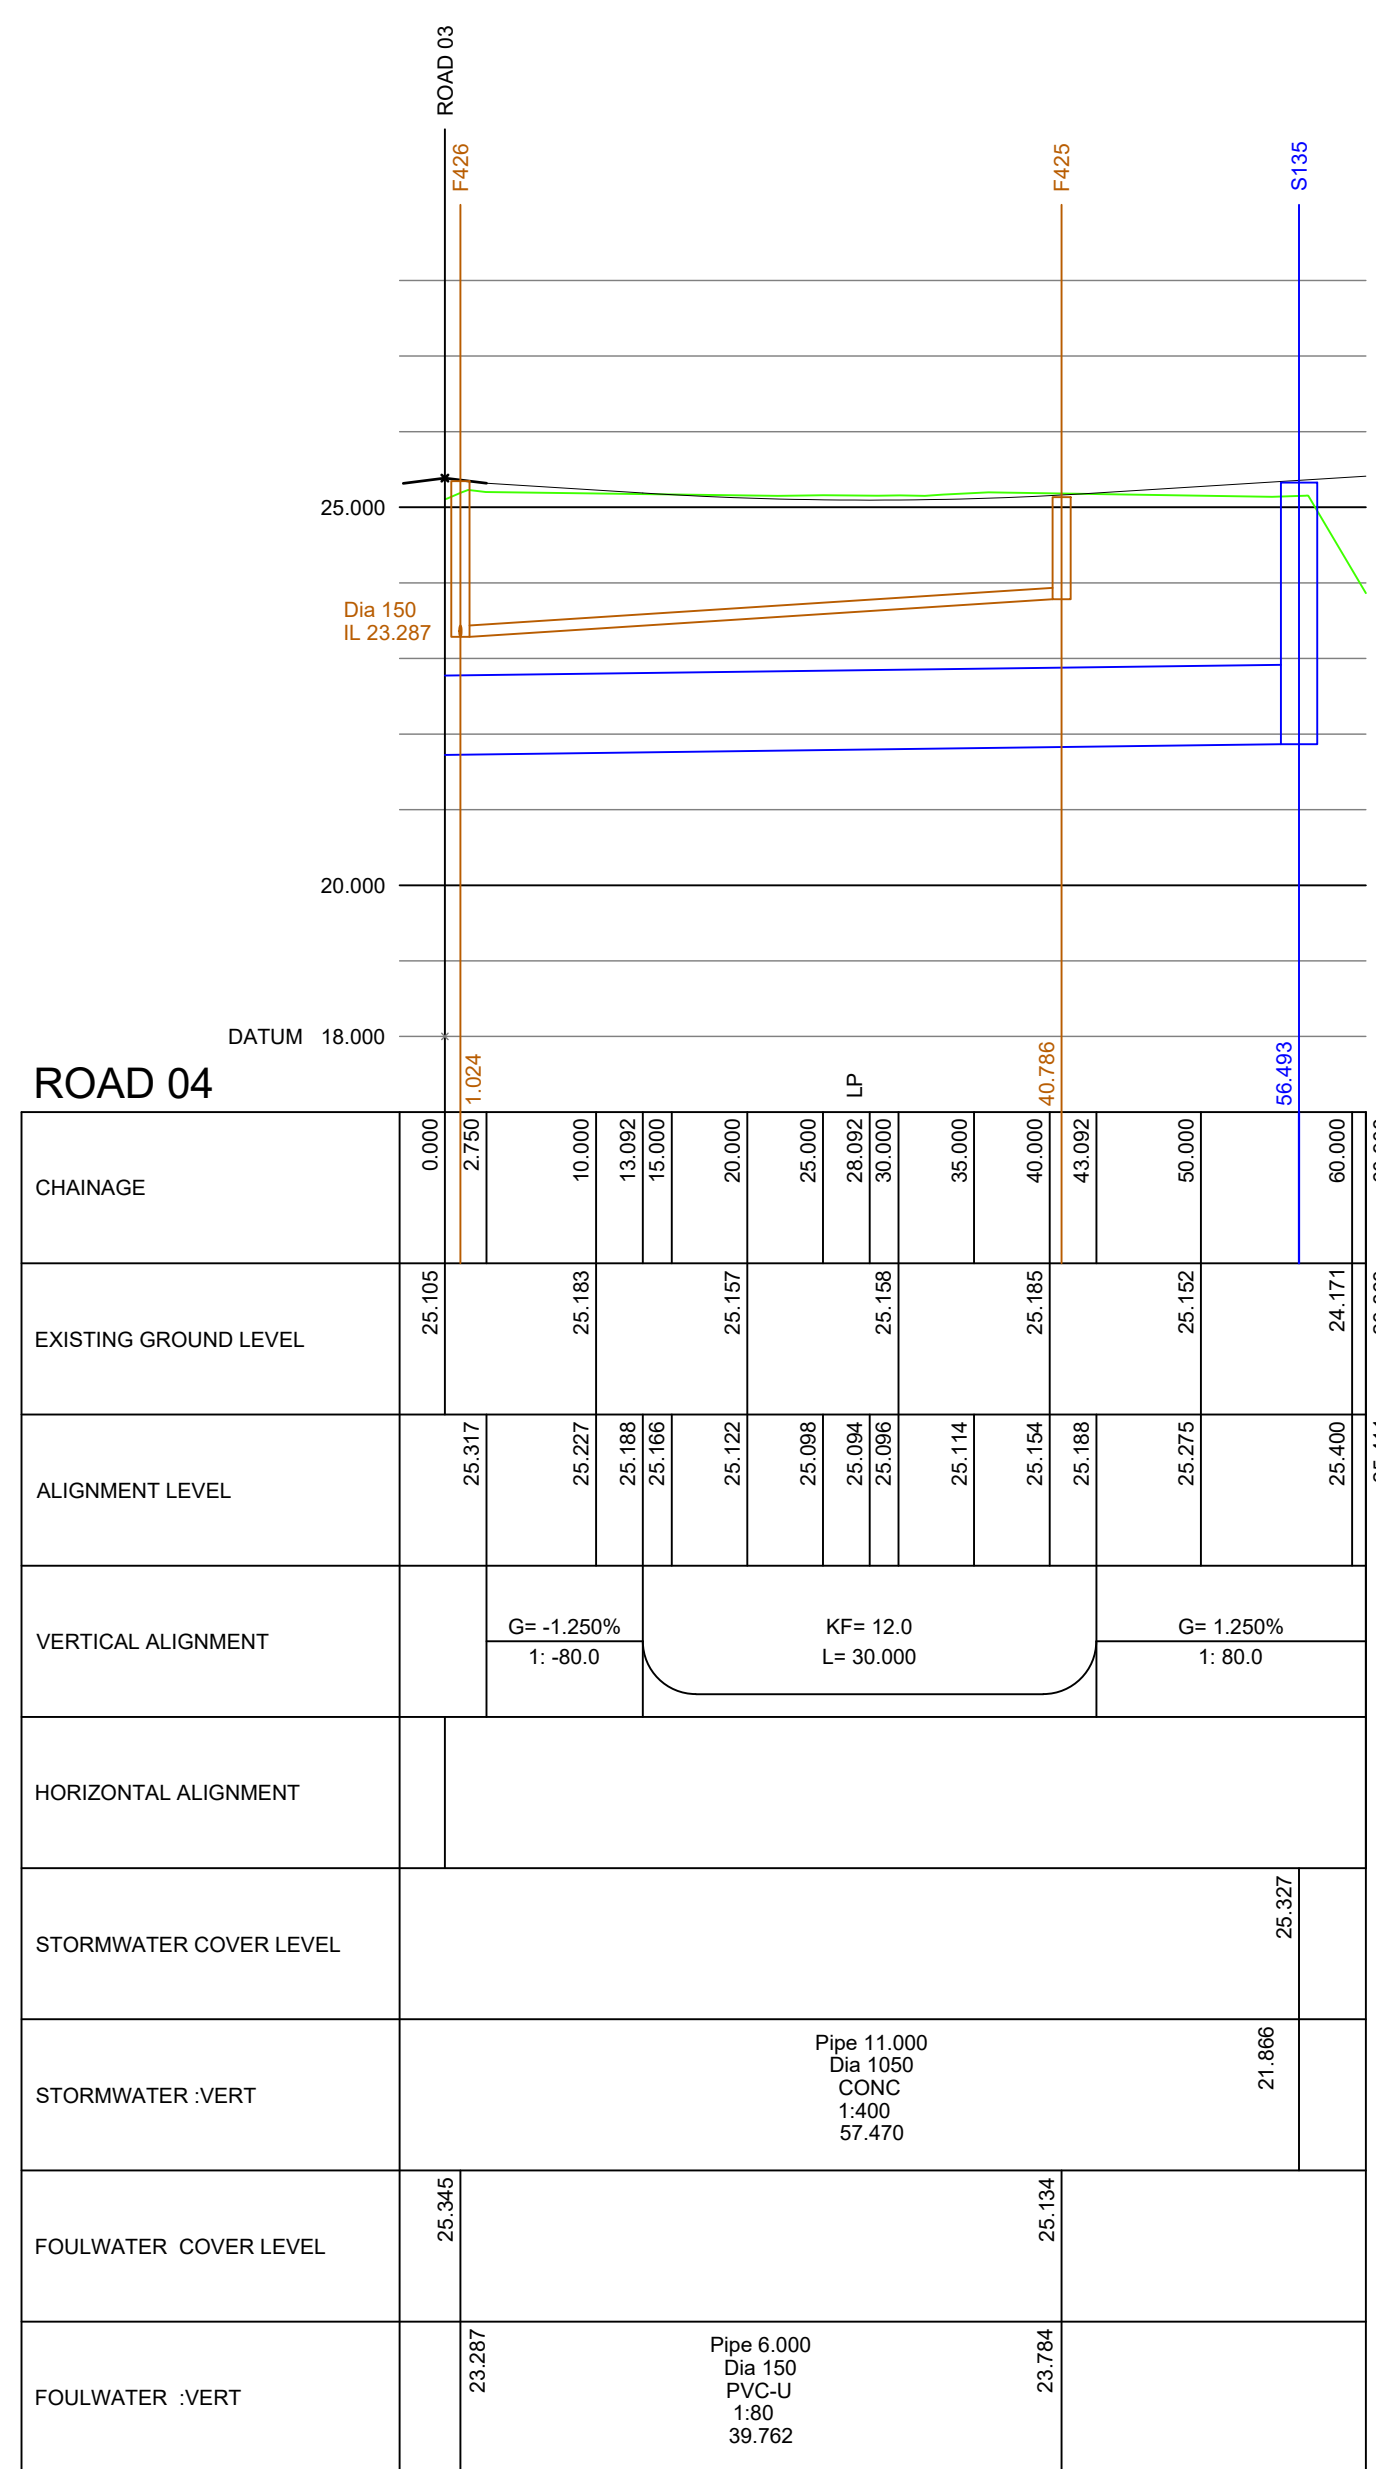
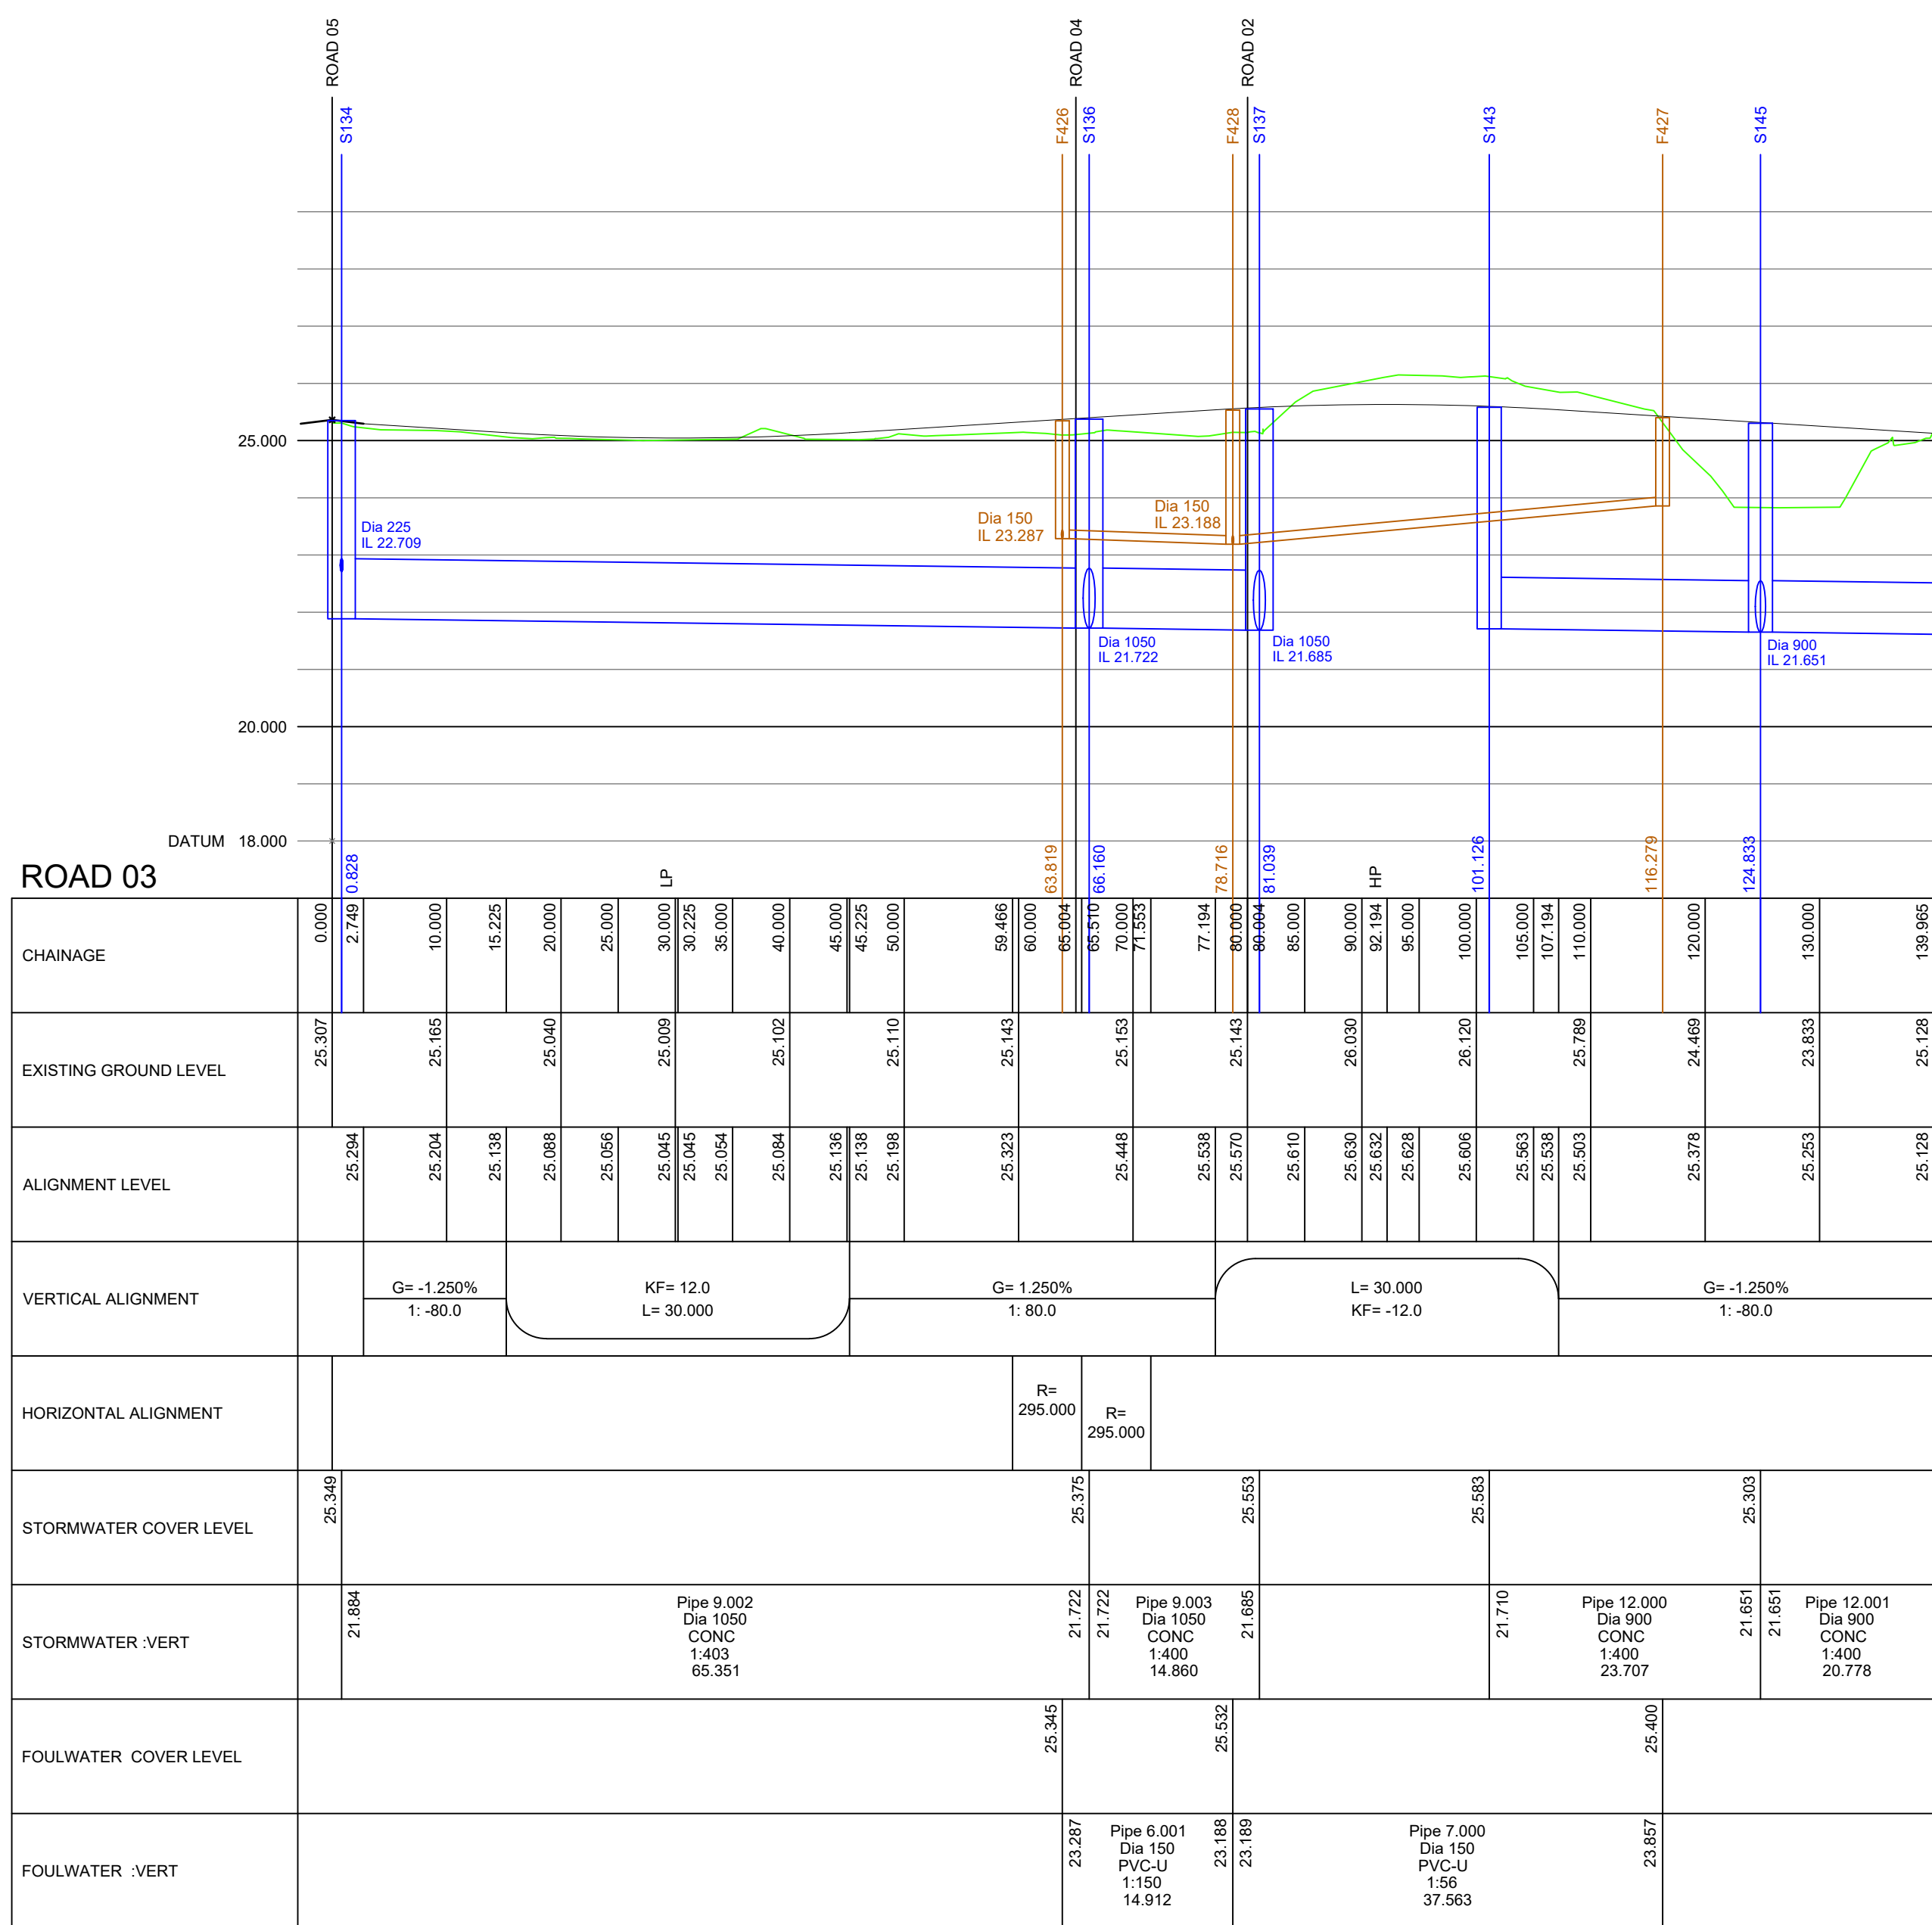


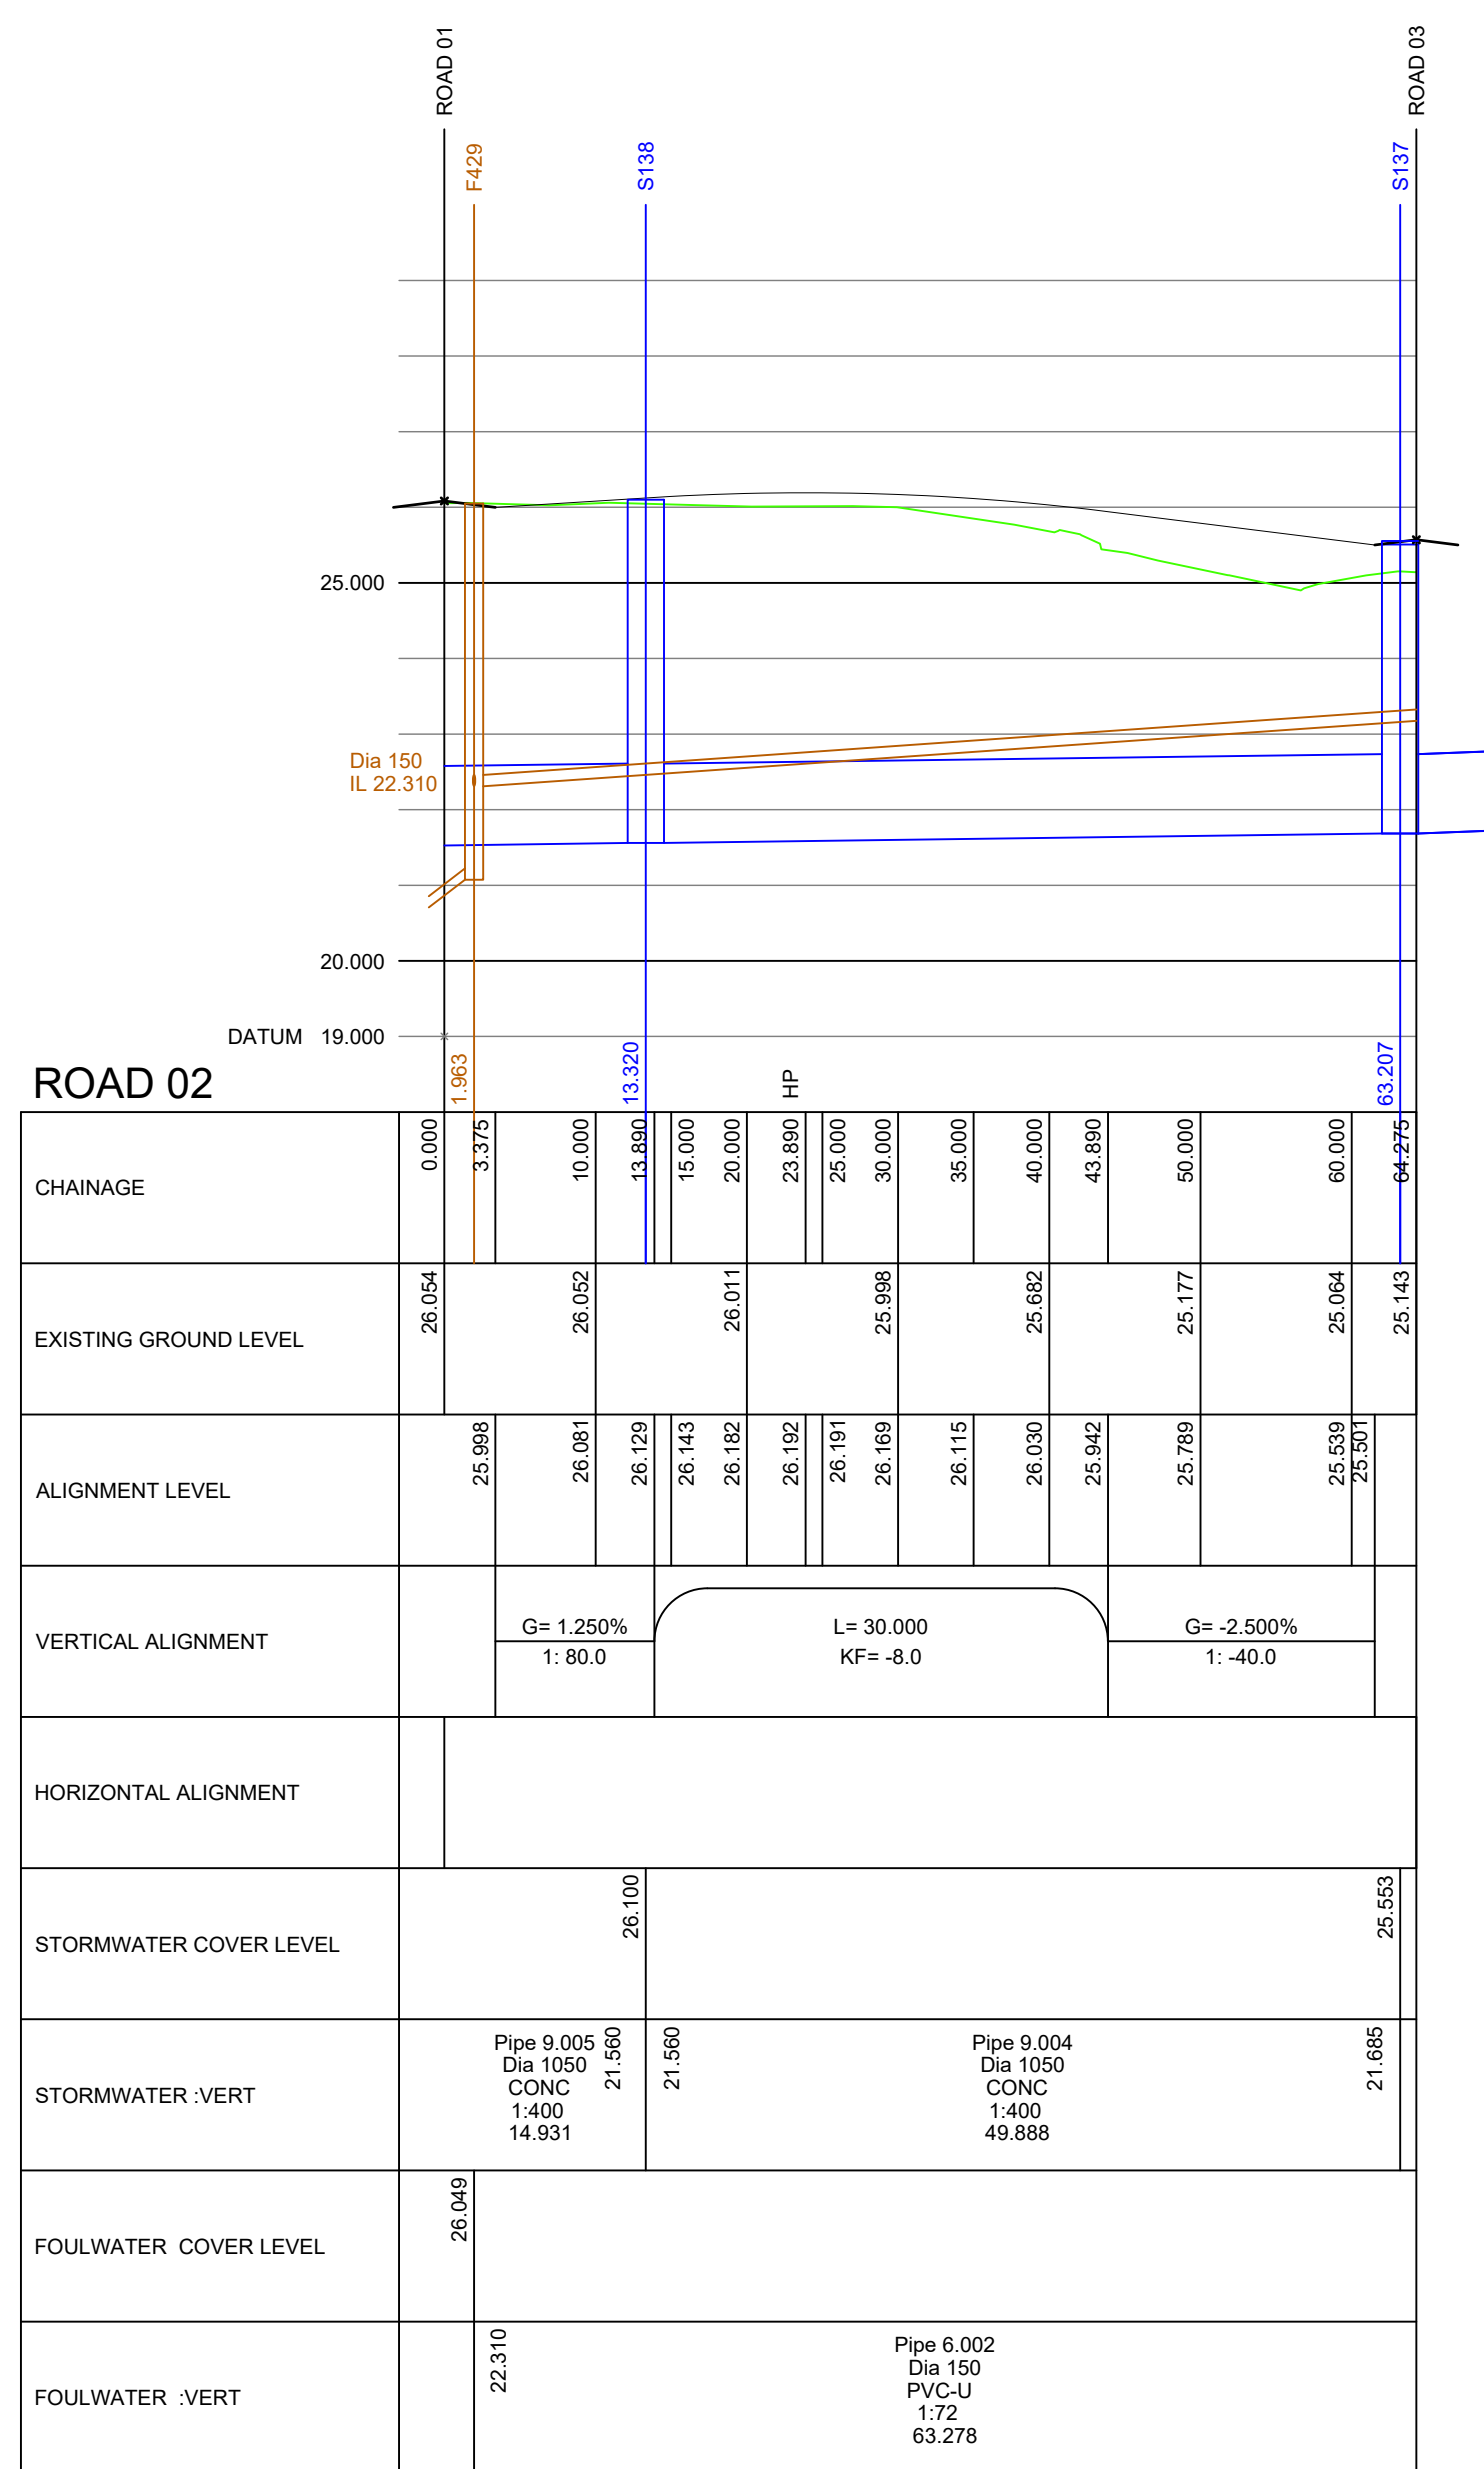

Class 'S' bed and surround to all pipes unless stated otherwise.
Class 'Z' bed and surround to pipes where cover < 1.2m as indicated on longsections.

All connections are soffit to soffit

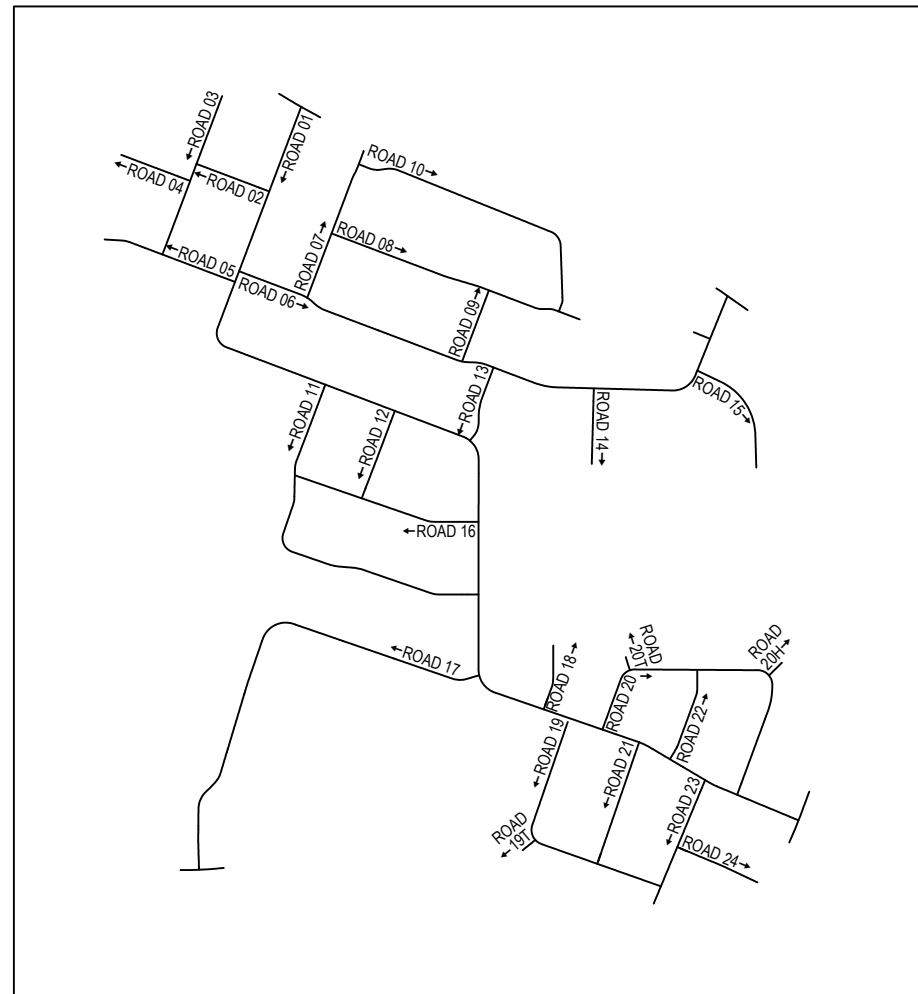

KEY PLAN

Coopers Drawing List

7778 / 01	Proposed S104 Drainage Layout
7778 / 02	Proposed Highway Setting Out
7778 / 03	Proposed Highway Layout
7778 / 04	Proposed Highway and Drainage Longsections
7778 / 05	Highway Construction Details
7778 / 06	Proposed Surface Finishes
7778 / 07	S38 Agreement Plan
7778 / 08	External Works Layout
7778 / 09	Private Drainage Layout
7778 / 10	Private Drainage Construction Details
7778 / 11	Manhole Schedules
7778 / 12	Flow Control Manhole Details
7778 / 13	Proposed Catchment Areas
7778 / 14	Surface Water Attenuation Details
7778 / 15	Proposed Cut and Fill Earthworks
7778 / 16	Pot Setting Out
7778 / 17	Manhole Connection Plan

TENDER



coopers

chartered consulting engineers

Tel: 01244 684910
 Email: admin@coopers.co.uk
 Web: <http://coopers.co.uk>

Park House
 Sandipier Court
 Chester Business Park
 Chester
 CH4 9SD

Client _____



BARRATT — HOMES —



Barratt: David Wilson Homes
 North West
 303 Bridgewater Place
 2nd Floor
 Warrington
 Cheshire
 WA3 6XF
 TEL: 01925 846600

DAVID WILSON HOMES

WHERE QUALITY LIVES

Project _____

CHERRYFIELD DRIVE, KIRKBY.

Highway and Drainage Longsections

Sheet 2 of 7

DRAWING NUMBER	SCALE AT A0	1:500 H: 1:100 V	REVISION
7778 / 04-2	DATE	07.05.25	REVISED
	DRAWN	P.J.N	-
	CHECKED	A.J	