

Copyright Reserved

The Contractor shall verify and be responsible for all dimensions. DO NOT scale the drawing.
Any errors or omissions shall be reported to Stantec without delay.
The Copyrights to all designs and drawings are the property of Stantec.
Reproduction or use for any purpose other than that authorised by Stantec is forbidden.

Notes

UTILITIES NOTE: The position of any existing public or private sewers, utility services, plant or apparatus shown on this drawing is believed to be correct, but no warranty to this is expressed or implied. Other such plant or apparatus may also be present but not shown. The Contractor is therefore advised to undertake their own investigation where the presence of any existing sewers, services, plant or apparatus may affect their operations.


GENERAL KEY:

PHASE 1 BOUNDARY
EASEMENT


DRAINAGE KEY

PROPOSED PRIVATE FOUL WATER SEWER AND MANHOLE
PROPOSED SURFACE WATER SEWER AND MANHOLE
PROPOSED SURFACE WATER GEOCELLULAR STORAGE TANK
PROPOSED INTERCEPTOR
PROPOSED HEADWALL

D

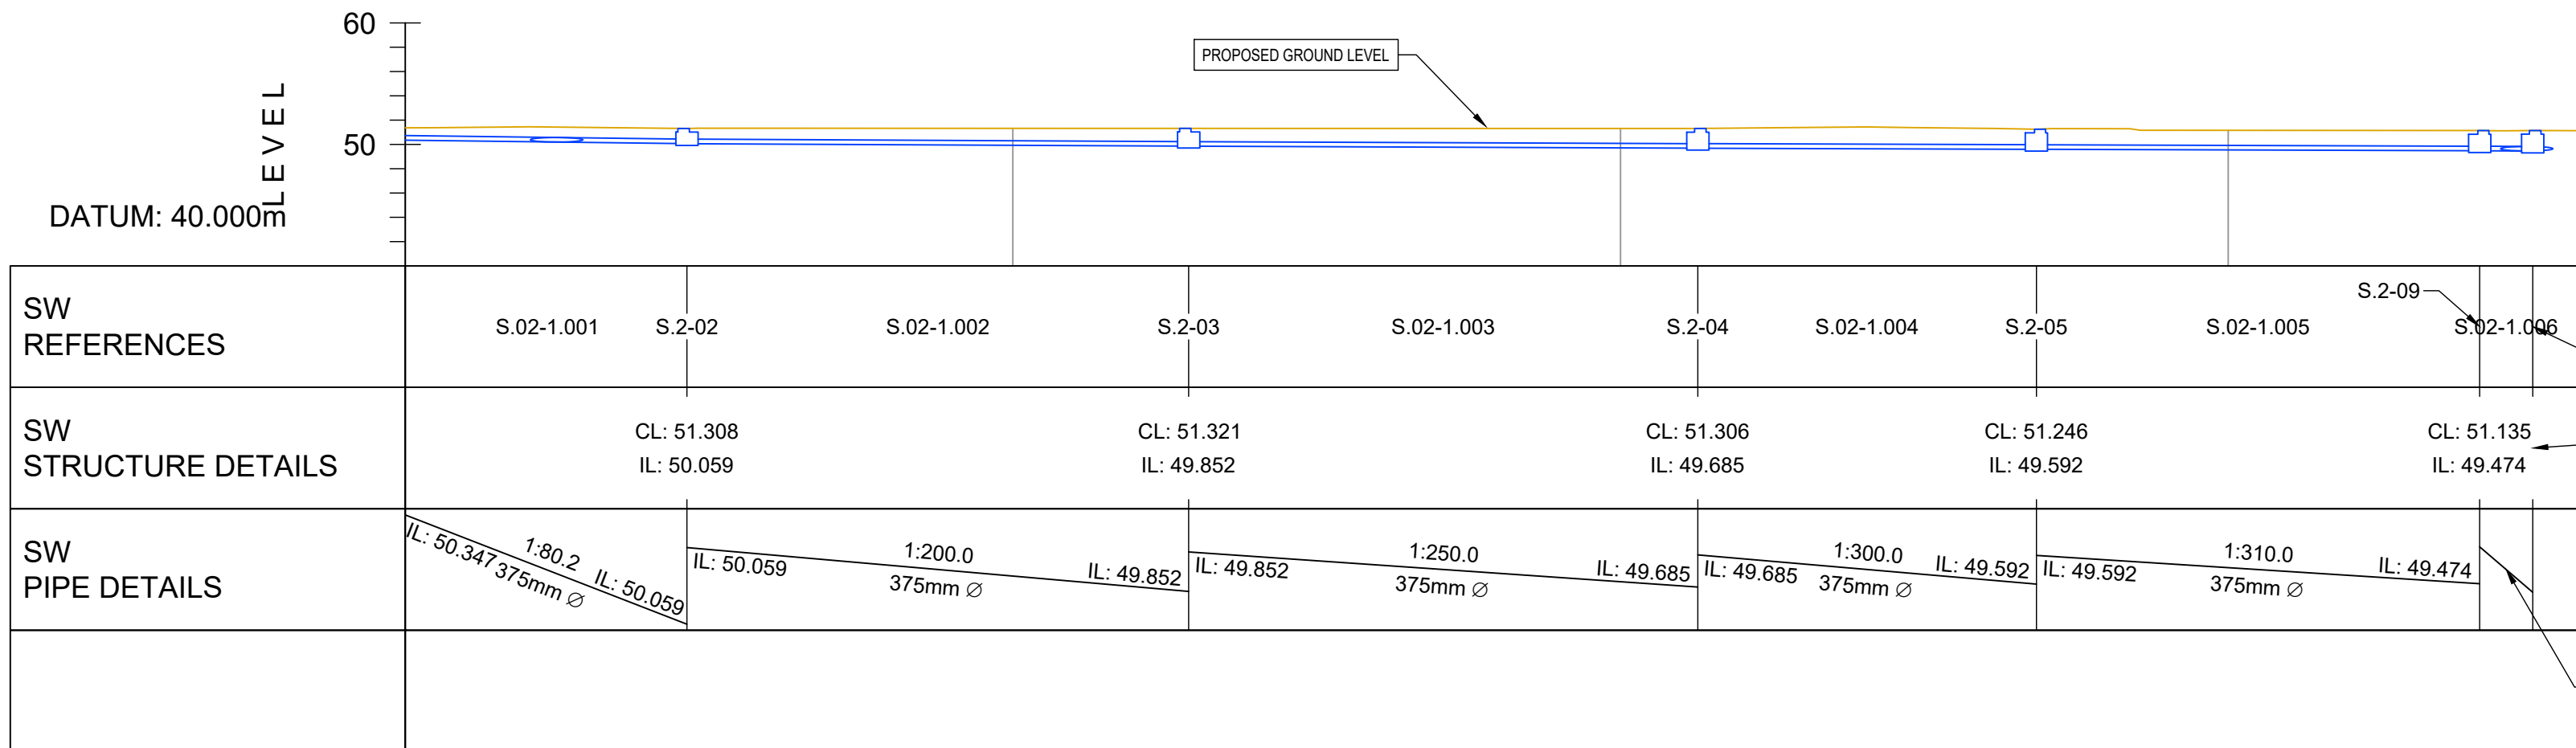


UNIT 2 - 2-1 TO INTERCEPTOR INLET LONGSECTION
SCALE: H 1:500,V 1:500

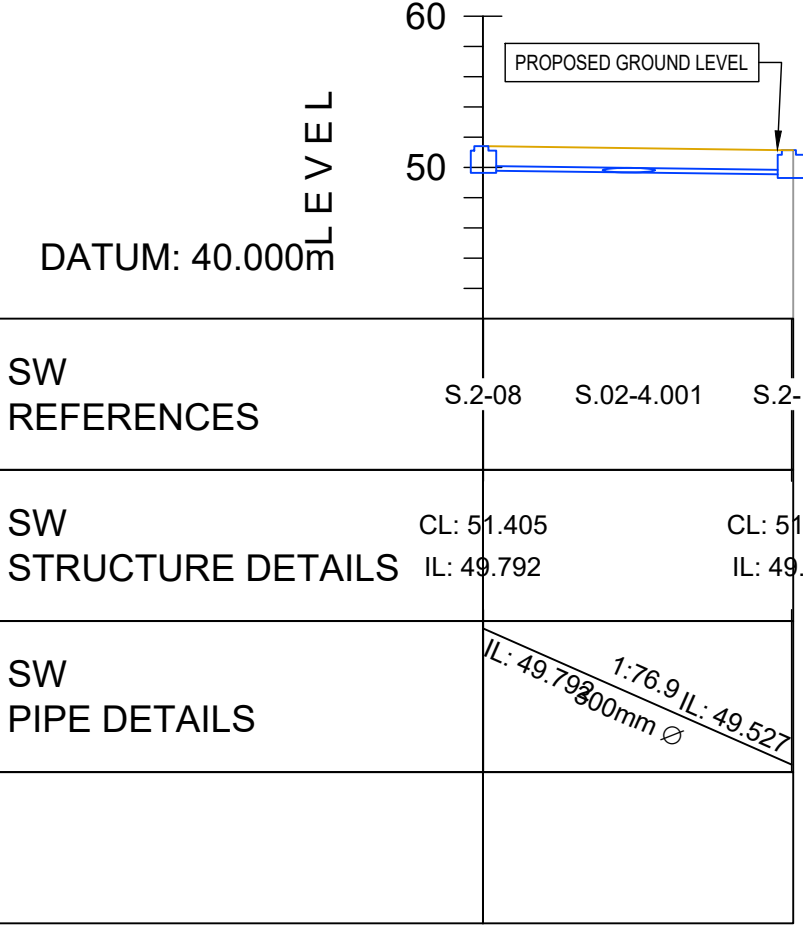


UNIT 2 - 2-4 LONGSECTION
SCALE: H 1:500,V 1:500

C

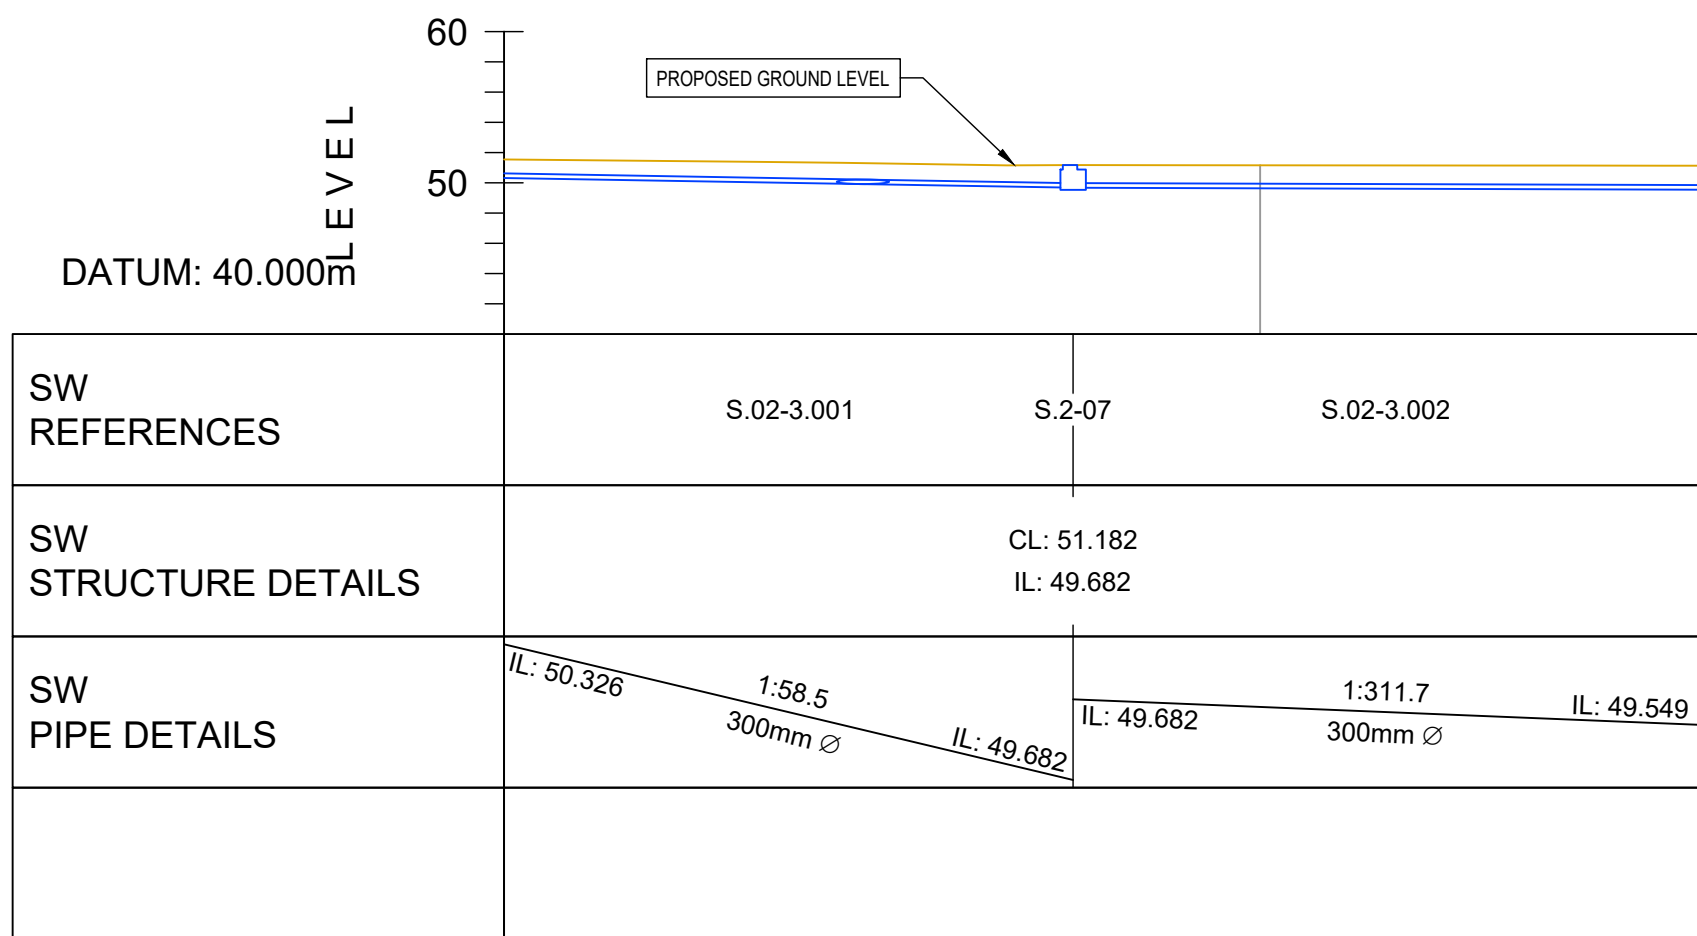

UNIT 2 - 2-3 LONGSECTION
SCALE: H 1:500,V 1:500

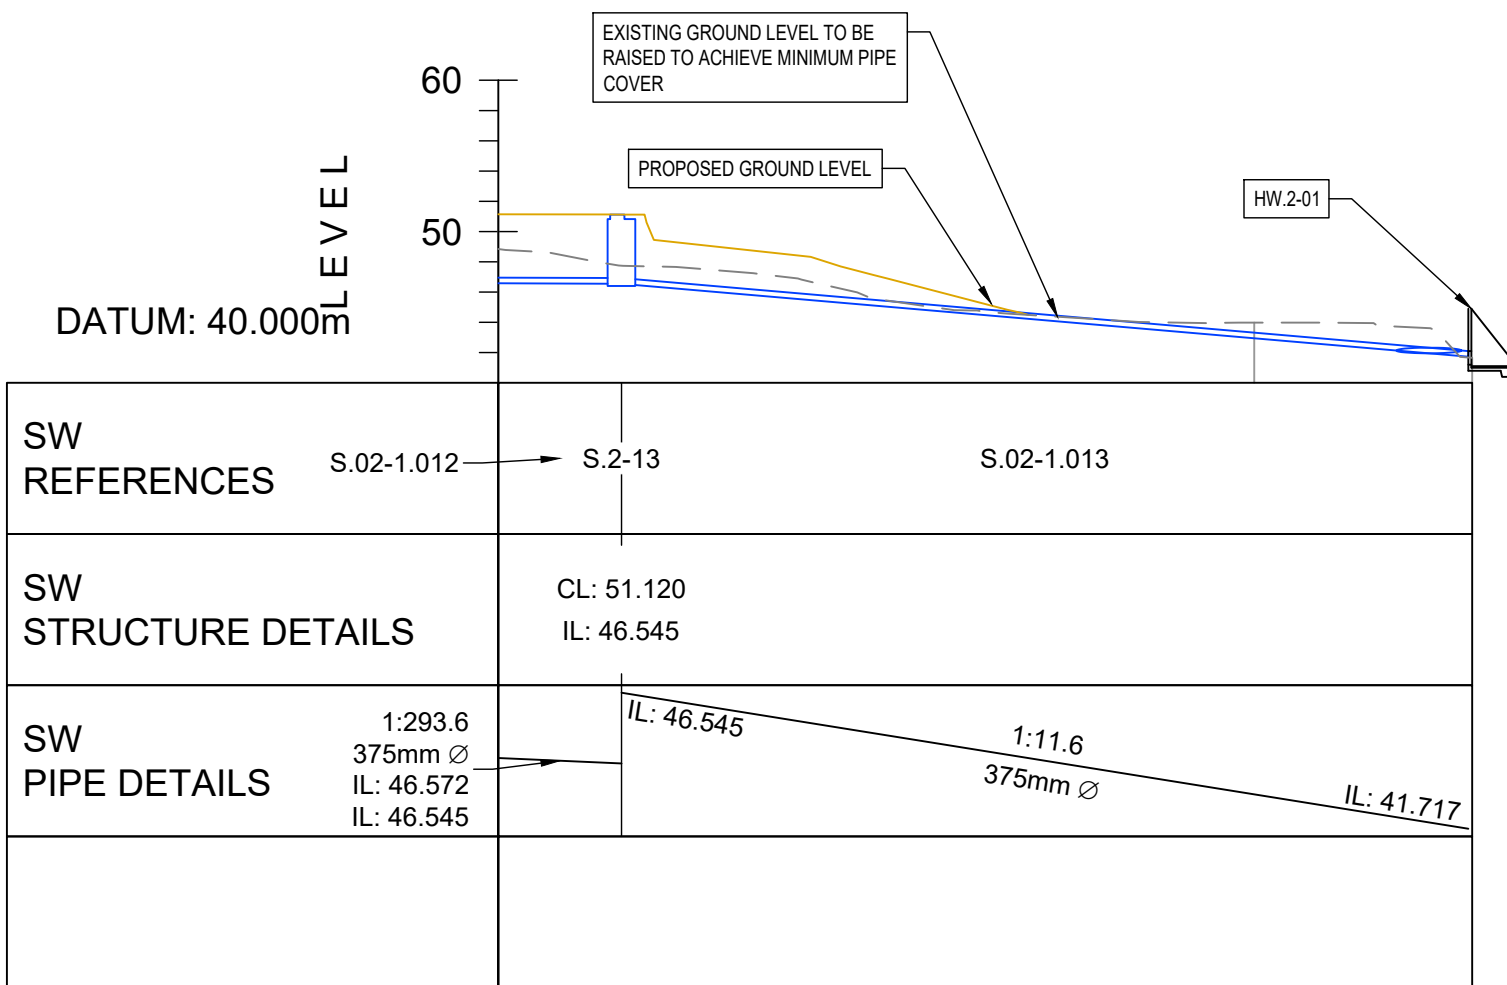

UNIT 2 - TO OUTFALL LONGSECTION
SCALE: H 1:500,V 1:500

NOTES:

- DO NOT SCALE FROM THIS DRAWING. IF IN DOUBT PLEASE REQUEST FURTHER INFORMATION.
- ALL DIMENSIONS ARE IN METRES UNLESS STATED OTHERWISE.
- THIS DRAWING IS TO BE READ IN CONJUNCTION WITH ALL OTHER CONTRACT DRAWINGS AND DOCUMENTS.
- TOPOGRAPHICAL SURVEY UNDERTAKEN BY MAYER BROWN DATED SEPTEMBER 2017.
- ALL WORKS TO BE IN ACCORDANCE WITH HIGHWAY ENGLAND SPECIFICATION FOR HIGHWAY WORKS VOLUME 1 AND CONTRACT SPECIFIC APPENDICES.
- THE REAR OF EMPLOYMENT UNIT 2 IS NOT INCLUDED WITHIN THE TOPOGRAPHICAL SURVEY EXTENTS. LEVELS SHOWN IN THIS AREA ARE INDICATIVE AND HAVE BEEN EXTRAPOLATED FROM ADJACENT SURVEYED LEVELS.
- SEWER RECORDS OBTAINED FROM UNITED UTILITIES DATED JULY 2018
- CCTV RECORDS OBTAINED FROM SEP DRAINAGE SURVEY DATED DECEMBER 2017.
- REFER TO V1031 L01 UNDERTAKEN BY VECTOR DESIGN CONCEPTS FOR PROPOSED LANDSCAPING PLAN.
- REFER TO DRAWINGS 331810328-STN-HGN-ALD-DR-CH-0600-601 FOR PROPOSED CONTOUR AND ISOPACHYTES.
- REFER TO DRAWING 331810328-STN-HDG-ALD-DR-CD-0500 FOR DRAINAGE LAYOUT.
- REFER TO DRAWING 331810328-STN-HDG-ALD-DR-CD-0501 FOR MANHOLE AND PIPE SCHEDULES.
- REFER TO DRAWING 331810328-STN-HDG-ALD-DR-CD-0502-505 FOR DRAINAGE CONSTRUCTION DETAILS.

P01 FIRST ISSUE	YB	TG	2024.08.28
Issued/Revision	By	Appd	YYYY.MM.DD
	YB	YB	IG
	Dwn.	Dsgn.	Chkd.
			2024.08.28
			YYYY.MM.DD

Issue Status

S5 - FOR REVIEW
AND ACCEPTANCE

This document is suitable only for the
purpose noted above.
Use of this document for any other
purpose is not permitted.

Client/Project Logo



Client/Project
ALDI STORES LTD

CABLES WAY


PRESCOT

Title

MIXED USE DEVELOPMENT
DRAINAGE LONG SECTIONS
SHEET 2 OF 2

Project No.	A1 Scale
331810328	1:500
Revision	Drawing No.
P01	331810328-STN-HDG-ALD-DR-CH-0511

A

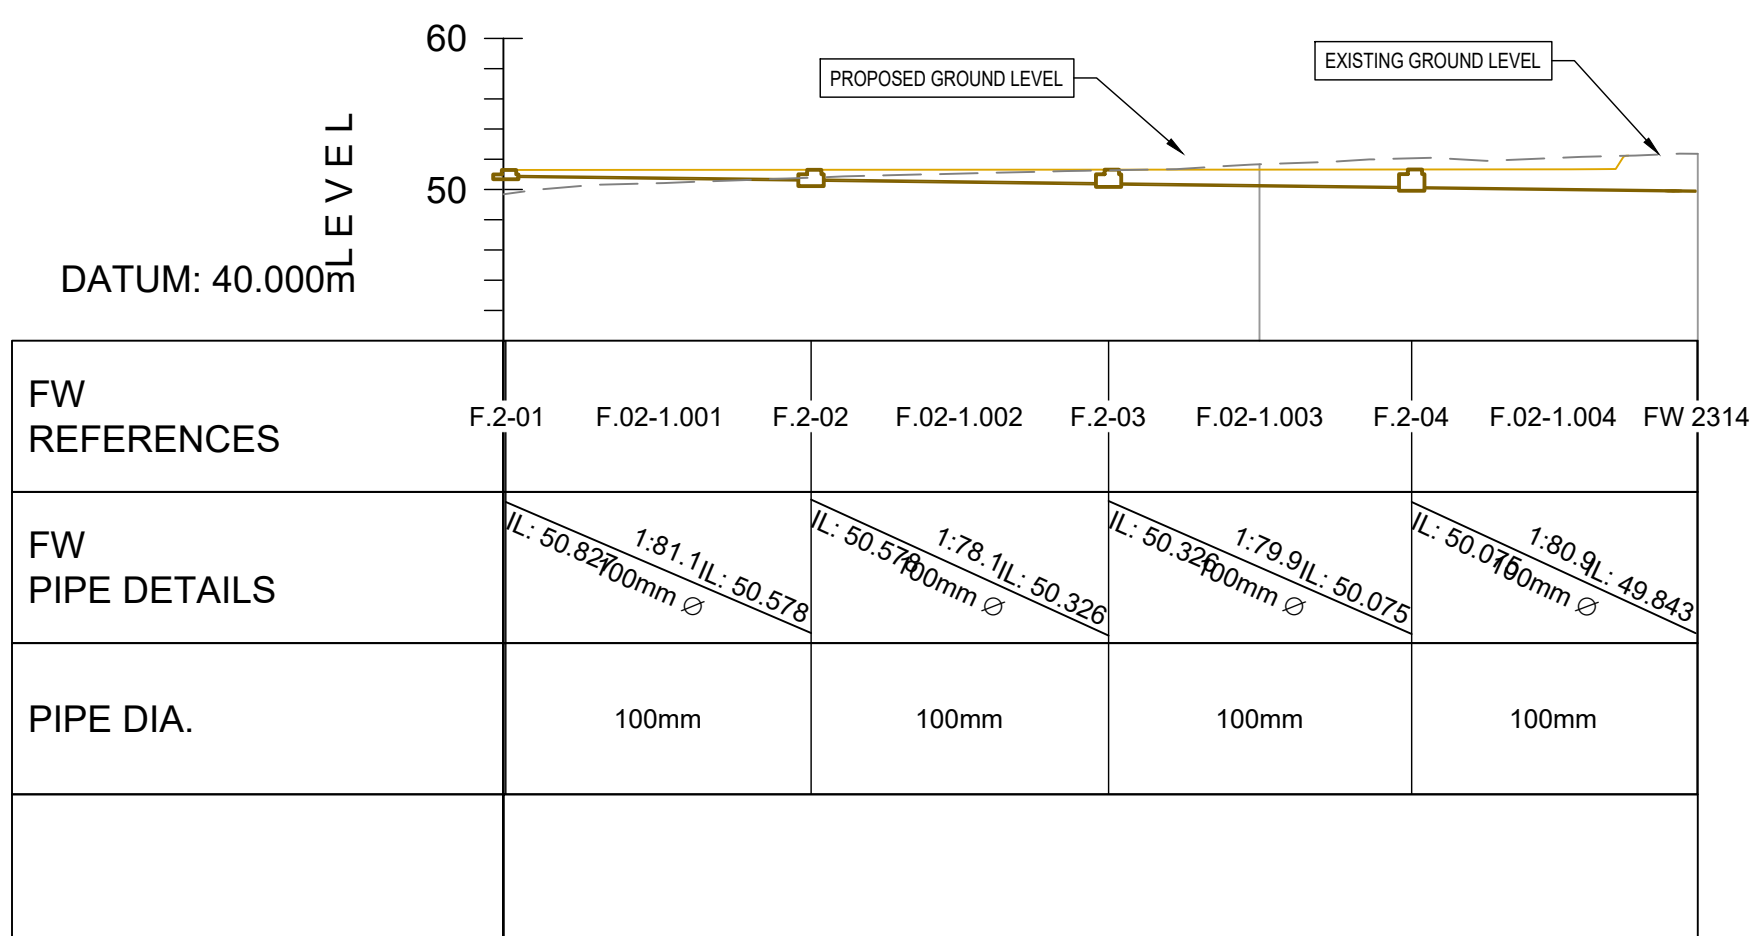

FW UNIT 2 LONGSECTION
SCALE: H 1:500,V 1:500

