



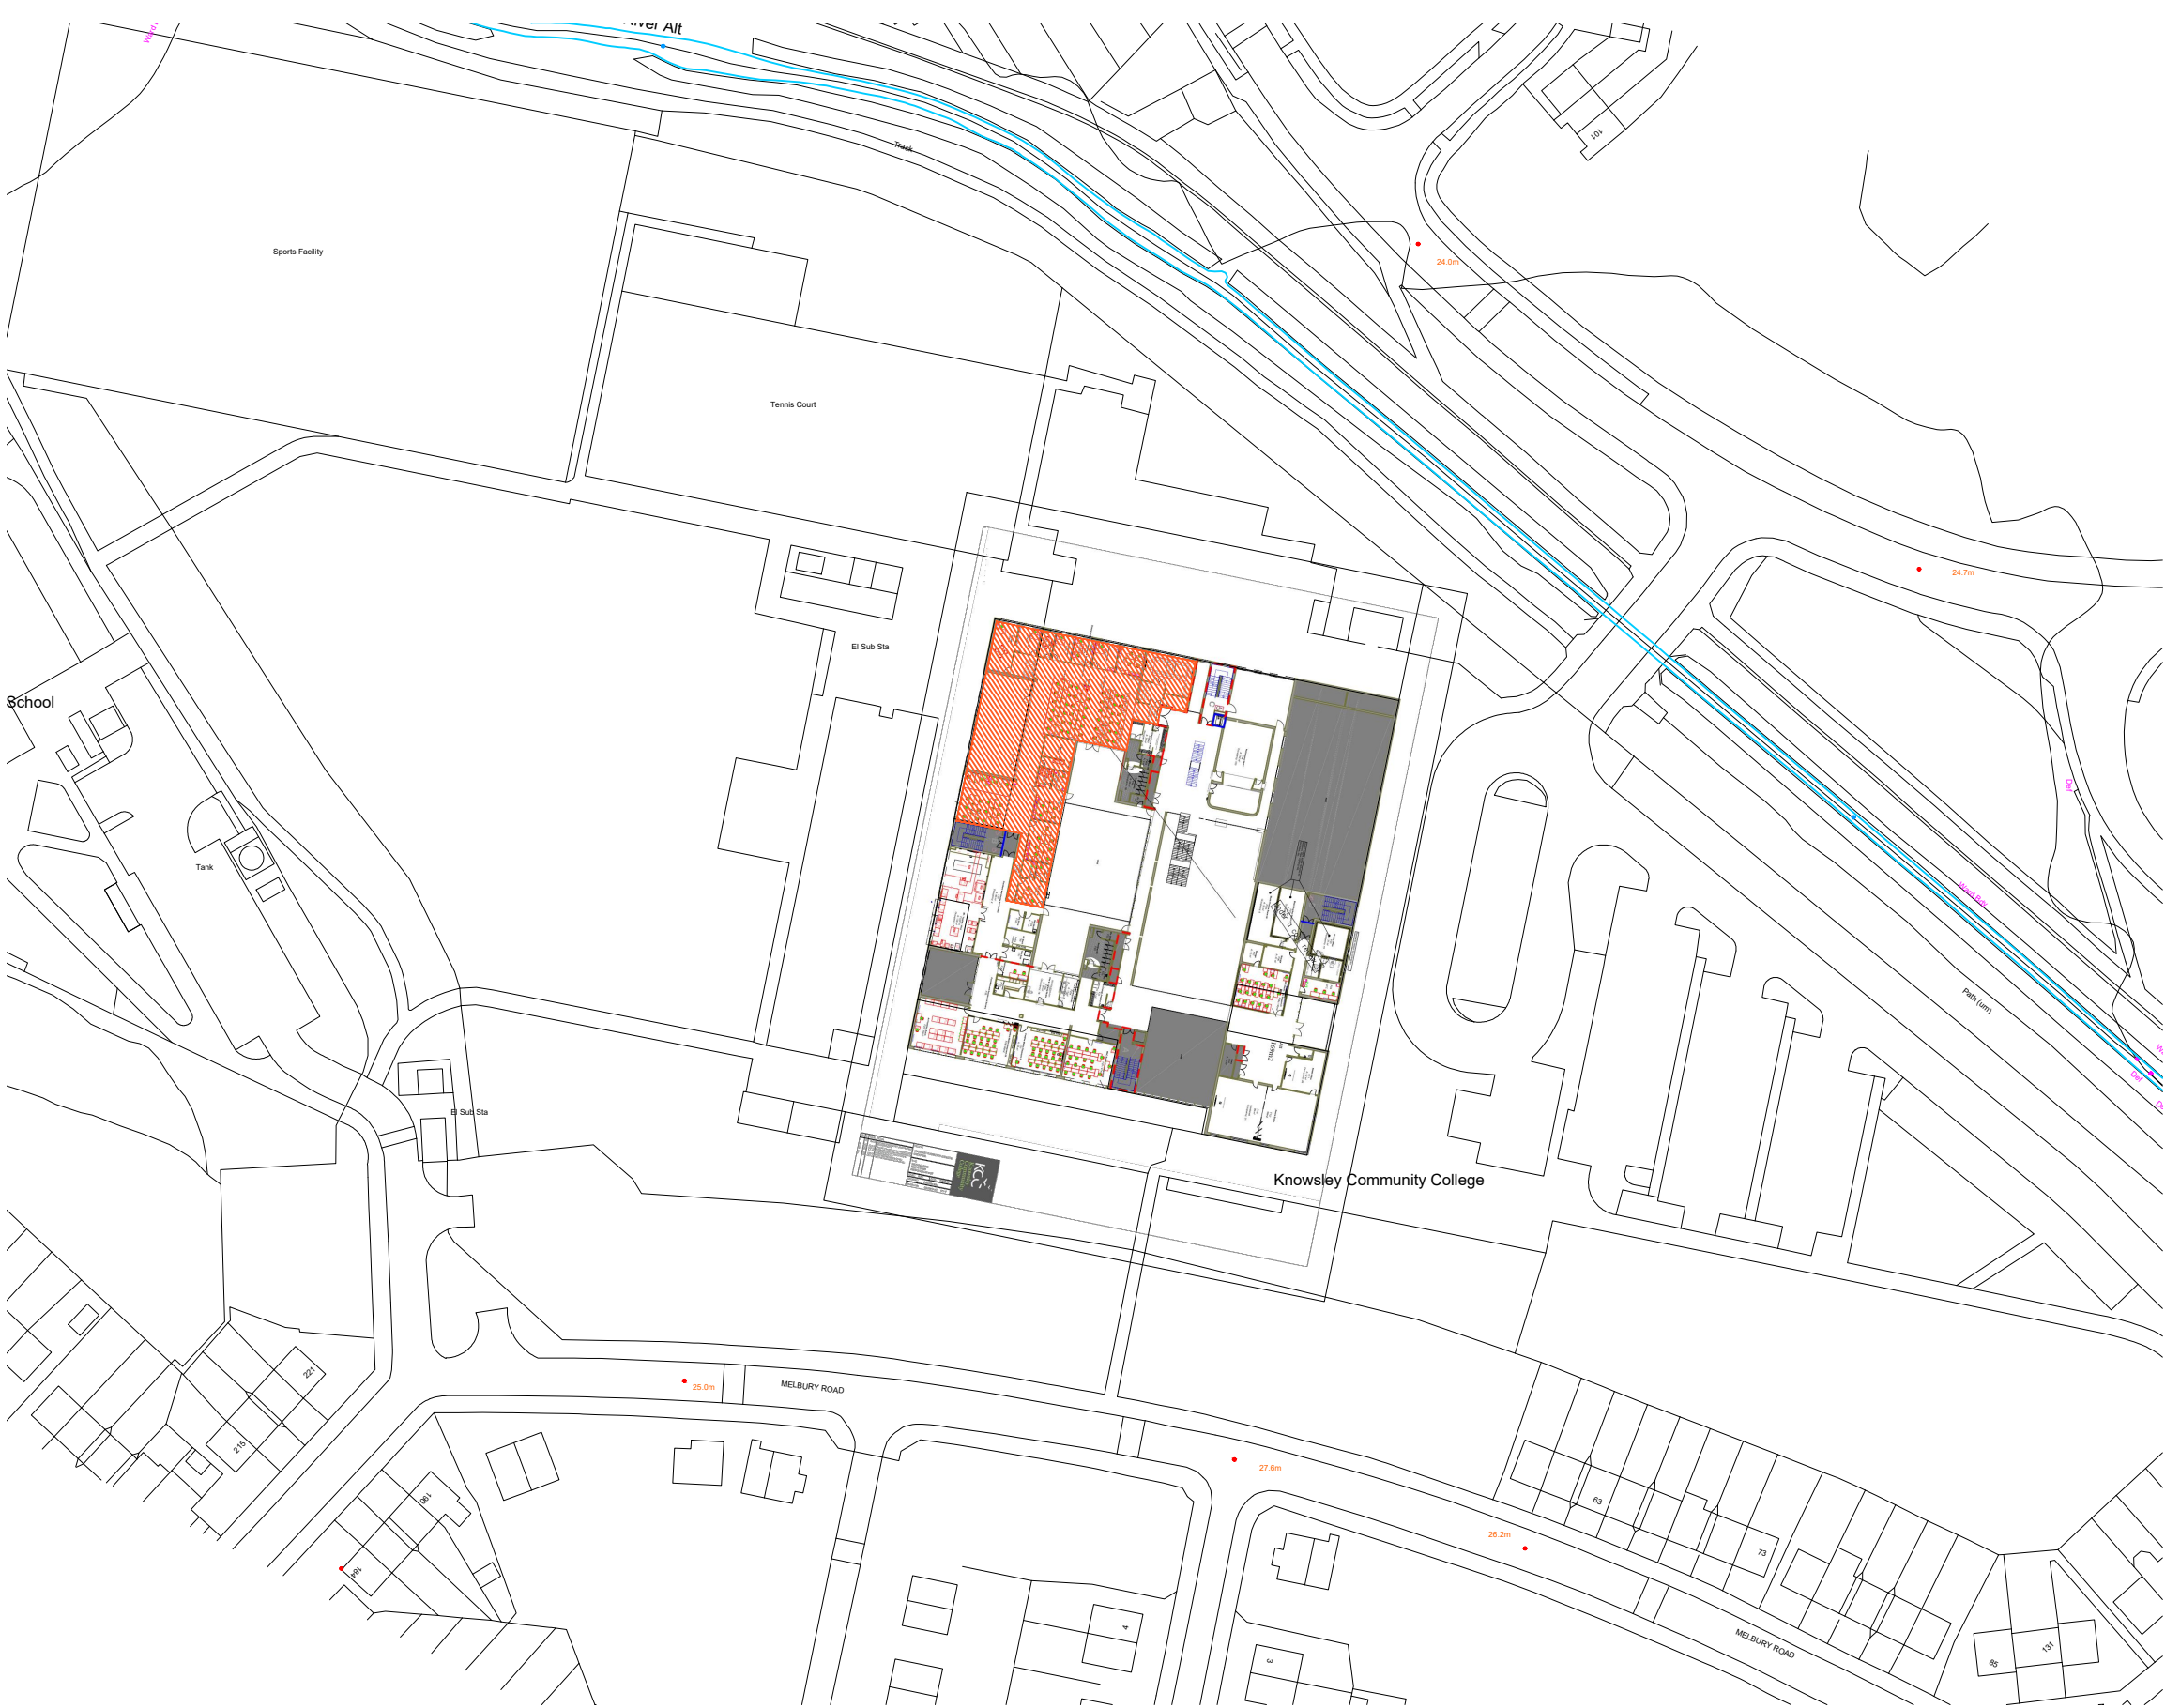

Contractors and consultants are not to scale
dimensions from this drawing

Reproduced by permission of
Ordnance Survey on behalf of HMSO
© CROWN COPYRIGHT and database right 2005
All rights reserved
Ordnance Survey Licence number
AL 1000 17893 Broadway Malyan Limited

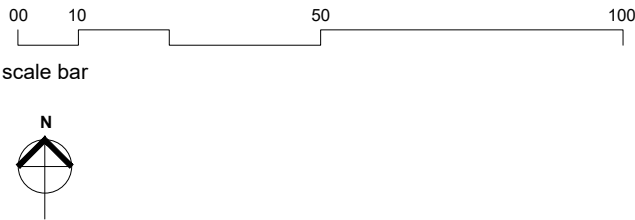

BroadwayMalyan^{BM}

Eastgate, 2 Castle Street
Castlefield, Manchester
M3 4LZ
United Kingdom

T: +44 (0)161 819 2277
F: +44 (0)161 819 2332
E: Man@BroadwayMalyan.com
www.BroadwayMalyan.com

Client
St Helens College

Project
Stockbridge Village 1 NHS Lease

Description
**Site plan
showing NHS area demise at first floor**

A	02.12.21	Initial Issue
Revision	Date	Description
Status		
Planning		
Scale	Drawn By	Date
1250:@A3	ILP	02.12.21
Job Number	Drawing Number	Revision
35450	SV1-A-DR-90-001	A
Original size 100mm @ A3 Copyright Broadway Malyan Limited		