





Apollo LED Lighting

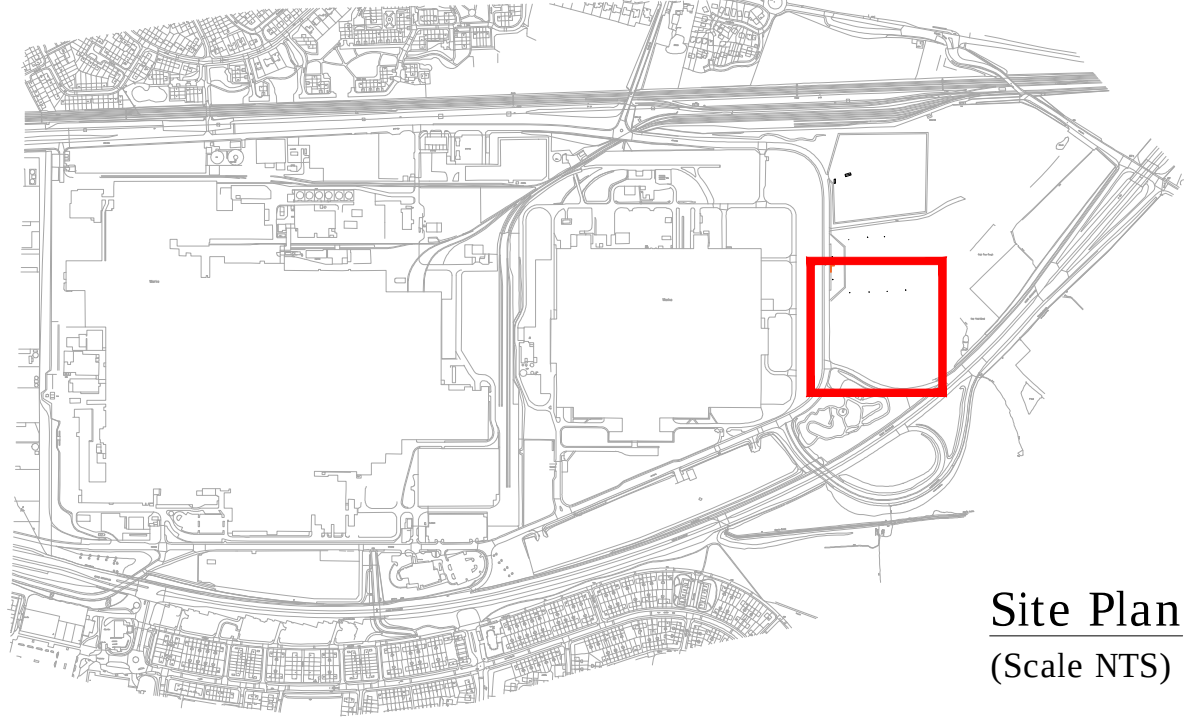

Site Plan  
(Scale NTS)

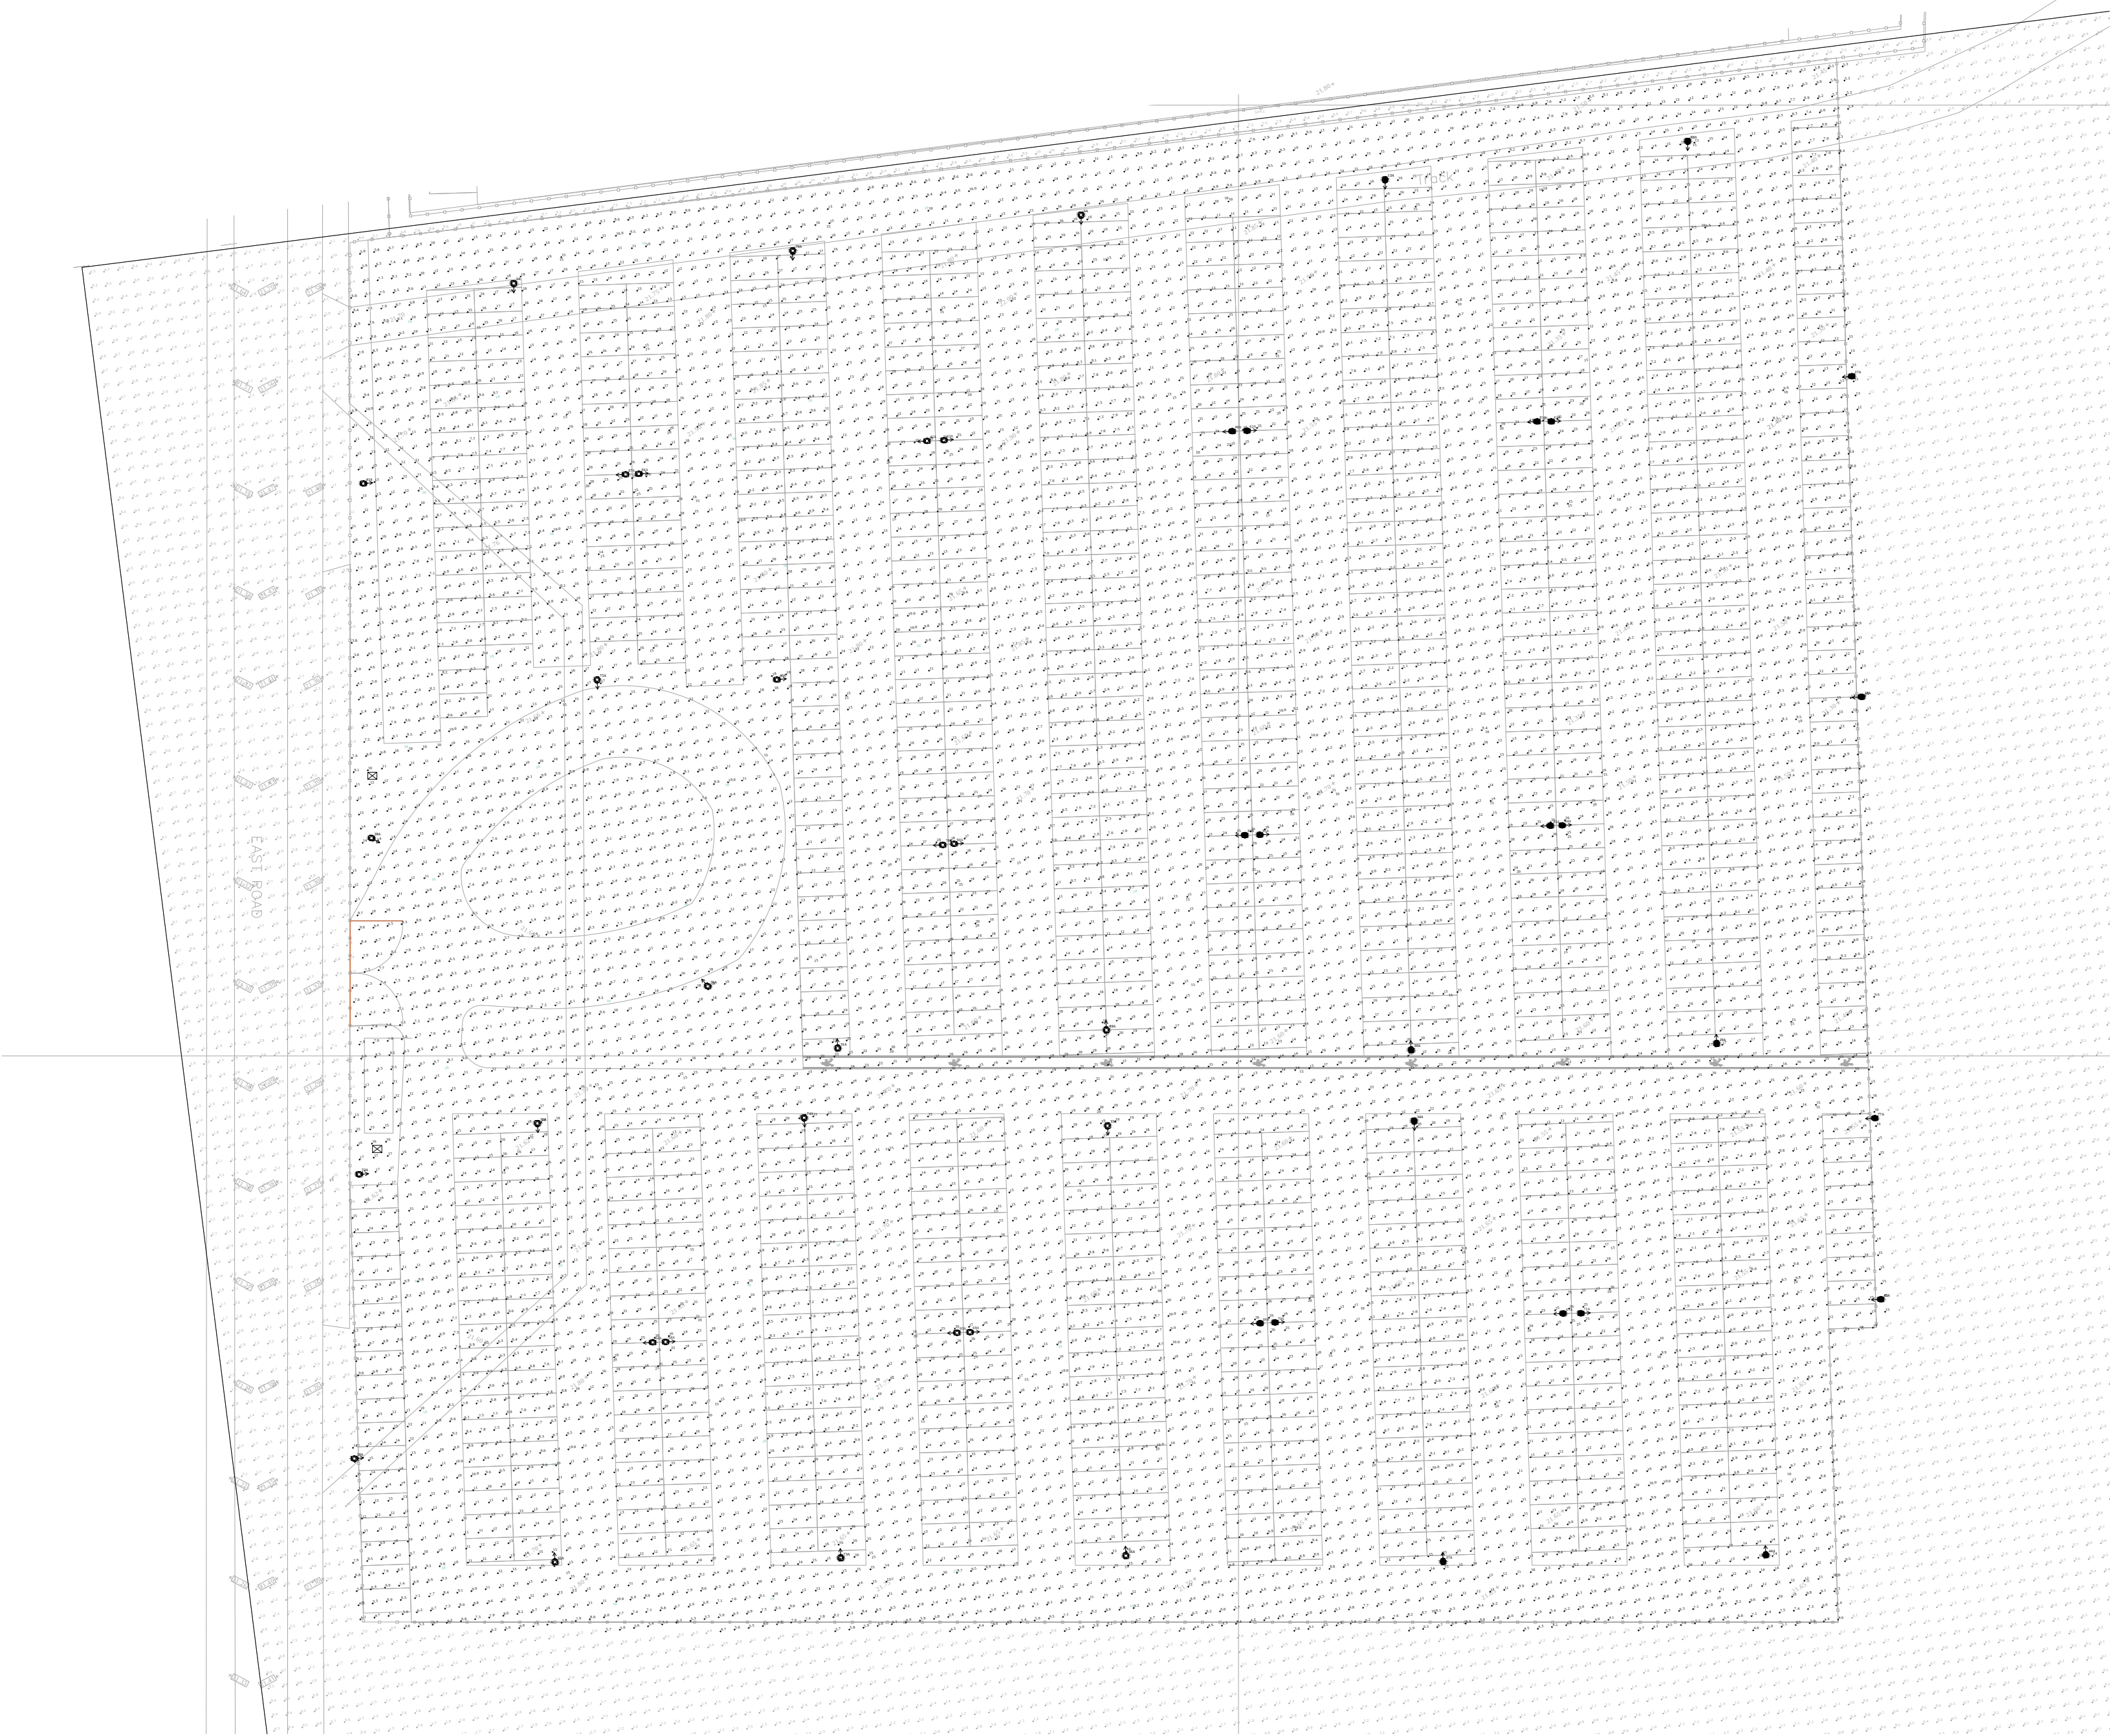

Proposed South Side Car Park

© 2016 WALDECK

- These drawings are copyright and the property of Waldeck Associates Ltd. Copying of the design drawings or intellectual property in full or part is not permitted without the written consent of Waldeck Associates Ltd.
- In the event of a default by the Employer of its obligations due to Waldeck Associates Ltd neither it or its Insurers or Reinsurers are permitted or licensed to sue or copy this document and such time as the Employer has remedied its default and the Contractor gives written consent to reinstatement of its permission to sue in its materials.
- The final liability performance design, specifications, cost plans, bill of quantities, feasibility studies and all other documents or media, whether electronic or hard copy are indicative only and could be subject to changes in statute or other rules and regulations and changes in the Employer's requirements and will be subject to design development and such time as Waldeck's Services are engaged under a formal written agreement that pays for an appropriate fee at commercial rates. Use of these documents or media shall be limited to the risk of the person using it. No reliance on these documents shall be permitted and full copyright is retained by Waldeck. Waldeck accepts no responsibility for reliance on these documents or media and it is assumed that the Contractor or Designer or Client has made sufficient provision for design development risk where it shall design for use hereon. The nature of this engagement shall be provided in writing and signed by a Director of Waldeck or a member of Companies House.
- "Waldeck" is a Trading Style of Waldeck Associates Ltd registered in England and Wales Company N° 3450233.

#### Notes

- Do not scale this drawing.
- All dimensions are in millimetres unless stated otherwise.
- This drawing to be read in conjunction with all other relevant drawings and specifications.
- All proprietary items to be installed in strict compliance with manufacturers instructions and recommendations.

#### External Lighting Notes

- Average illumination - 12.0 lux.
- Uniformity - 0.31
- Car park lighting will be illuminated dusk till dawn by using integral photocells.

| Legend |                                                                                                                             |
|--------|-----------------------------------------------------------------------------------------------------------------------------|
|        | Column A - Abacus lighting, Apollo LED, 60W mounted at 10m with integral photocell control. Number of Luminaires - 28       |
|        | Column B - 2 No. Abacus lighting, Apollo LED, 60W mounted at 10m with integral photocell control. Number of Luminaires - 11 |
|        | Proposed Location of Feeder Pillar for External Lighting                                                                    |

| P2     | Revised to Reduce Column Heights to 10m High | M.B      | Mar 16 |
|--------|----------------------------------------------|----------|--------|
| P1     | Issued for Planning                          | G.B      | Feb 16 |
| Rev    | Amendments                                   | Rev'd by | Date   |
| Client |                                              |          |        |



Project  
Jaguar Land Rover,  
Speke Boulevard, Halewood  
Eastlands Temporary Car Park

Title  
Proposed Lighting  
Layout & Details  
(Part 2 of 2)

|                |                  |                       |          |
|----------------|------------------|-----------------------|----------|
| Job No         | 1516-0353        |                       |          |
| Drawing No     | WDK-SI-E-630-312 |                       |          |
| Status         | Planning         | Rev                   | P2       |
| Scale          | 1:500 @ A1       | Date                  | 29.02.16 |
| Project Leader | M.B              | Drawn By              | G.B      |
|                |                  | Checked By            | M.B      |
|                |                  | Approved for Issue By | A.I      |



| CONSTRUCTION DESIGN AND MANAGEMENT REGULATIONS 2015                                                                                                        |                  |
|------------------------------------------------------------------------------------------------------------------------------------------------------------|------------------|
| THE CONTRACTORS ATTENTION IS DRAWN TO THE ABNORMAL RISKS IDENTIFIED BELOW, ANNOTATED ON THE DRAWING AND EXPLAINED IN THE ASSOCIATED DESIGN RISK REGISTERS. |                  |
| LEGEND                                                                                                                                                     |                  |
|                                                                                                                                                            | YOU MUST NOT DO  |
|                                                                                                                                                            | HAZARD OR DANGER |
|                                                                                                                                                            | YOU MUST DO      |
|                                                                                                                                                            | CAUTION          |
| ABNORMAL RISKS IDENTIFIED:                                                                                                                                 |                  |
| 1. NO ABNORMAL RISKS IDENTIFIED                                                                                                                            |                  |