


Key

Translucent triple skin non-fragile factory assembled polycarbonate roof lights to provide a min 15% coverage of roof area

Photovoltaic Provision of TBCm² required to assist achieving EPC A rating

Roof Access Hatches

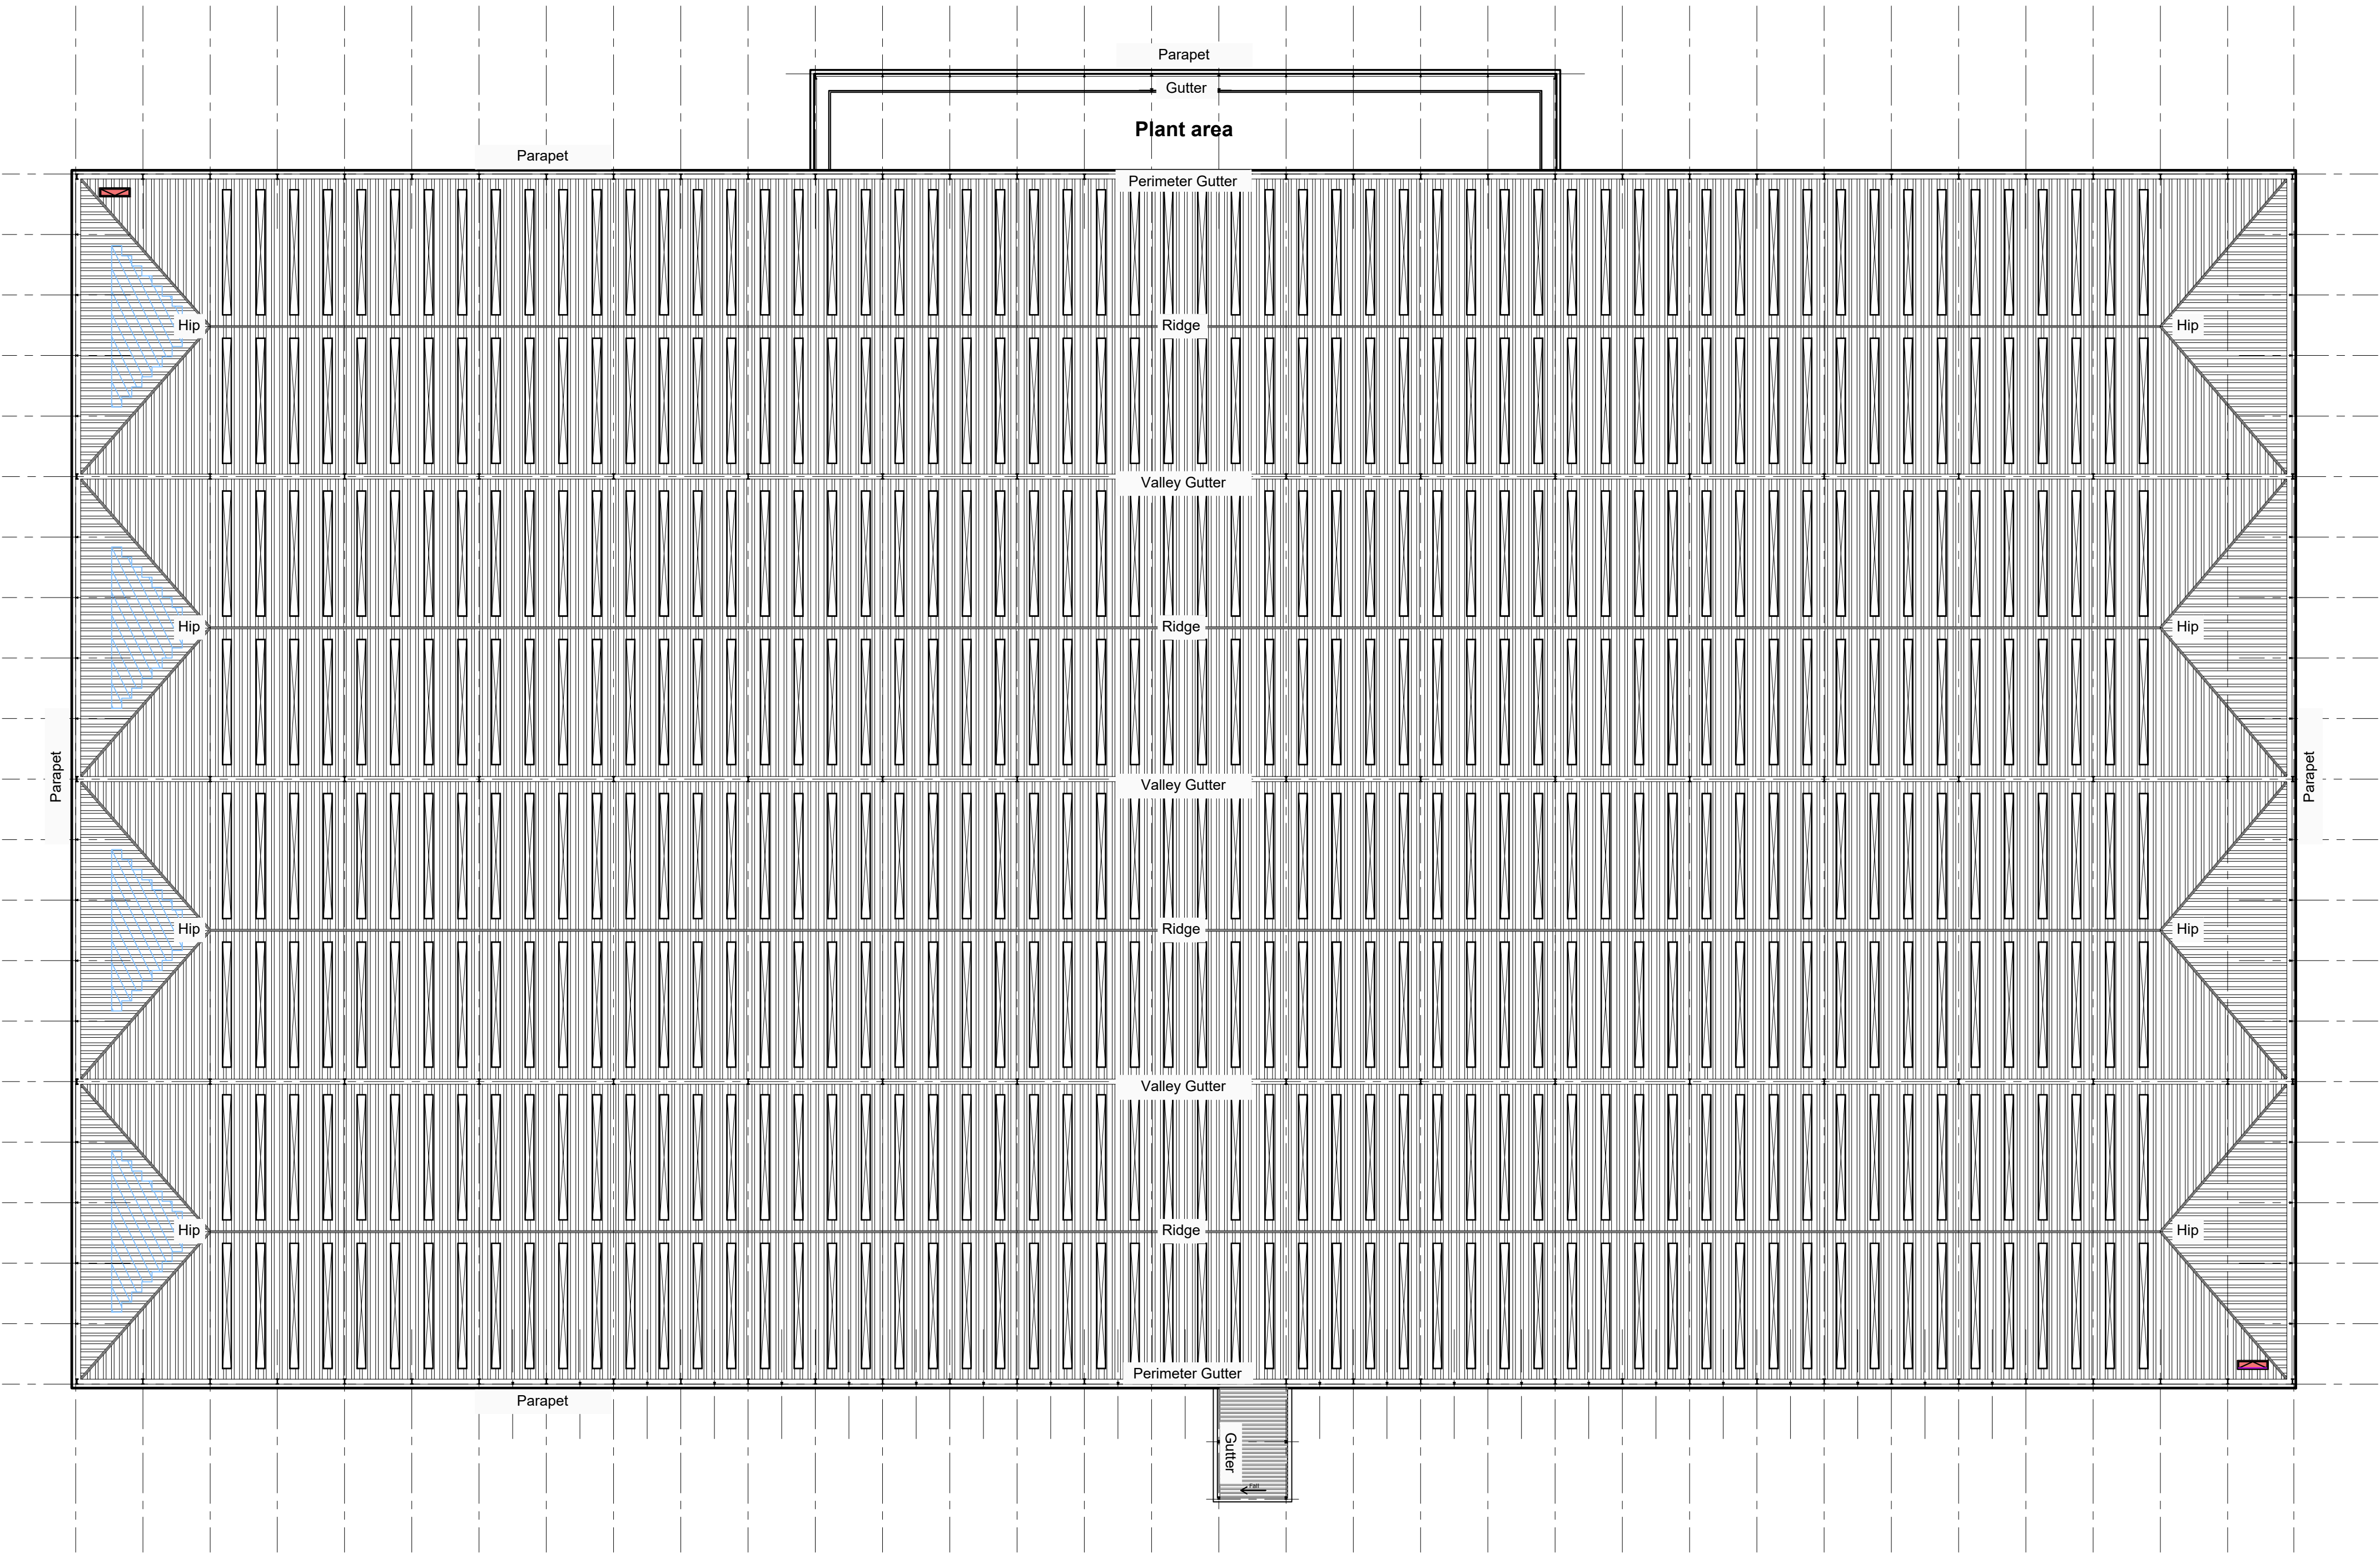

Proposed Roof Plan
Scale 1:500

P1	Issued For Planning	MS	AD	15.12.22
rev	amendments	by	ckd	date

Deacon Business Park, Knowsley

Proposed Roof Plan

Information Container LOD:	LOD 200
----------------------------	---------



RIBA PoW Stage:	3 - Spatial Coordination
Document Suitability:	S3
Drawn / Checked:	MS / AD
Date:	13/10/2022
Scale:	As Drawn @A1
UMC Project Number:	21241
Document Reference:	Drawing no: Revision:
21241 - UMC - 0001 - RF - DR - A	1002 P1

PLANNING
THIS DRAWING IS TO BE USED FOR THE STATED PURPOSE ONLY AND SHOULD NOT BE USED FOR ANY OTHER