



NOTES:

1. ALL DIMENSIONS IN MM UNLESS OTHERWISE NOTED.

Model:	MBNL / EE / H3G	Project:	Purpose of Issue:	Issue:
M001	H3G	DENSIFICATION SW	Planning	A
Date:	06/03/2023	Revision / Update Description:	First Issue - Site nomination dated: 13.02.2023	
Drawn:	R. Sweeney	Checked:	G. Thomas	
Approved:	G. Thomas			



Hutchison 3G UK Limited
Green Park, 450 Longwater Avenue
Reading, RG30 3UR
Tel: 01628 765 000
Fax: 01628 765 001

H3G Base Station Information line:
0845 6043000
Available 8am-8pm Monday to Friday

Design Consultant & Principal Contractor:

CLARKE
telecom
Unit 1, Madison Place, Northampton Road,
Manchester, M40 5AG
Tel: 0161 785 4500 Fax: 0161 785 4501
Web: www.clarke-telecom.com

Site Name:

WATERPARK DRIVE

Site ID:

KSY25766

Address:

WATERPARK DRIVE
STOCKBRIDGE VILLAGE
LIVERPOOL
L28 7RD

File:

100 EXISTING H3G SITE PLAN

Project:

H3G DENSIFICATION STREETWORKS

Purpose of Issue:

PLANNING


MBNL Cell ID:	3UK Cell ID:
KSY102	L1050

Master Drawing No:

KSY25766_KSY102_L1050_M001

Issue:

A

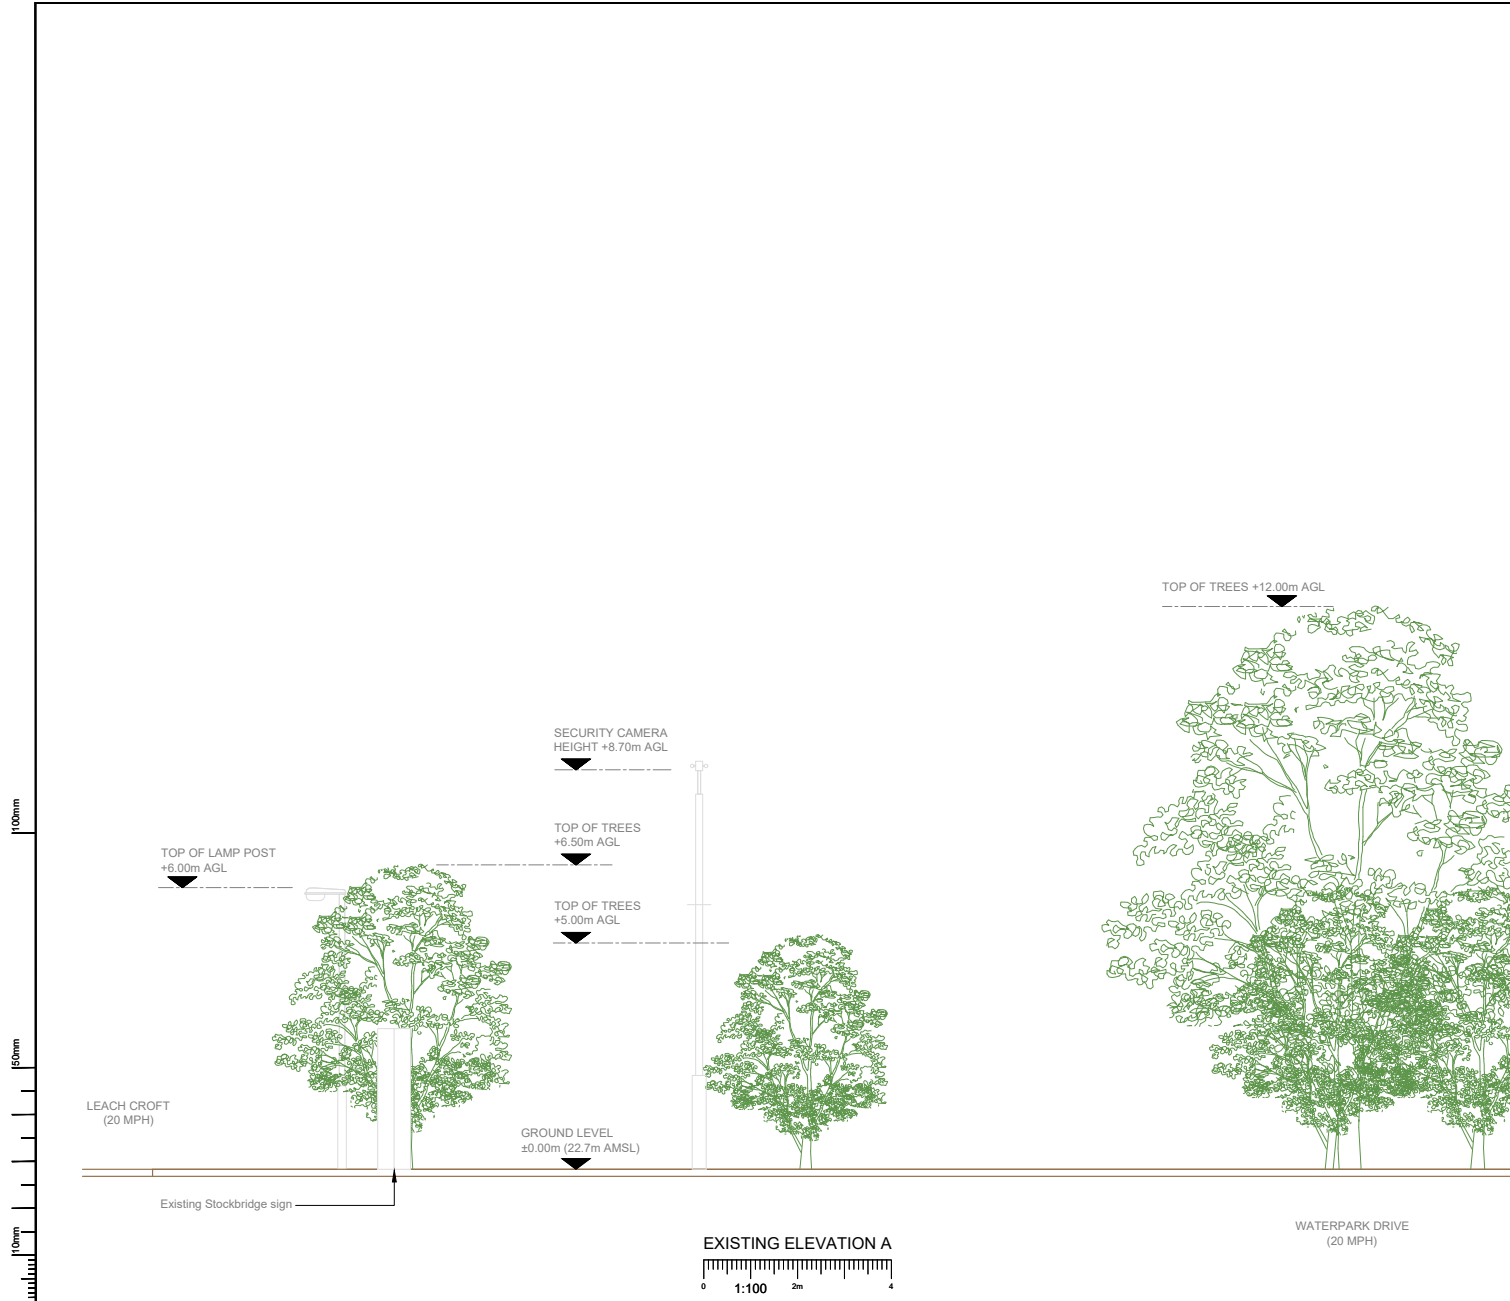

NOTES:

1. ALL DIMENSIONS IN MM UNLESS OTHERWISE NOTED.

Model:	MBNL / EE / H3G	Project:	DENSIFICATION SW	Purpose of Issue:	Planning	Issue:	A
M001	H3G	Date:	06/03/2023	Revision / Update Description:	First Issue - Site nomination dated: 13.02.2023		
Drawn:	R. Sweeney	Checked:	G. Thomas				
Approved:	G. Thomas						

Hutchison 3G UK Limited
 Green Park, 450 Longwater Avenue
 Reading, RG30 3UR
 Tel: 01628 765 000
 Fax: 01628 765 001

H3G Base Station Information line:
 0845 6043000
 Available 8am-8pm Monday to Friday

Design Consultant & Principal Contractor:

CLARKE telecom
 Unit 1, Madison Place, Northampton Road,
 Manchester, M40 5AG
 Tel: 0161 785 4500 Fax: 0161 785 4501
 Web: www.clarke-telecom.com

Site Name: WATERPARK DRIVE

Site ID: KSY25766

Address: WATERPARK DRIVE
 STOCKBRIDGE VILLAGE
 LIVERPOOL
 L28 7RD

Title: 150 EXISTING H3G ELEVATION


Project: H3G DENSIFICATION STREETWORKS

Purpose of Issue: PLANNING

MBNL Cell ID:	UK Cell ID:
KSY102	L1050

Master Drawing No: KSY25766_KSY102_L1050_M001

Issue: A

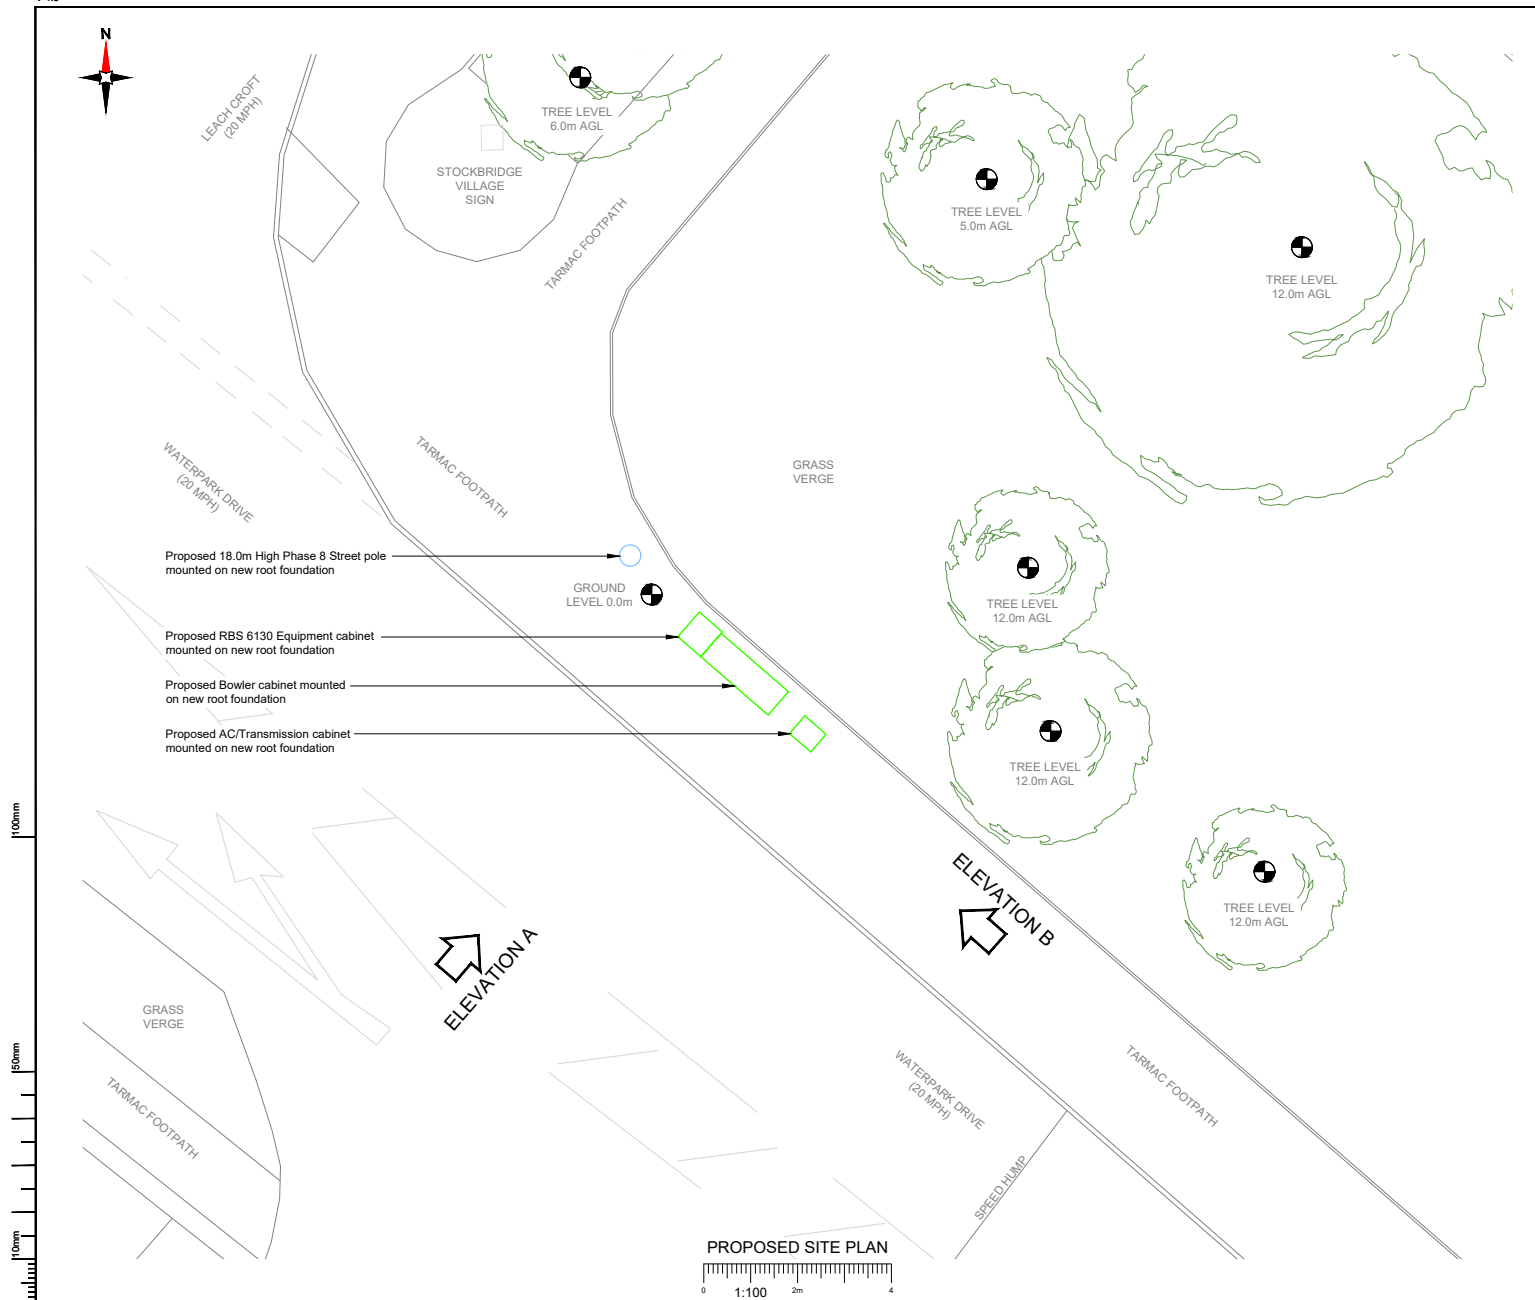

NOTES:

1. ALL DIMENSIONS IN MM UNLESS OTHERWISE NOTED.

Model:	MBNL / EE / H3G	Project:	Purpose of Issue:	Issue:
M001	H3G	DENSIFICATION SW	Planning	A
Date:	06/03/2023	Revised / Update Description:		
Drawn:	R. Sweeney	First Issue - Site nomination dated:	13.02.2023	
Checked:	G. Thomas			
Approved:	G. Thomas			



Hutchison 3G UK Limited
Green Park, 450 Longwater Avenue
Reading, RG30 3UR
Tel: 01628 765 000
Fax: 01628 765 001

H3G Base Station Information line:
0845 6043000
Available 8am-8pm Monday to Friday

Design Consultant & Principal Contractor:

CLARKE
telecom
Unit 1, Madison Place, Northampton Road,
Manchester, M40 5AG
Tel: 0161 785 4500 Fax: 0161 785 4501
Web: www.clarke-telecom.com

Site Name: WATERPARK DRIVE

Site ID: KSY25766

Address:
WATERPARK DRIVE
STOCKBRIDGE VILLAGE
LIVERPOOL
L28 7RD

File: 210 PROPOSED H3G SITE PLAN

Project: H3G DENSIFICATION STREETWORKS

Purpose of Issue: PLANNING

MBNL Cell ID:	SUK Cell ID:
KSY102	L1050

Master Drawing No: KSY25766_KSY102_L1050_M001

Issue: A

