


Notes:

Proposed electrical

-  Double socket
-  Distribution board
200amp 3 phase

 LED lamps

White box fit out, move
mains DB to wall from
under stairs, meter will
have to remain
200amp 3 phase
supply.

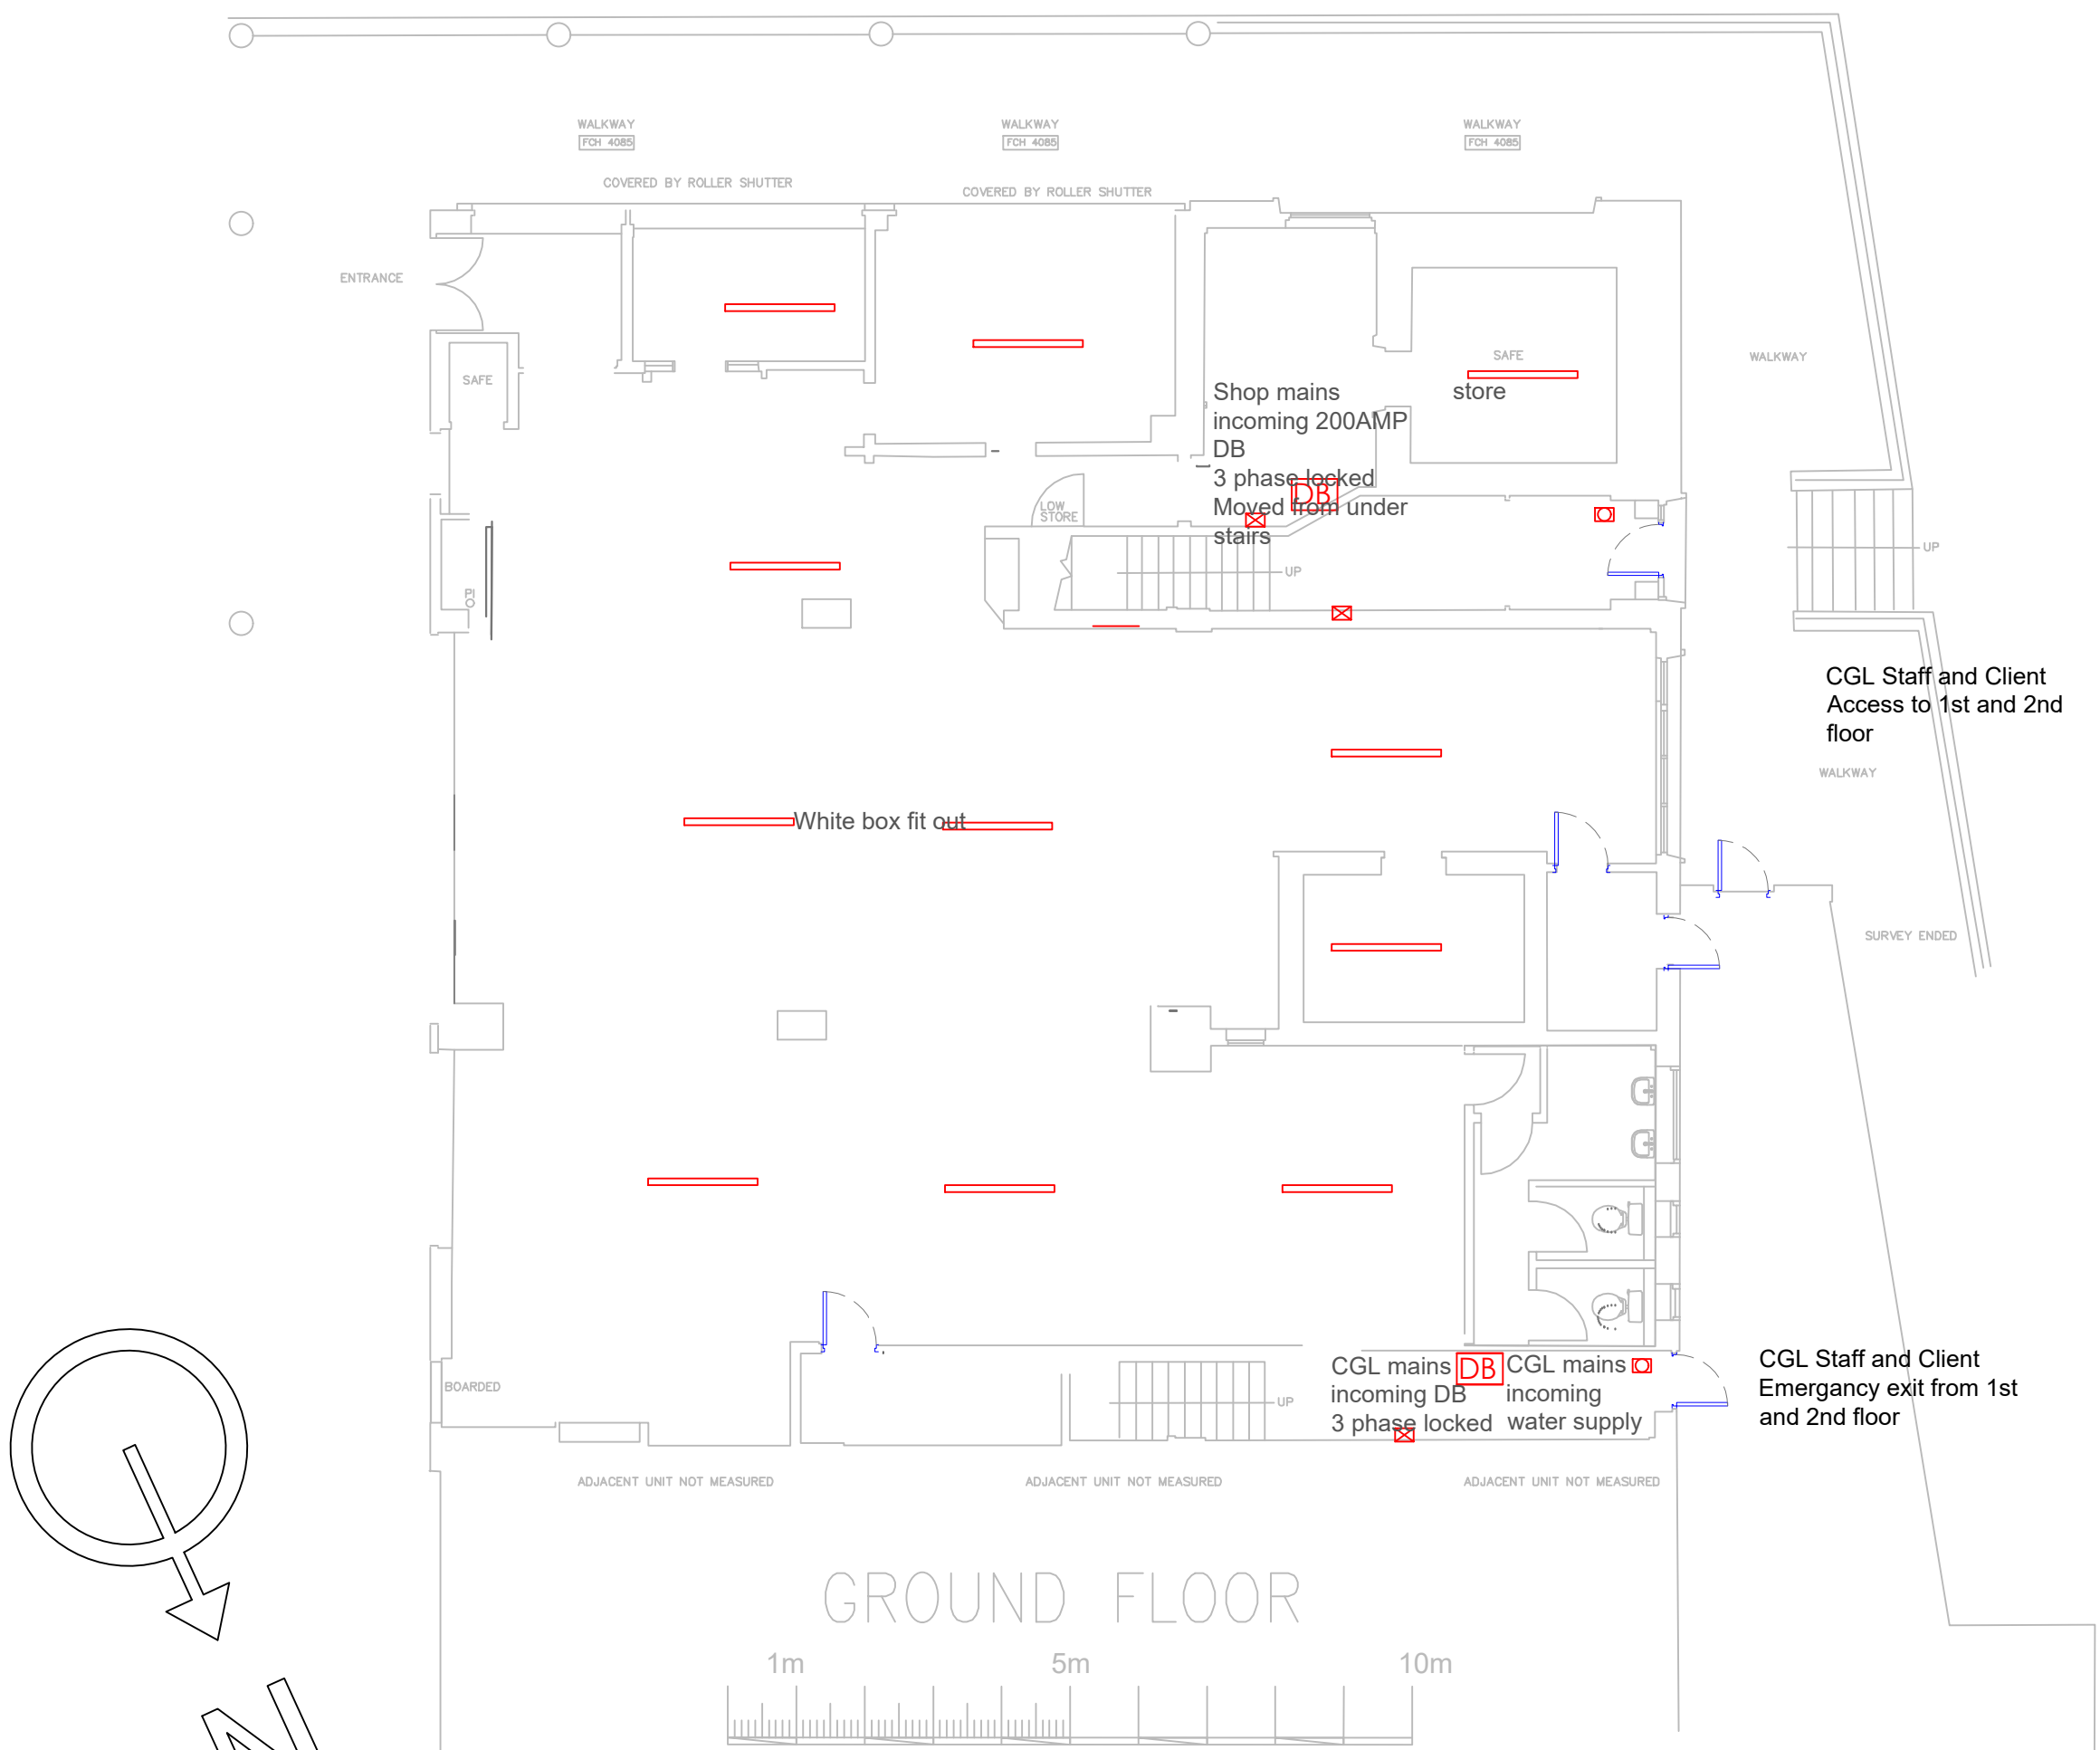

ELECTRICAL GROUND FLOOR PLANS

Change Grow Live

Site Address:
22-24 Newtown Gardens Kirkby

Drawn by:
Andy Hills

Date: **26.11.27** Scale: **1:100@A3**

Drawing/Page Number/Name:
13 - ELECTRICAL GROUND