


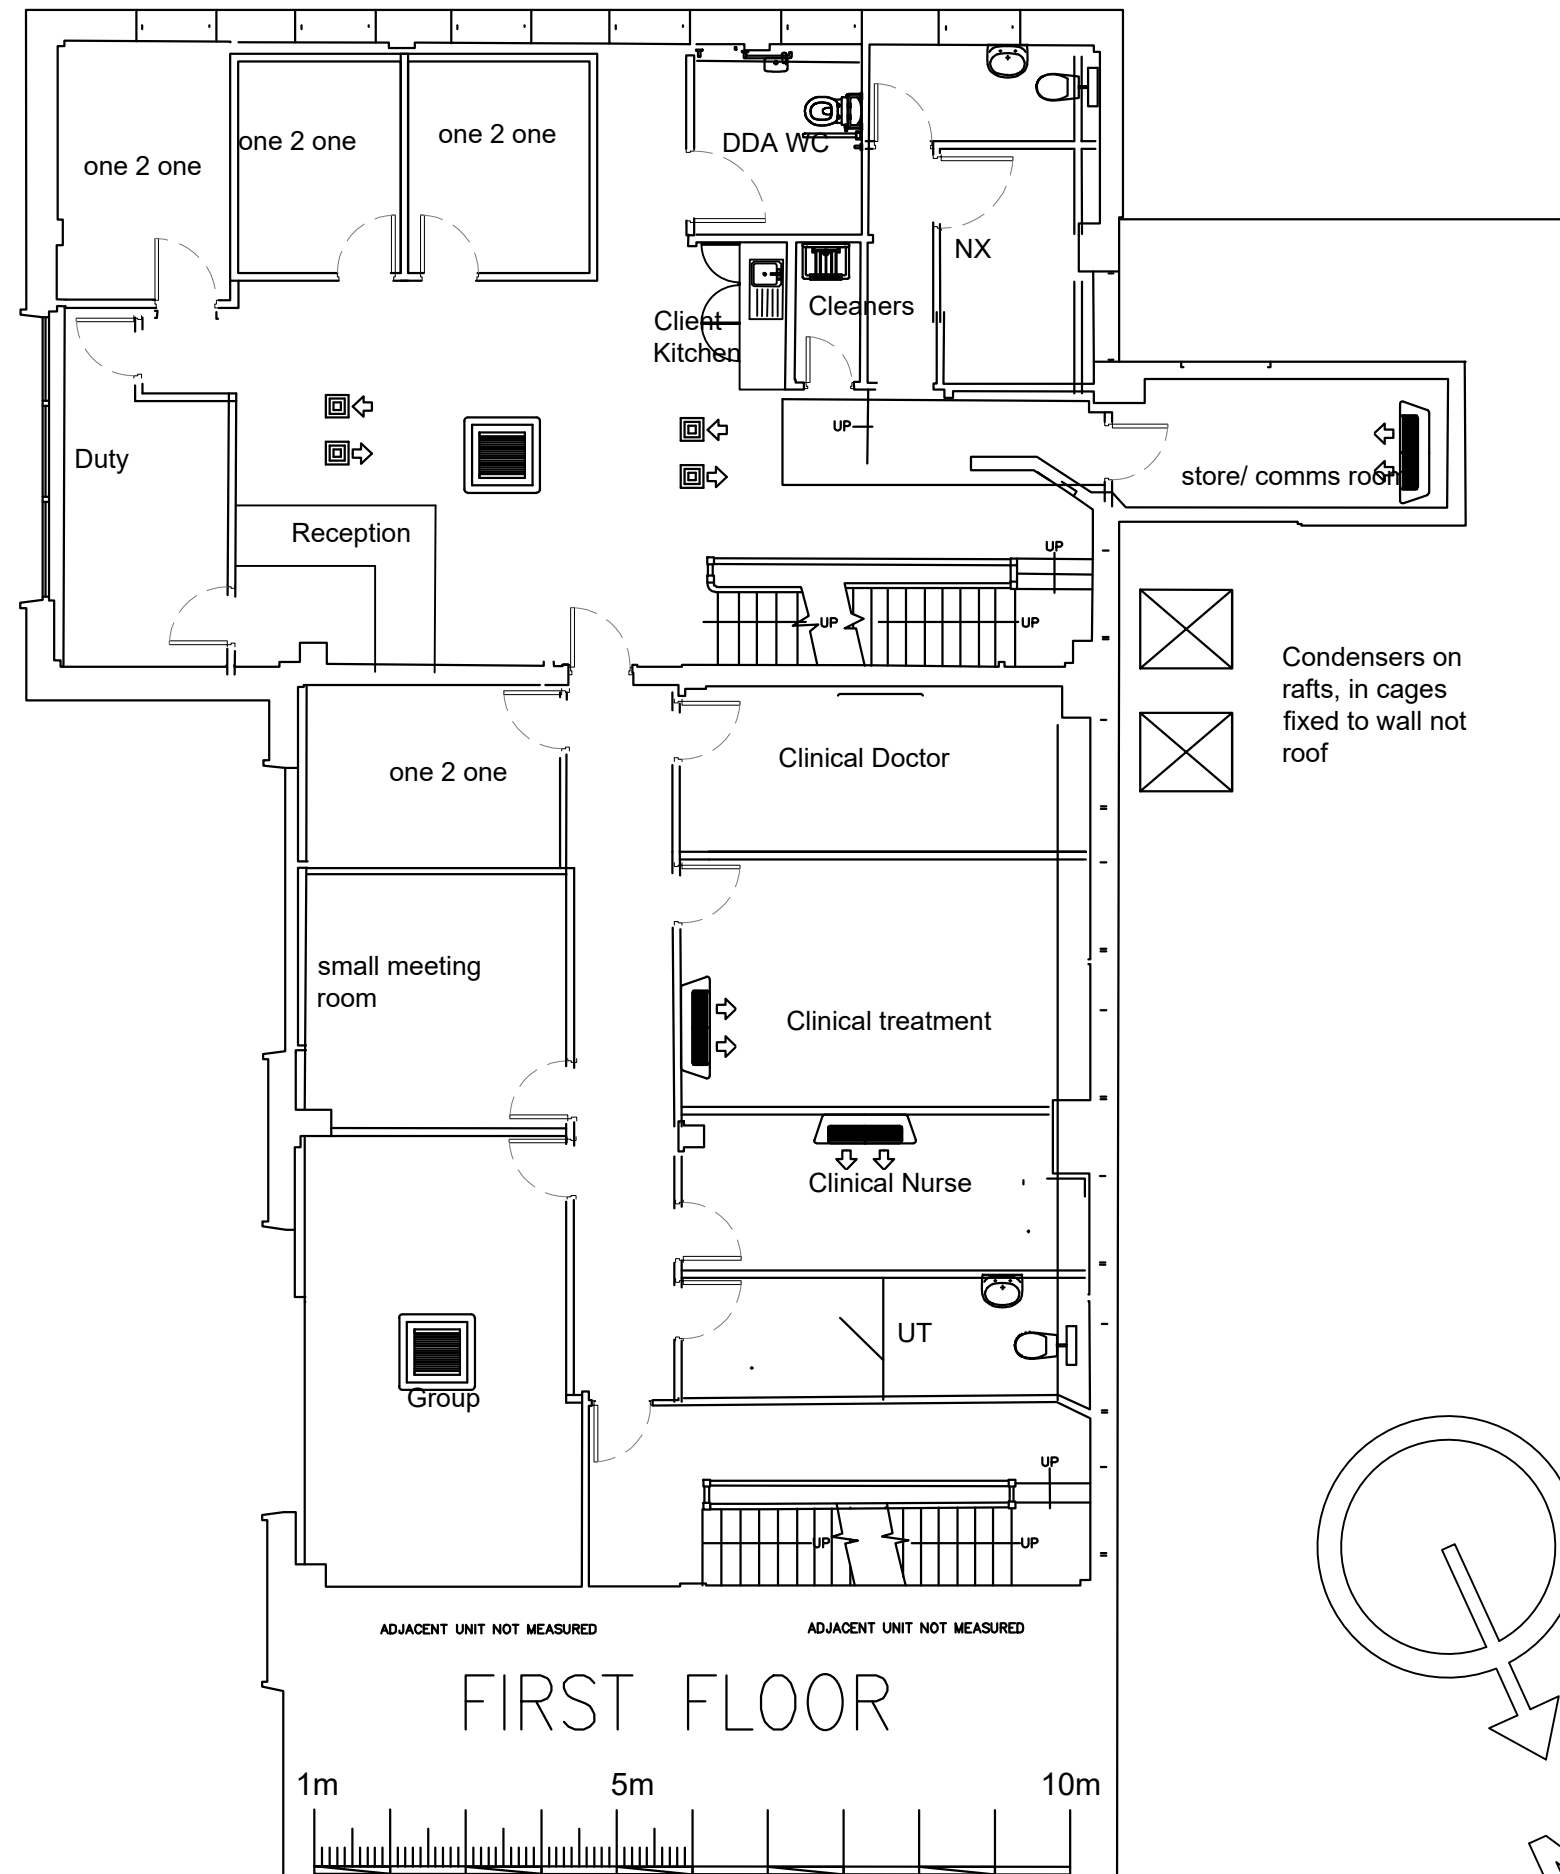

Notes:

Proposed Aircon

-  Condenser
-  Ceiling mounted cassette
-  Wall mounted cassette
-  air exchange

AIR EXCHANGES TO BE PROVIDED BY INSTALLER

Change Grow Live

Site Address:
22-24 Newtown Gardens Kirkby

Drawn by:
Andy Hills

Date: **26.11.27** Scale: **1:100@A3**

Drawing/Page Number/Name:

AIRCON & VENTILATION FIRST FLOOR PLANS