




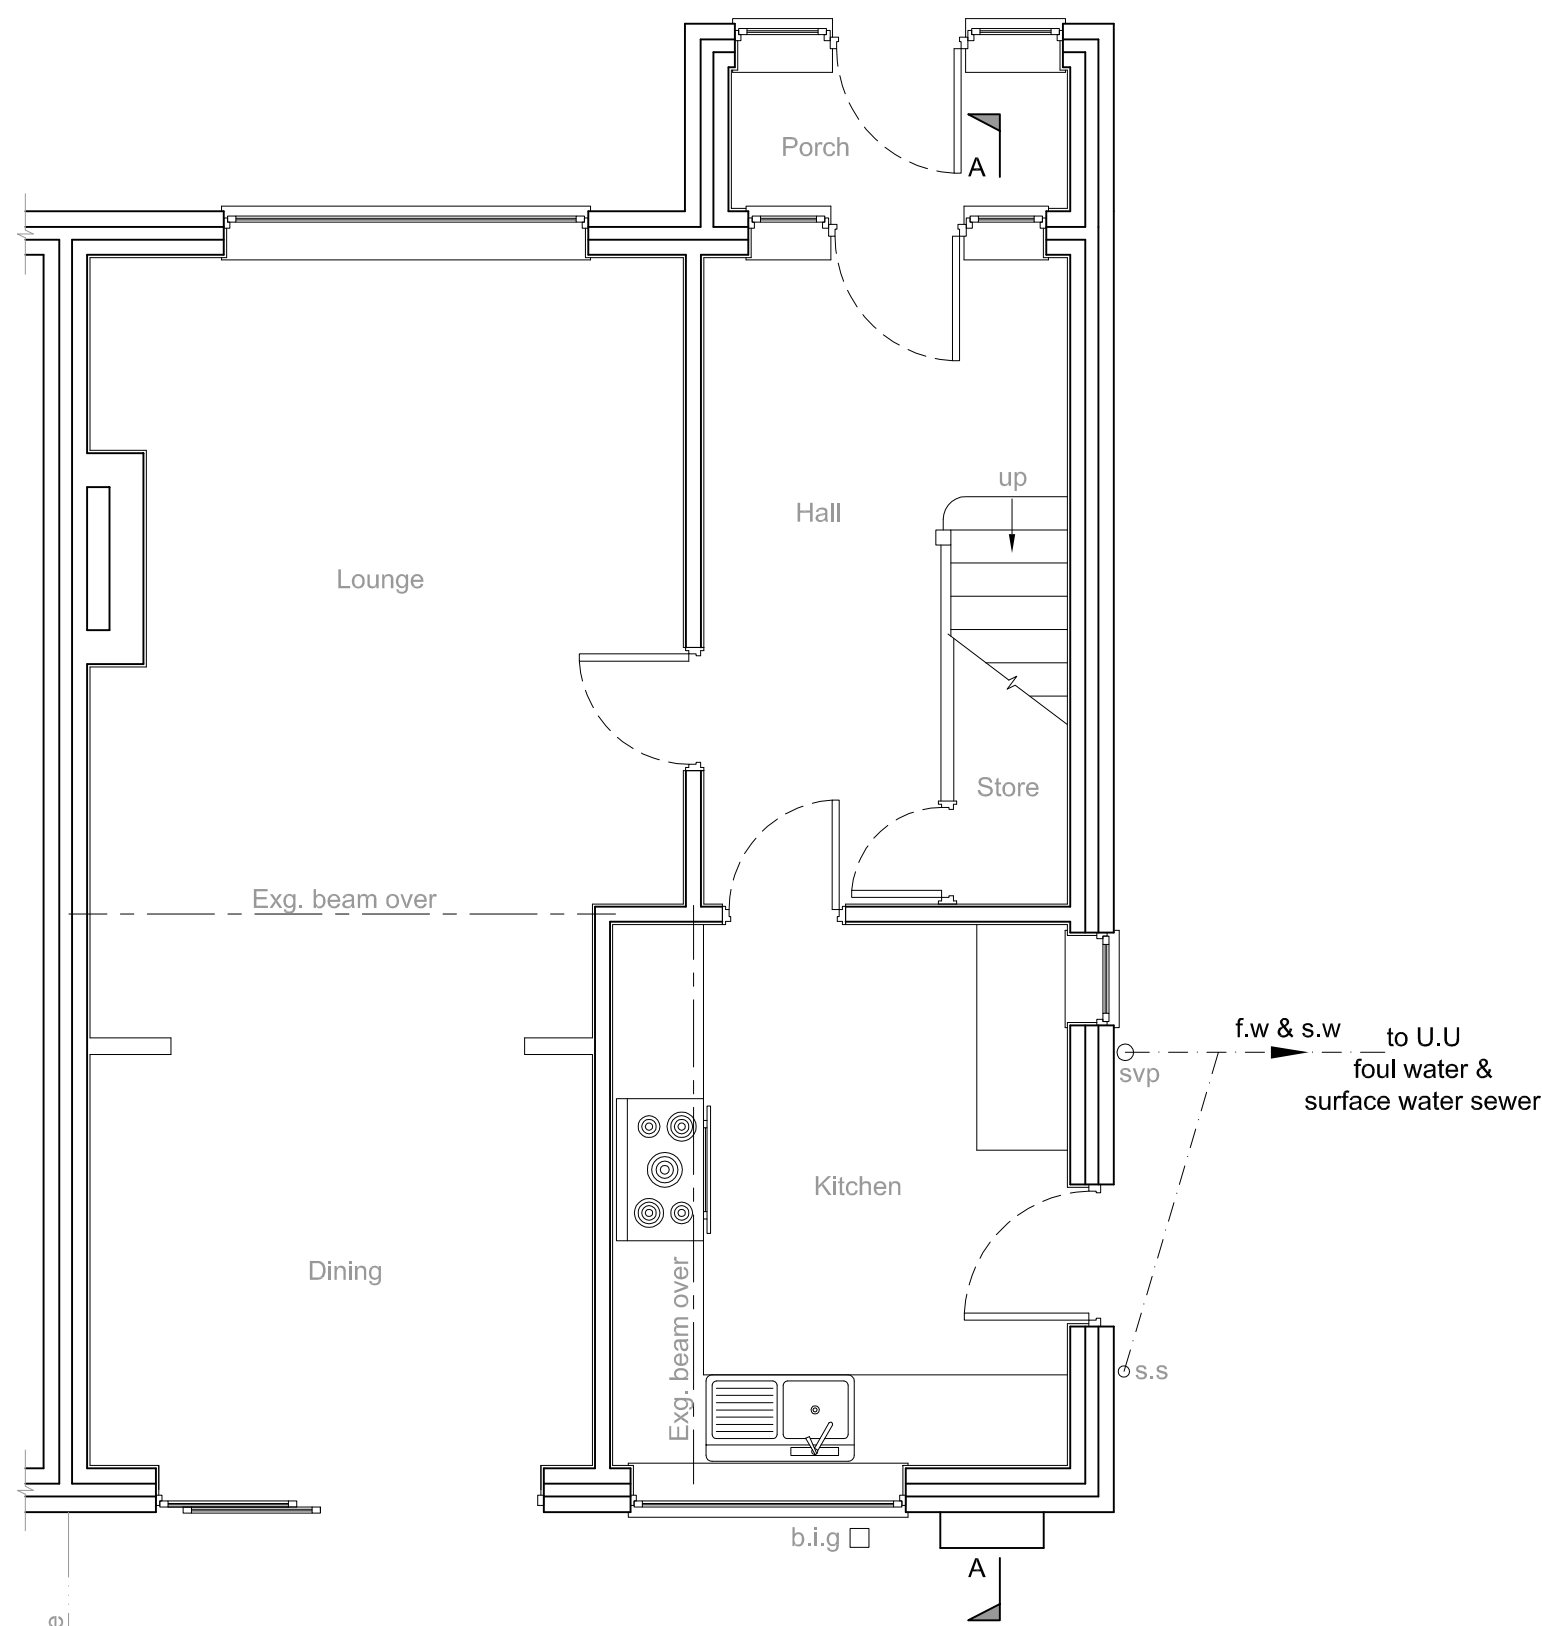

EXISTING GROUND FLOOR PLAN
scale 1:50

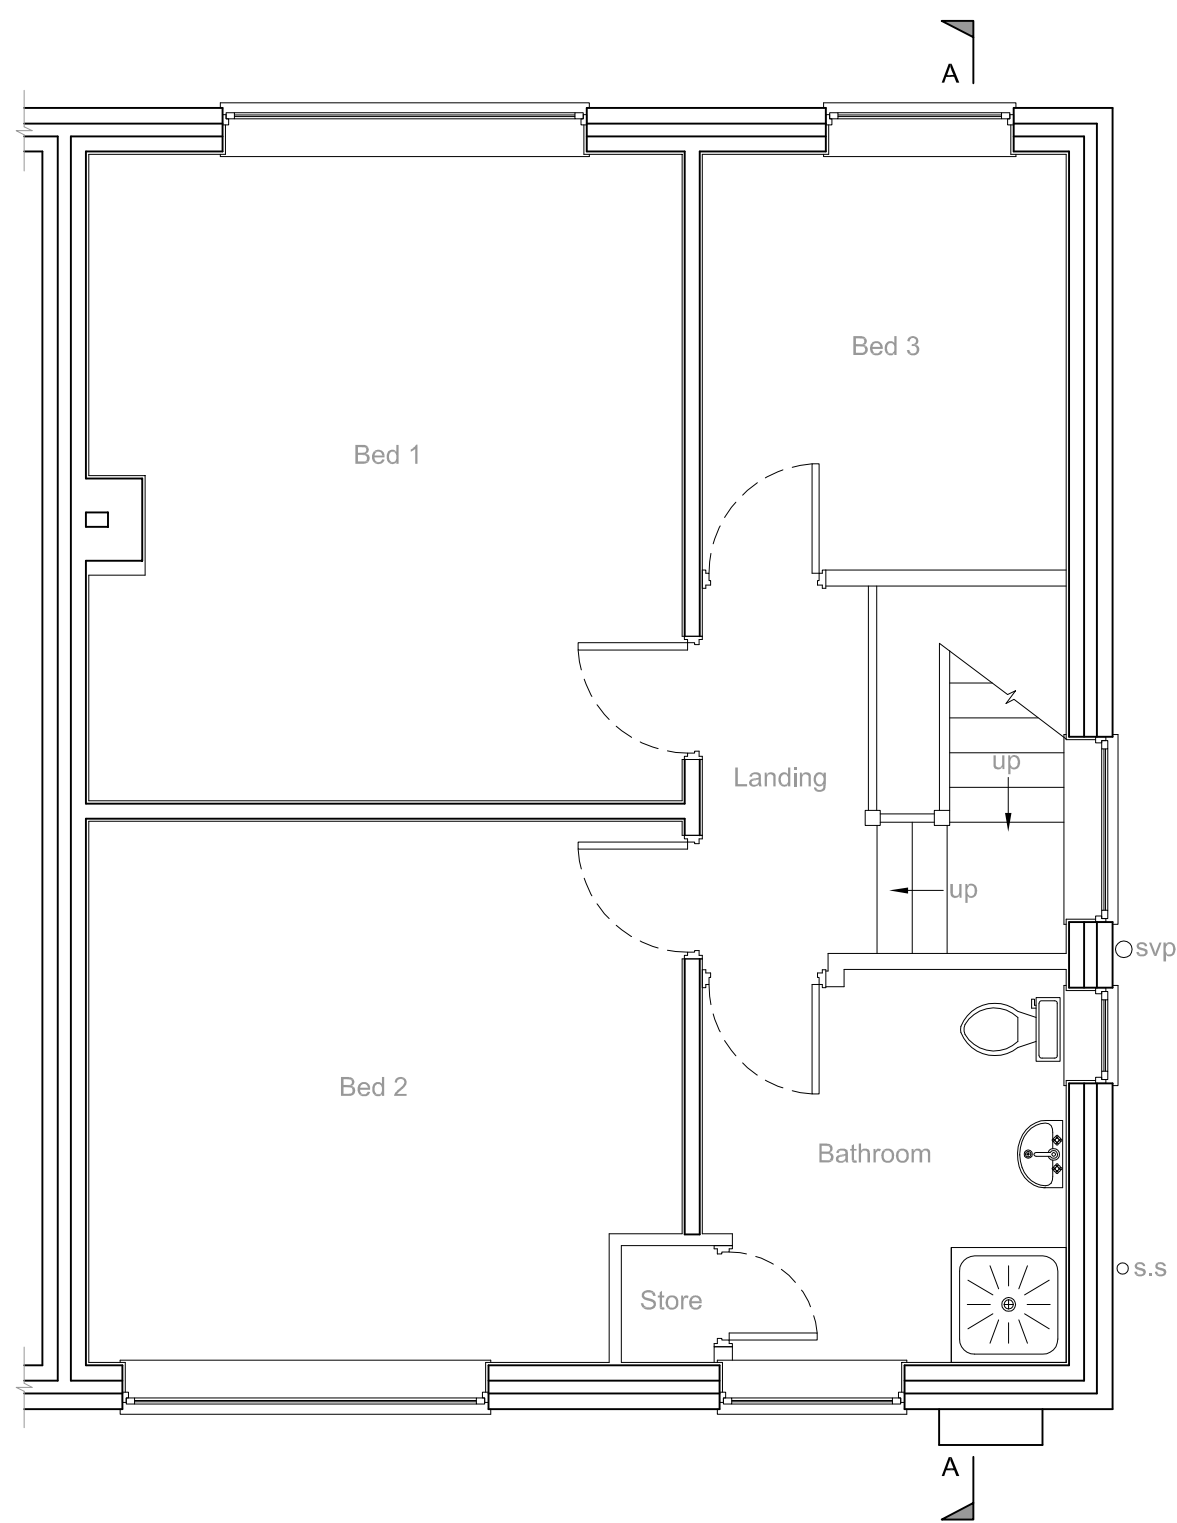


EXISTING FIRST FLOOR PLAN
scale 1:50

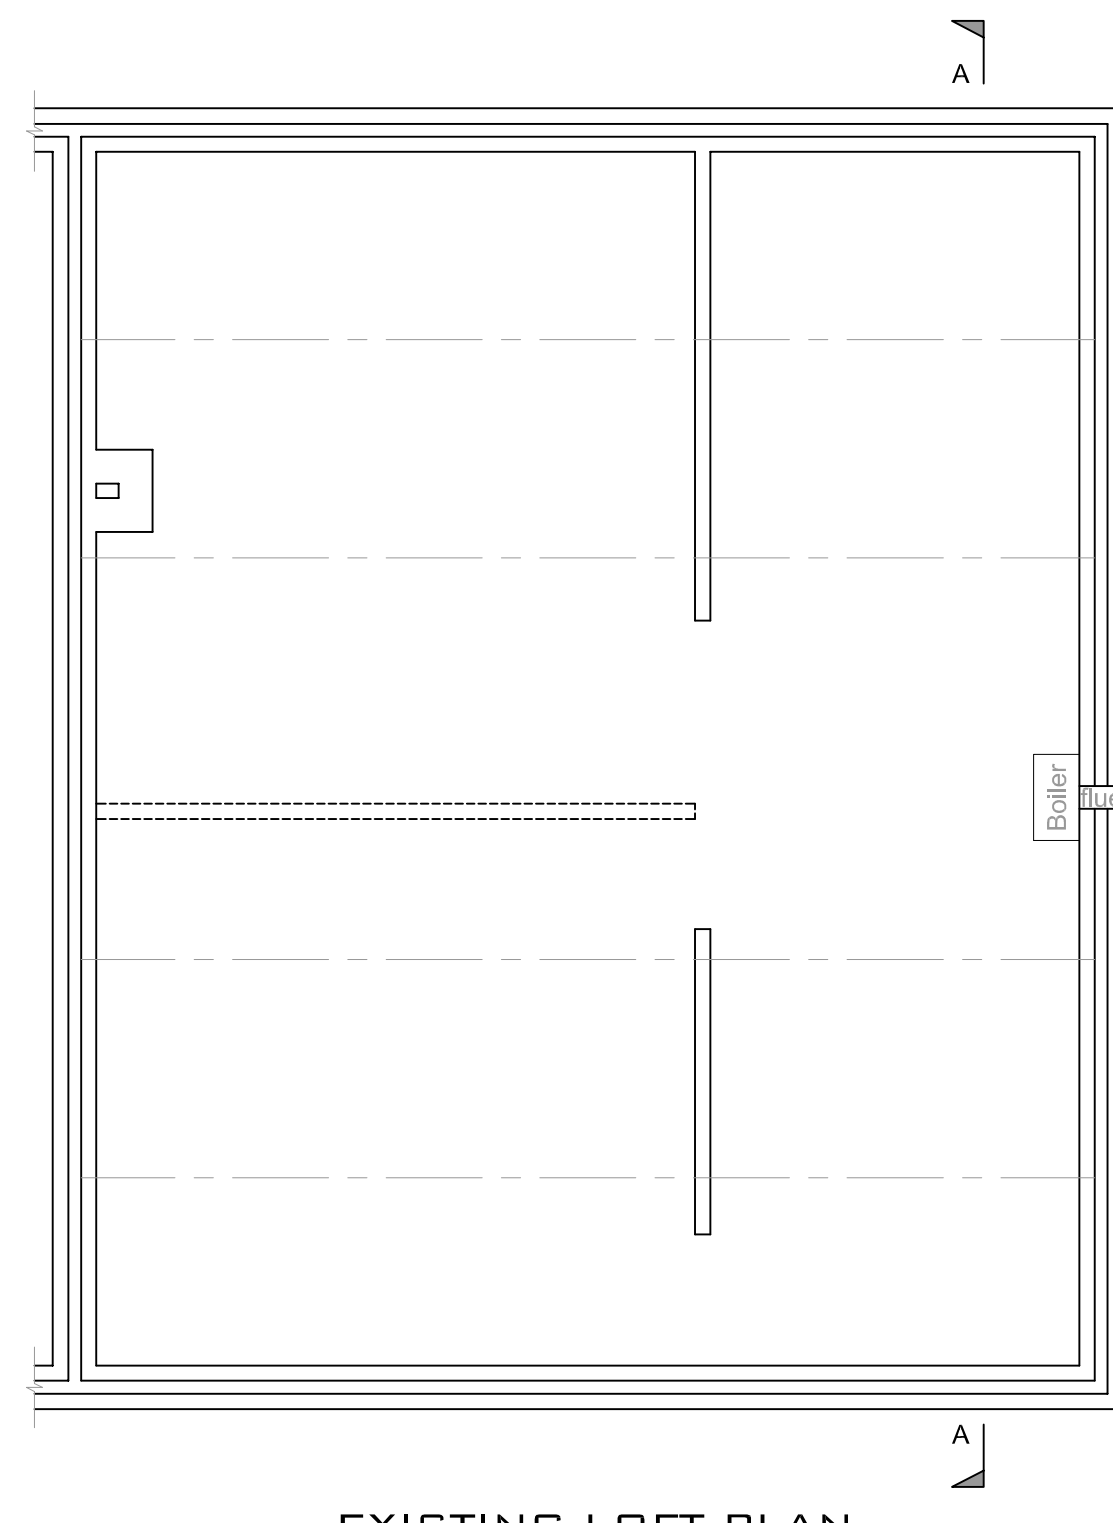


EXISTING LOFT PLAN
scale 1:50


KEY	
Foul water & Surface water drains	f.w & s.w
Rain water pipe	r.w.p
Back inlet gully	b.i.g
Soil vent pipe	s.v.p
Soil stack	s.s
Manhole	MH
Inspection chamber	i.c
Mechanical extractor fans to be ducted to outside air, capable of 15 ltrs/sec flow rate utility rooms; 30 ltrs/sec flow rate utility rooms; 6ltrs/sec flow rate w.c; with 15 mins overrun. Leave 10mm gap below door. Only install an e/f if appliance in the same room is a sealed unit	e/f
Self contained mains operated interlinked smoke alarms fixed to each floor level in main circulation areas.	sd
30 mins fire door complete with intumescent strips to frame	FD30
Structural Engineer	S.E
Timber stud wall, provide sound deadening quilt to bedrooms finished with 15mm plasterboard & skim	
Joist span direction	

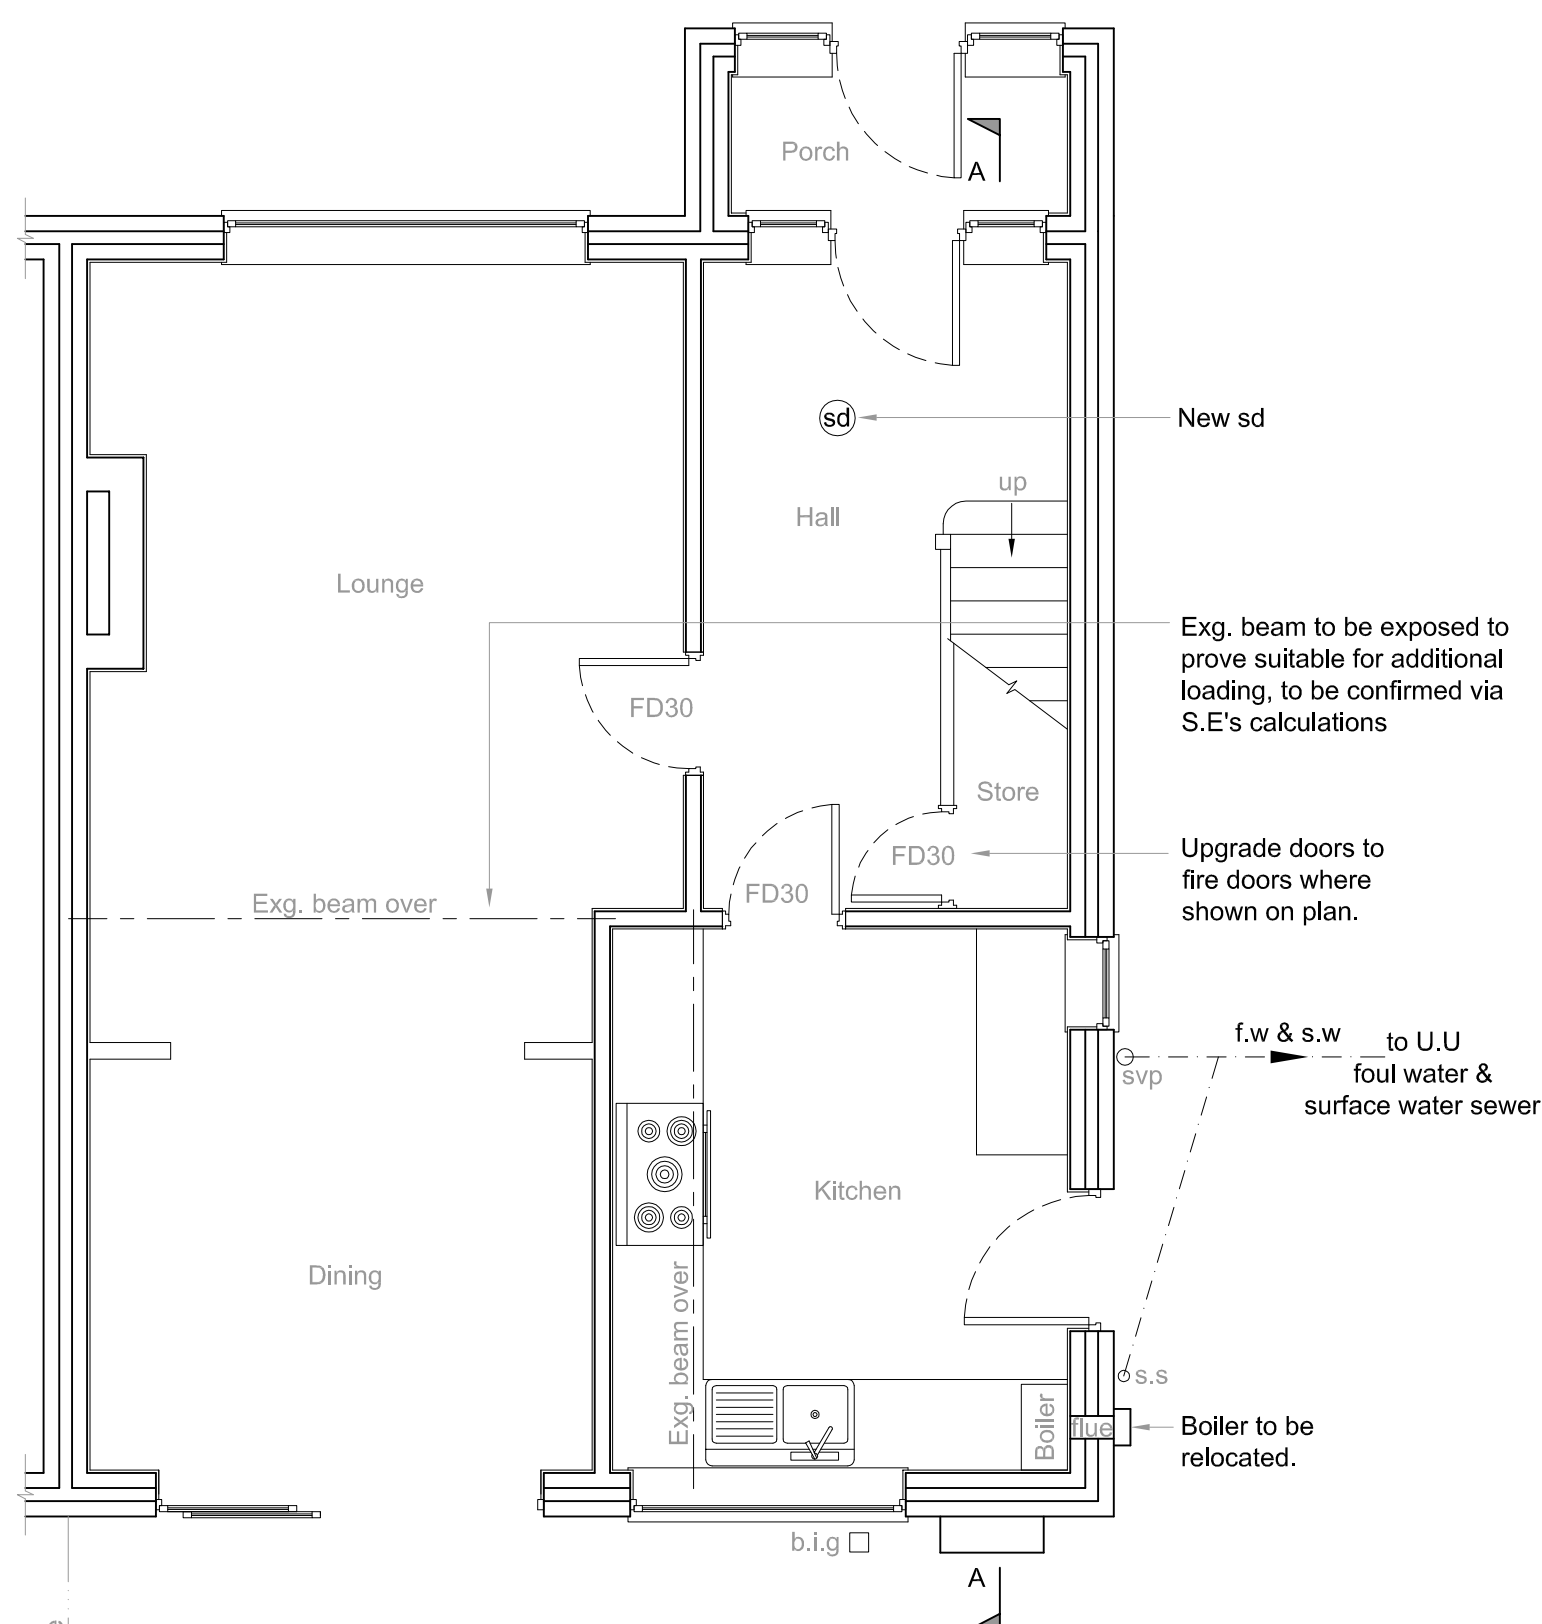


PROPOSED GROUND FLOOR PLAN
scale 1:50

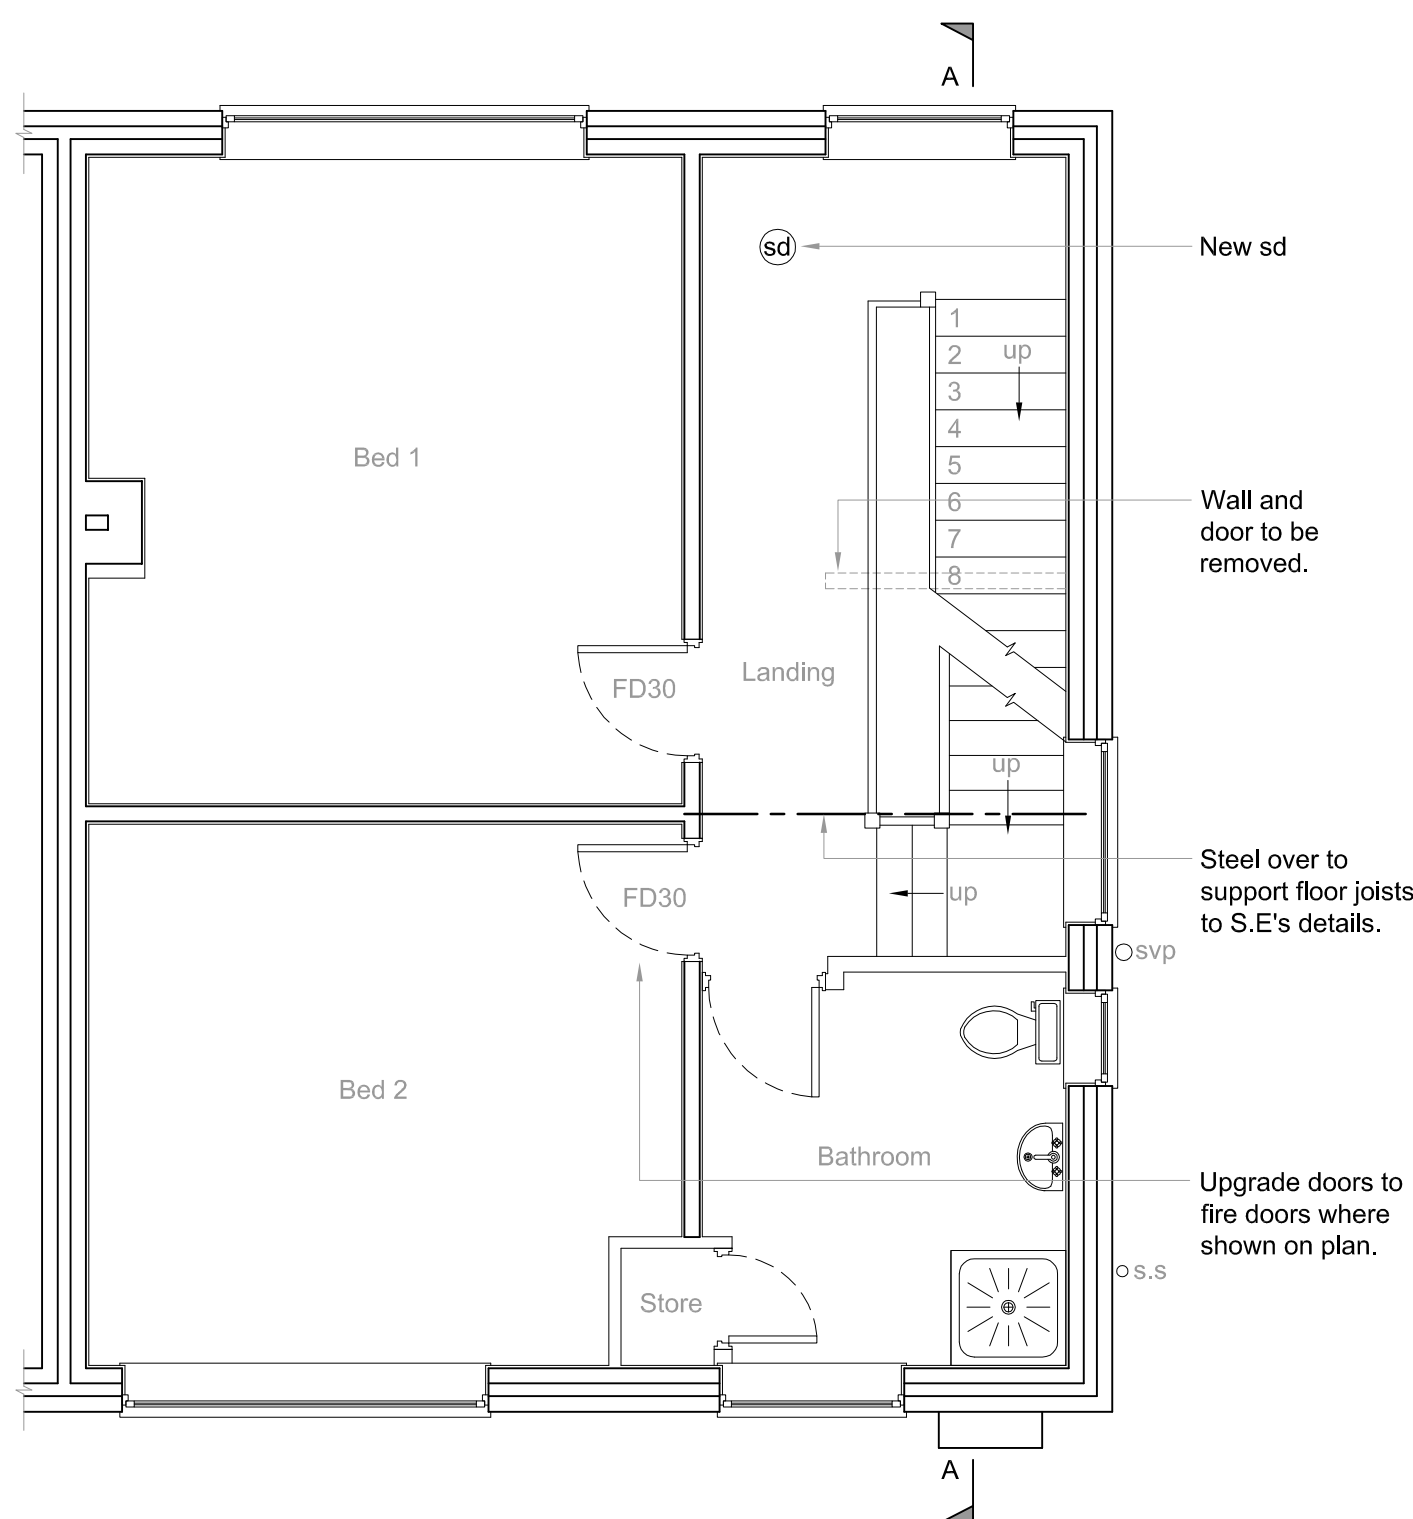

PROPOSED FIRST FLOOR PLAN
scale 1:50

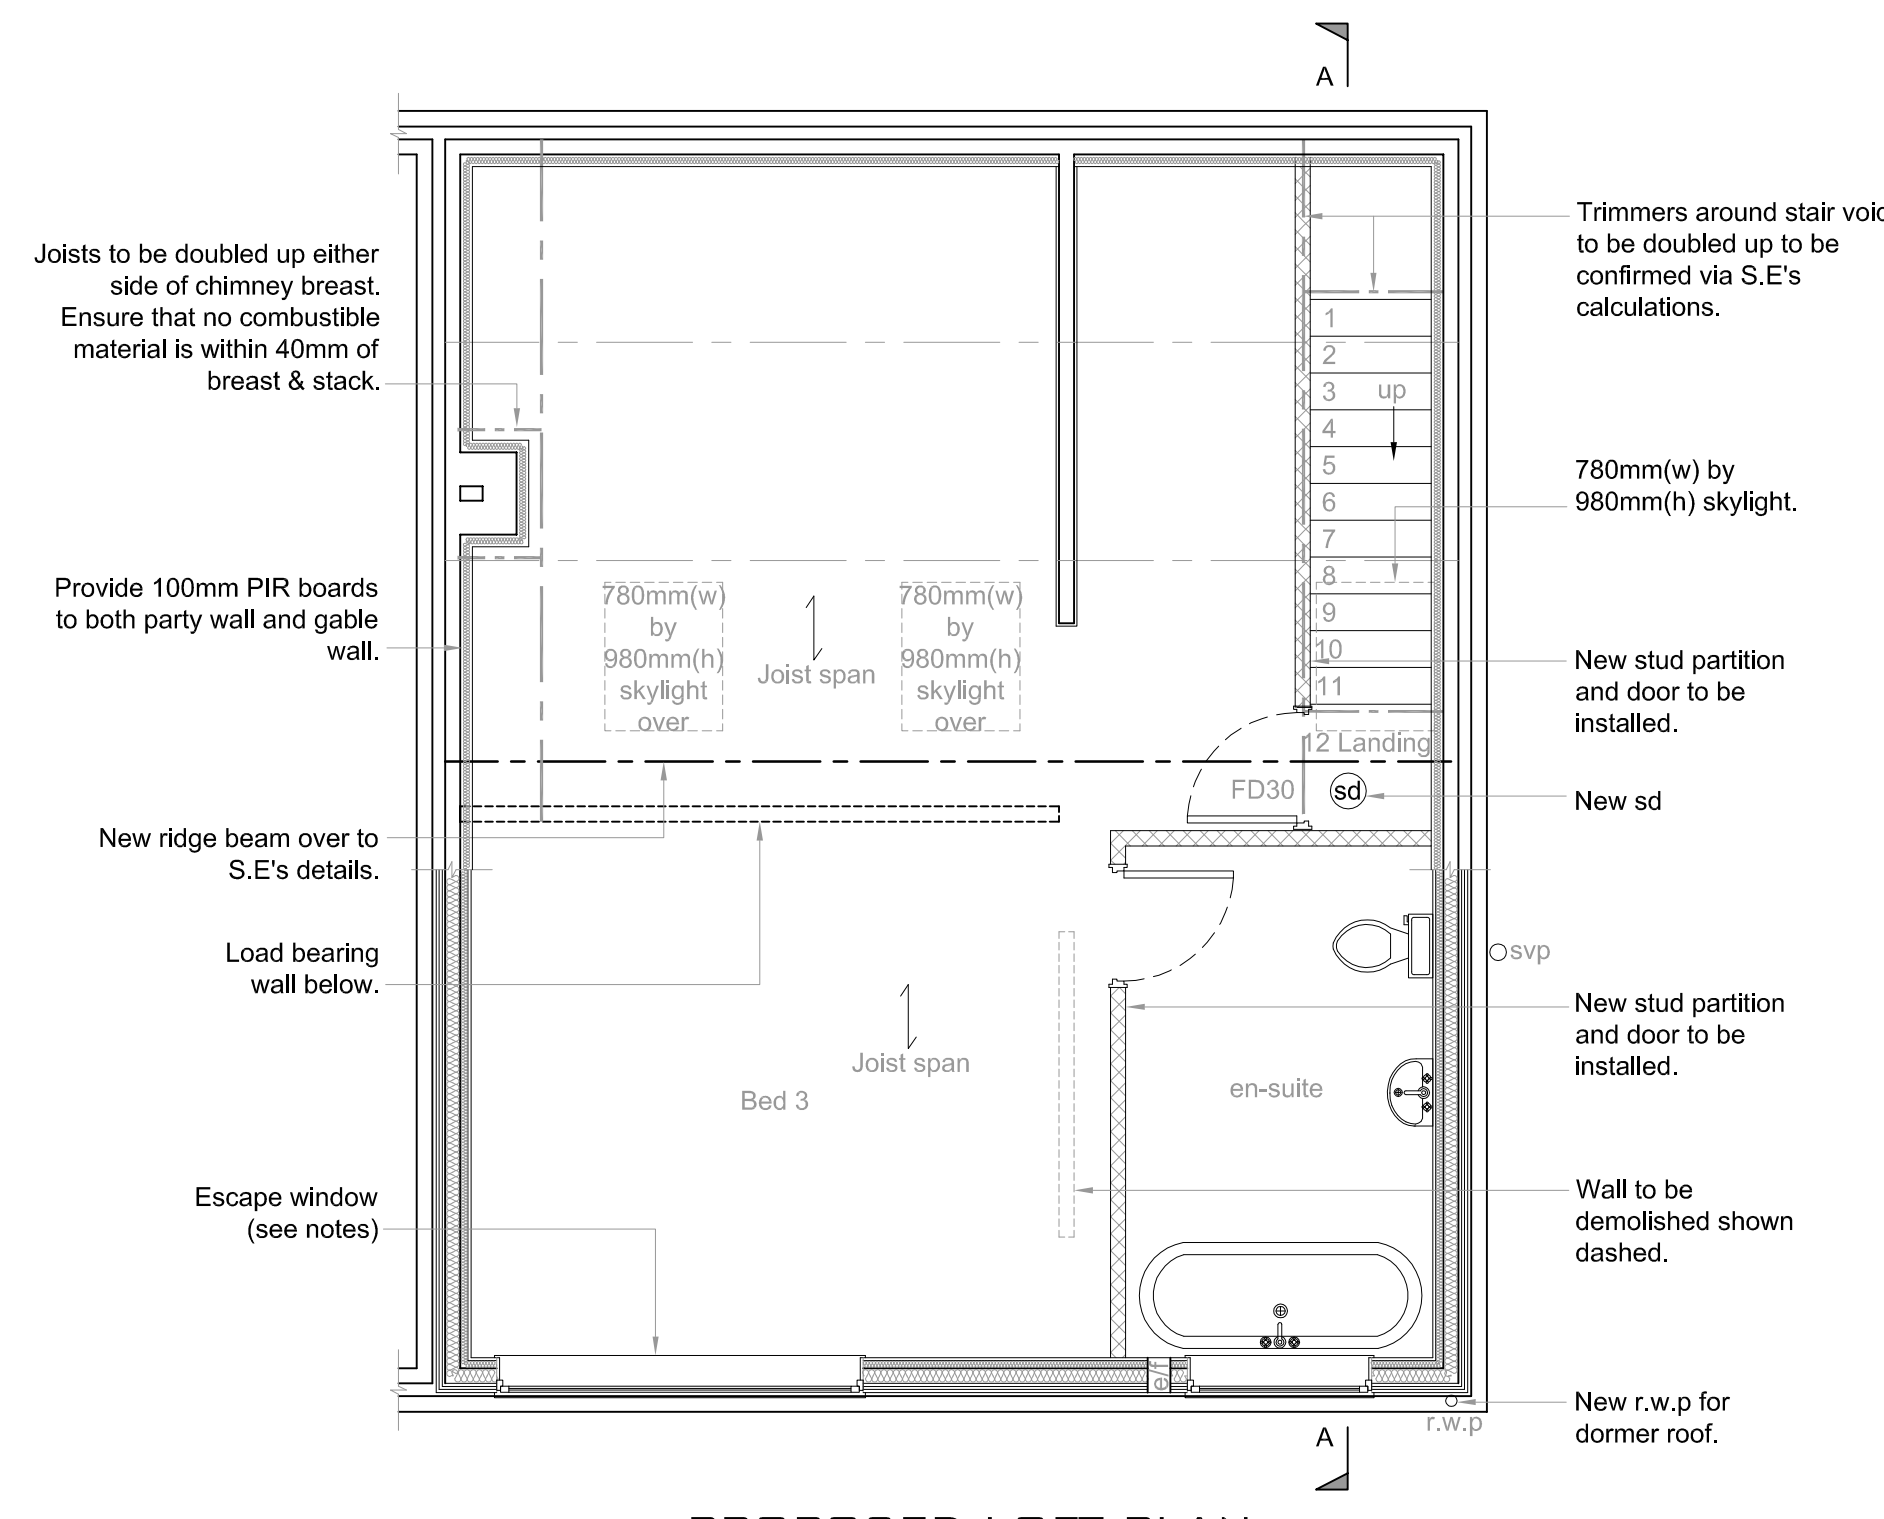

PROPOSED LOFT PLAN
scale 1:50

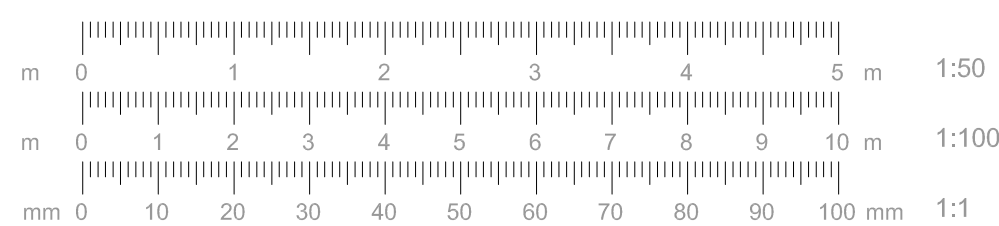

DWG No.
L26 OTE/65/02

TITLE
FLOOR PLANS

PROJECT
Proposed Development to
65 Hollies Road
Halewood
L26 0TE

CLIENT
Mr. B. Kirk

DATE
09/12/2025

SCALE AT A1
AS SHOWN

PRO-TECH
ARCHITECTURE
WWW.PRO-TECHARCHITECTURE.CO.UK
CONTACT : LEE ROWLEY B.ENG.(HONS)
0151-420-7895
07967836028
20 ELSTREE COURT
WIDNES, WAB 3EP
INFO@PRO-TECHARCHITECTURE.CO.UK
FOLLOW US ON FACEBOOK @PROTECHARCHITECTURELTD