 





Reproduced by permission of Ordnance Survey on behalf of the Controller of His Majesty's Stationery Office All rights reserved. © Crown Copyright licence no. 0100031673

SITE AREA PLAN



SITE PHOTOGRAPH

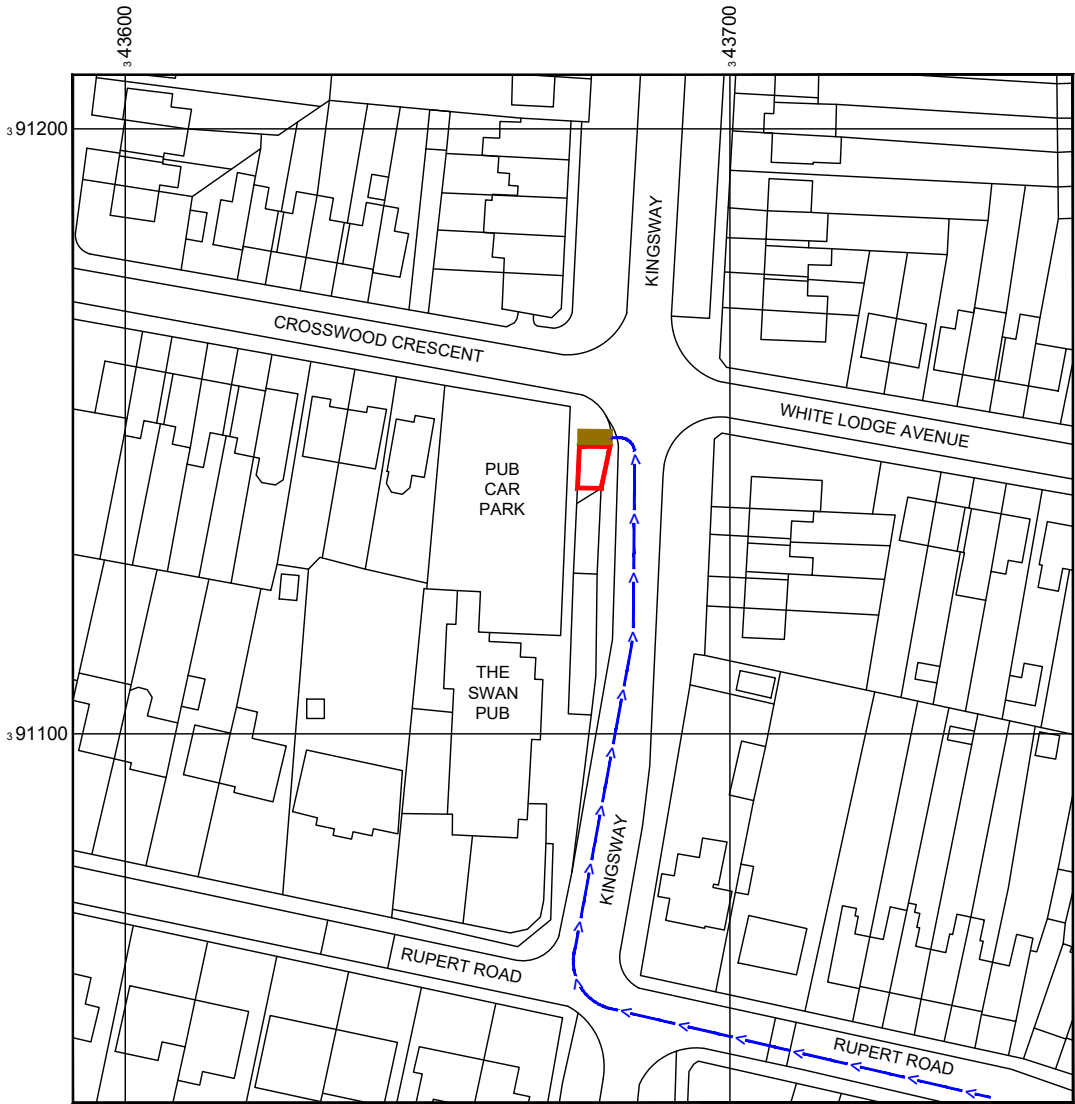


Reproduced by permission of Ordnance Survey on behalf of the Controller of His Majesty's Stationery Office All rights reserved. © Crown Copyright licence no. 0100031673

NGR E: 343678 N: 391144

W3W: belt.neck.bumpy

 SITE LOCATION PLAN



NOTES:

1. ALL DIMENSIONS IN MM UNLESS OTHERWISE NOTED.

Demise:



Access Route To Site:



Access Route:



Master:	Project:		Purpose of Issue:		Issue:
M003	NTQ		Planning		C
Date:	13.11.2025	Revision / Upgrade Description:			
Drawn:	J. Rossi	Drawings updated following Design review.			
Checked:	G. Jennings				
Approved:	G. Jennings				
Master:	Project:		Purpose of Issue:		Issue:
M002	NTQ		Planning		B
Date:	23.10.2025	Revision / Upgrade Description:			
Drawn:	J. Rossi	Tower type revised to HEL Phase 8. Armco barrier extended.			
Checked:	G. Jennings				
Approved:	G. Jennings				
Master:	Project:		Purpose of Issue:		Issue:
M001	NTQ		Planning		A
Date:	08/10/2025	Revision / Upgrade Description:			
Drawn:	J. Boote	First Issue			
Checked:	J. Stockdale				
Approved:	G. Jennings				



Hutchison 3G UK Limited
Green Park, 450 Longwater Avenue
Reading, RG30 3UR
Tel: 01628 765 000
Fax: 01628 765 001
H3G Base Station Information line:
0845 6043000
Available 8am-8pm Monday to Friday



Everything Everywhere
One Braham Street
London
E1 1SE
Tel: 020 7356 5000



Mobile Broadband Network Limited
Sixth Floor, Thames Tower, Station Road, Reading, RG1 1LX

Design Consultant & Principal Contractor:



WHP Telecoms
Castlevue House,
Calder Island Way, Wakefield
WF2 7AW

Tel: 01925 424 100
e-mail: info@whptelecoms.com

Site Name: KINGSWAY

Site ID: 30002812

Address: KINGSWAY,
HUYTON,
KNOWSLEY,
MERSEYSIDE,
L36 2PW


Title: 002 SITE LOCATION PLAN

Project: NTQ

Purpose of Issue: GENERAL ARRANGEMENT

EE Cell ID:	MBNL Cell ID:	H3G Cell ID:
39793	KSY125	N/A

File name: KSY125_39793_H3GNA_MBNL_NTQ_GAD_C_VISSPLAY

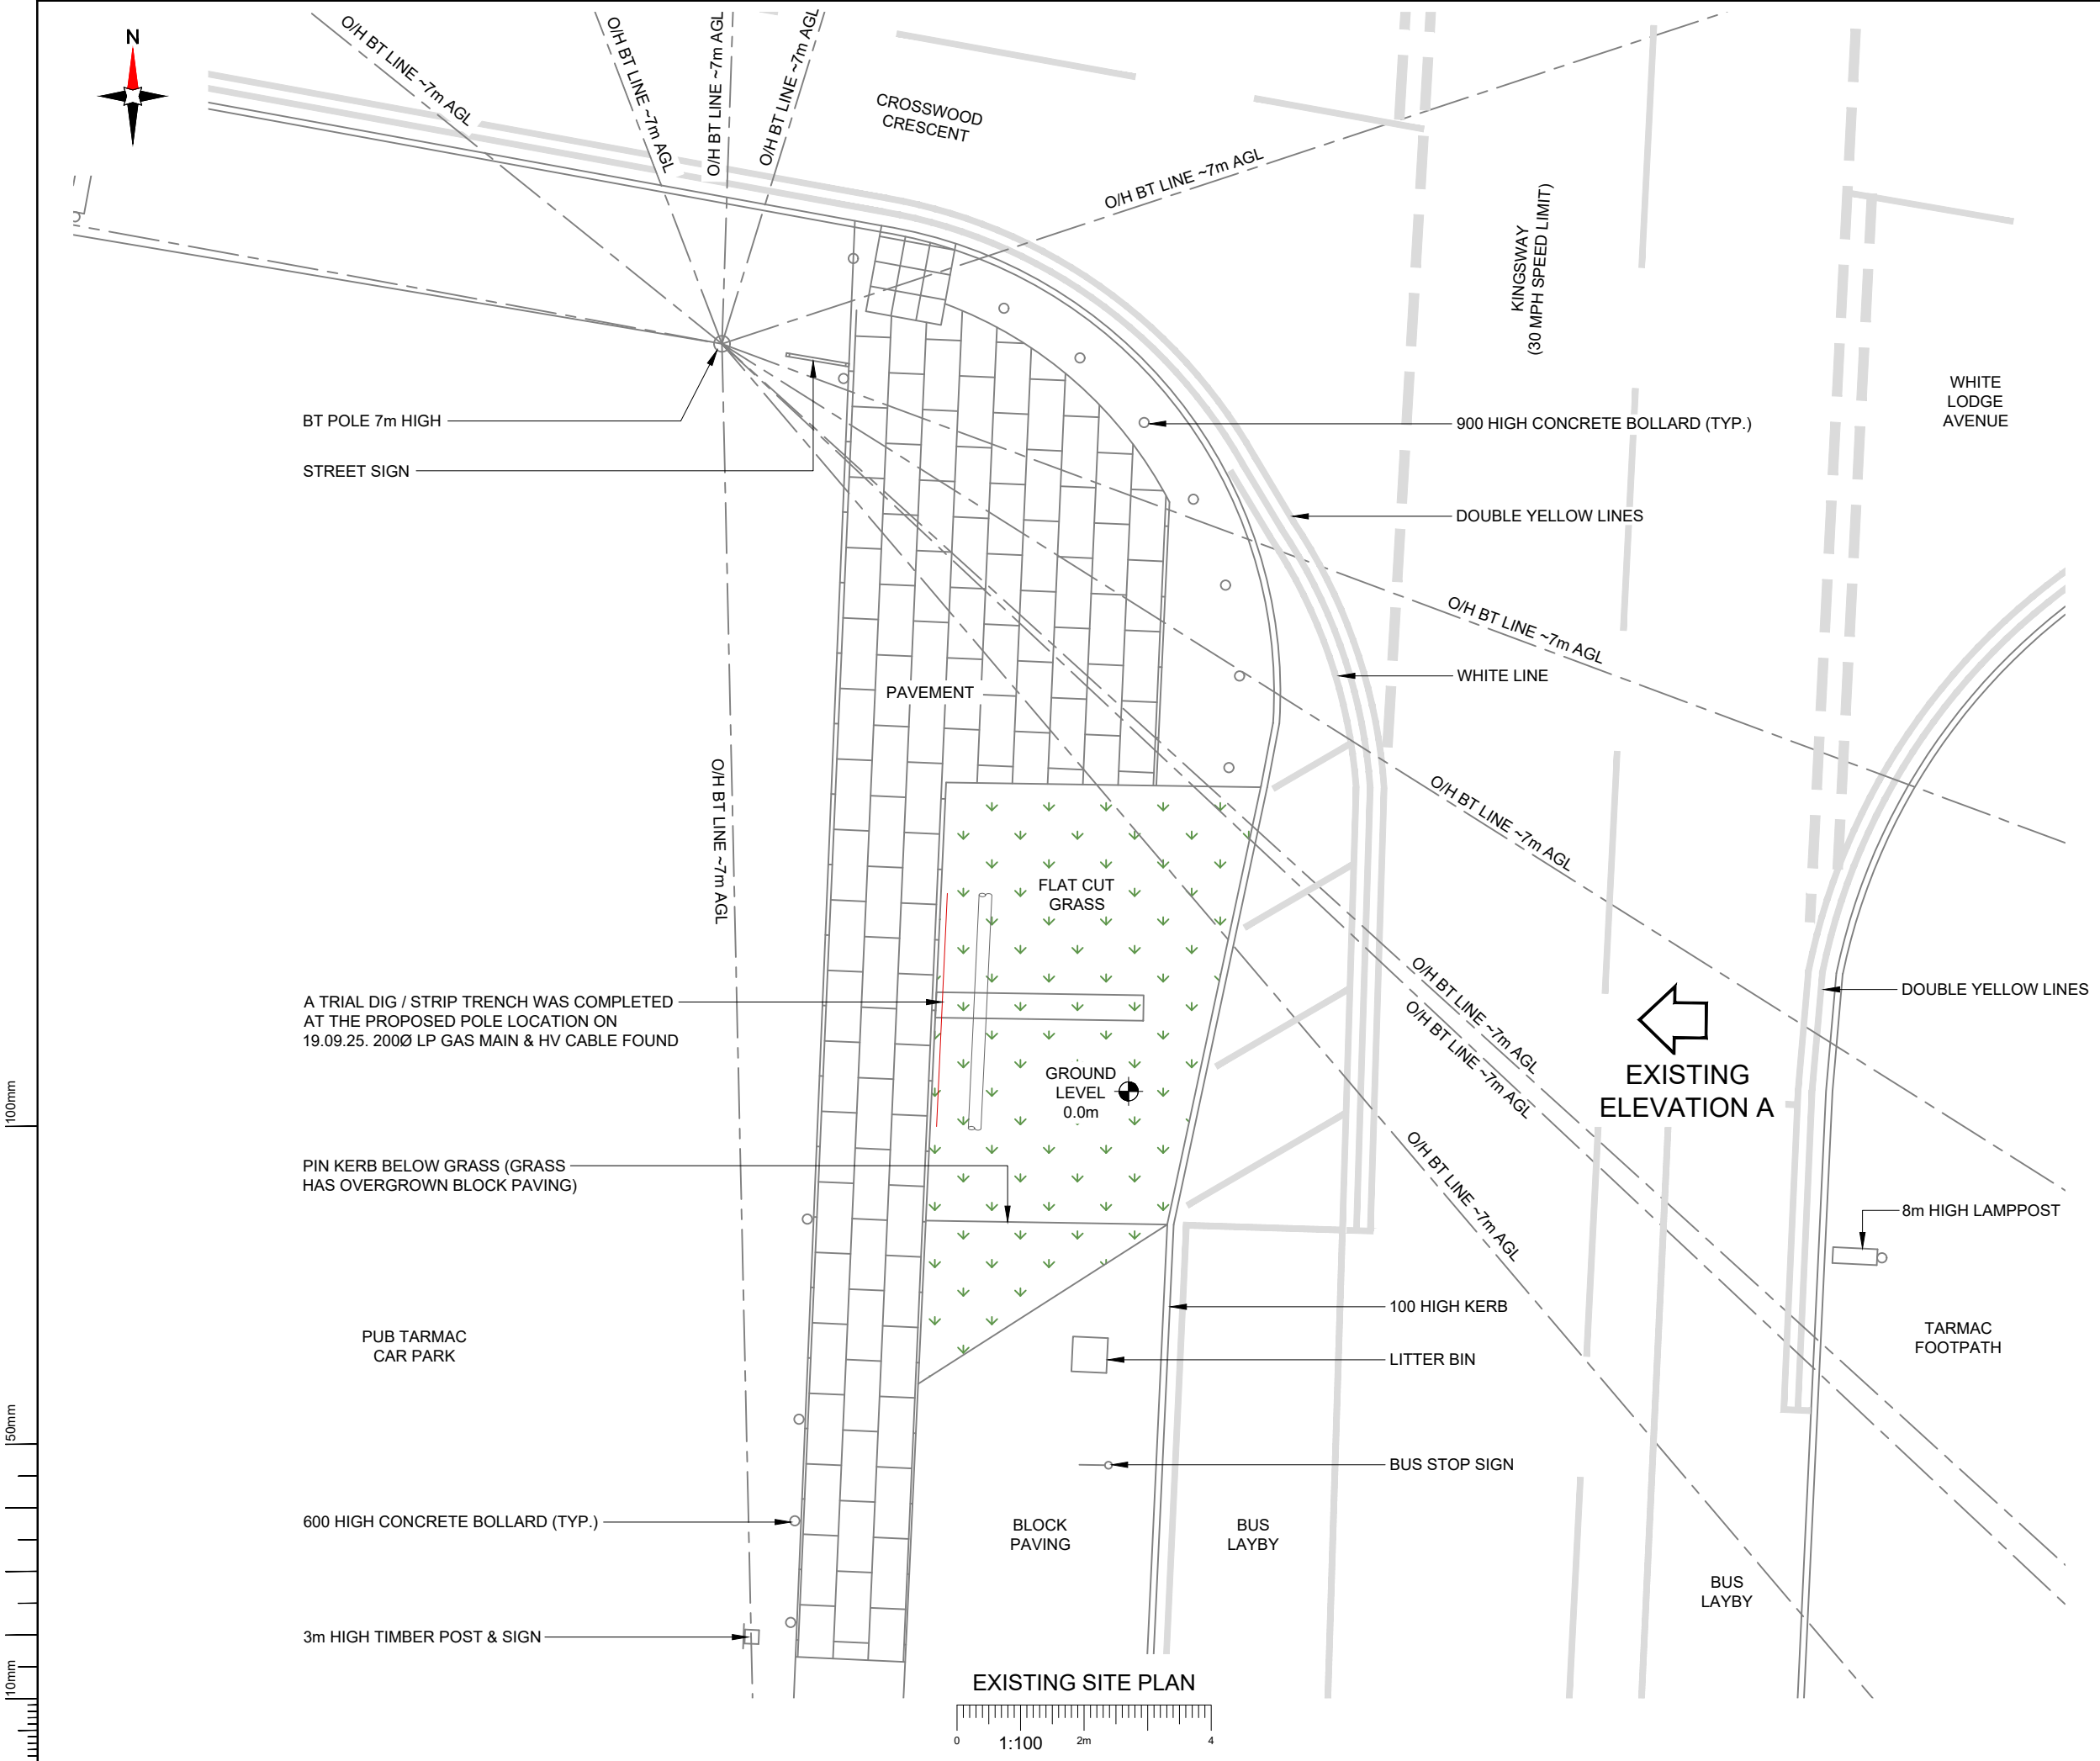

- NOTES:
- ALL DIMENSIONS IN MM UNLESS OTHERWISE NOTED.

Master:	M003	Project:	NTQ	Purpose of Issue:	Planning	Issue:	C
Date:	13.11.2025	Revision / Upgrade Description:					
Drawn:	J. Rossi	Drawings updated following Design review.					
Checked:	G. Jennings						
Approved:	G. Jennings						
Master:	M002	Project:	NTQ	Purpose of Issue:	Planning	Issue:	B
Date:	23.10.2025	Revision / Upgrade Description:					
Drawn:	J. Rossi	Tower type revised to HEL Phase 8. Armco barrier extended.					
Checked:	G. Jennings						
Approved:	G. Jennings						
Master:	M001	Project:	NTQ	Purpose of Issue:	Planning	Issue:	A
Date:	08/10/2025	Revision / Upgrade Description:					
Drawn:	J. Boote	First Issue					
Checked:	J. Stockdale						
Approved:	G. Jennings						



Hutchison 3G UK Limited
Green Park, 450 Longwater Avenue
Reading, RG30 3UR
Tel: 01628 765 000
Fax: 01628 765 001

H3G Base Station Information line:
0845 6043000
Available 8am-8pm Monday to Friday



Everything Everywhere
One Braham Street
London
E1 6EE

Tel: 020 7356 5000



Mobile Broadband Network Limited
Sixth Floor, Thames Tower, Station Road, Reading, RG1 1LX

Design Consultant & Principal Contractor:



WHP Telecoms
Castlevue House,
Calder Island Way, Wakefield
WF2 7AW

Tel: 01925 424 100
e-mail: info@whptelecoms.com

Site Name: **KINGSWAY**

Site ID: **30002812**

Address: **KINGSWAY,
HUYTON,
KNOWSLEY,
MERSEYSIDE,
L36 2PW**


Title: **100 EXISTING SITE PLAN**

Project: **NTQ**

Purpose of Issue: **GENERAL ARRANGEMENT**

EE Cell ID:	MBNL Cell ID:	H3G Cell ID:
39793	KSY125	N/A

File name: **KSY125_39793_H3GNA_MBNL_NTQ_GAD_C_VISSPLAY**

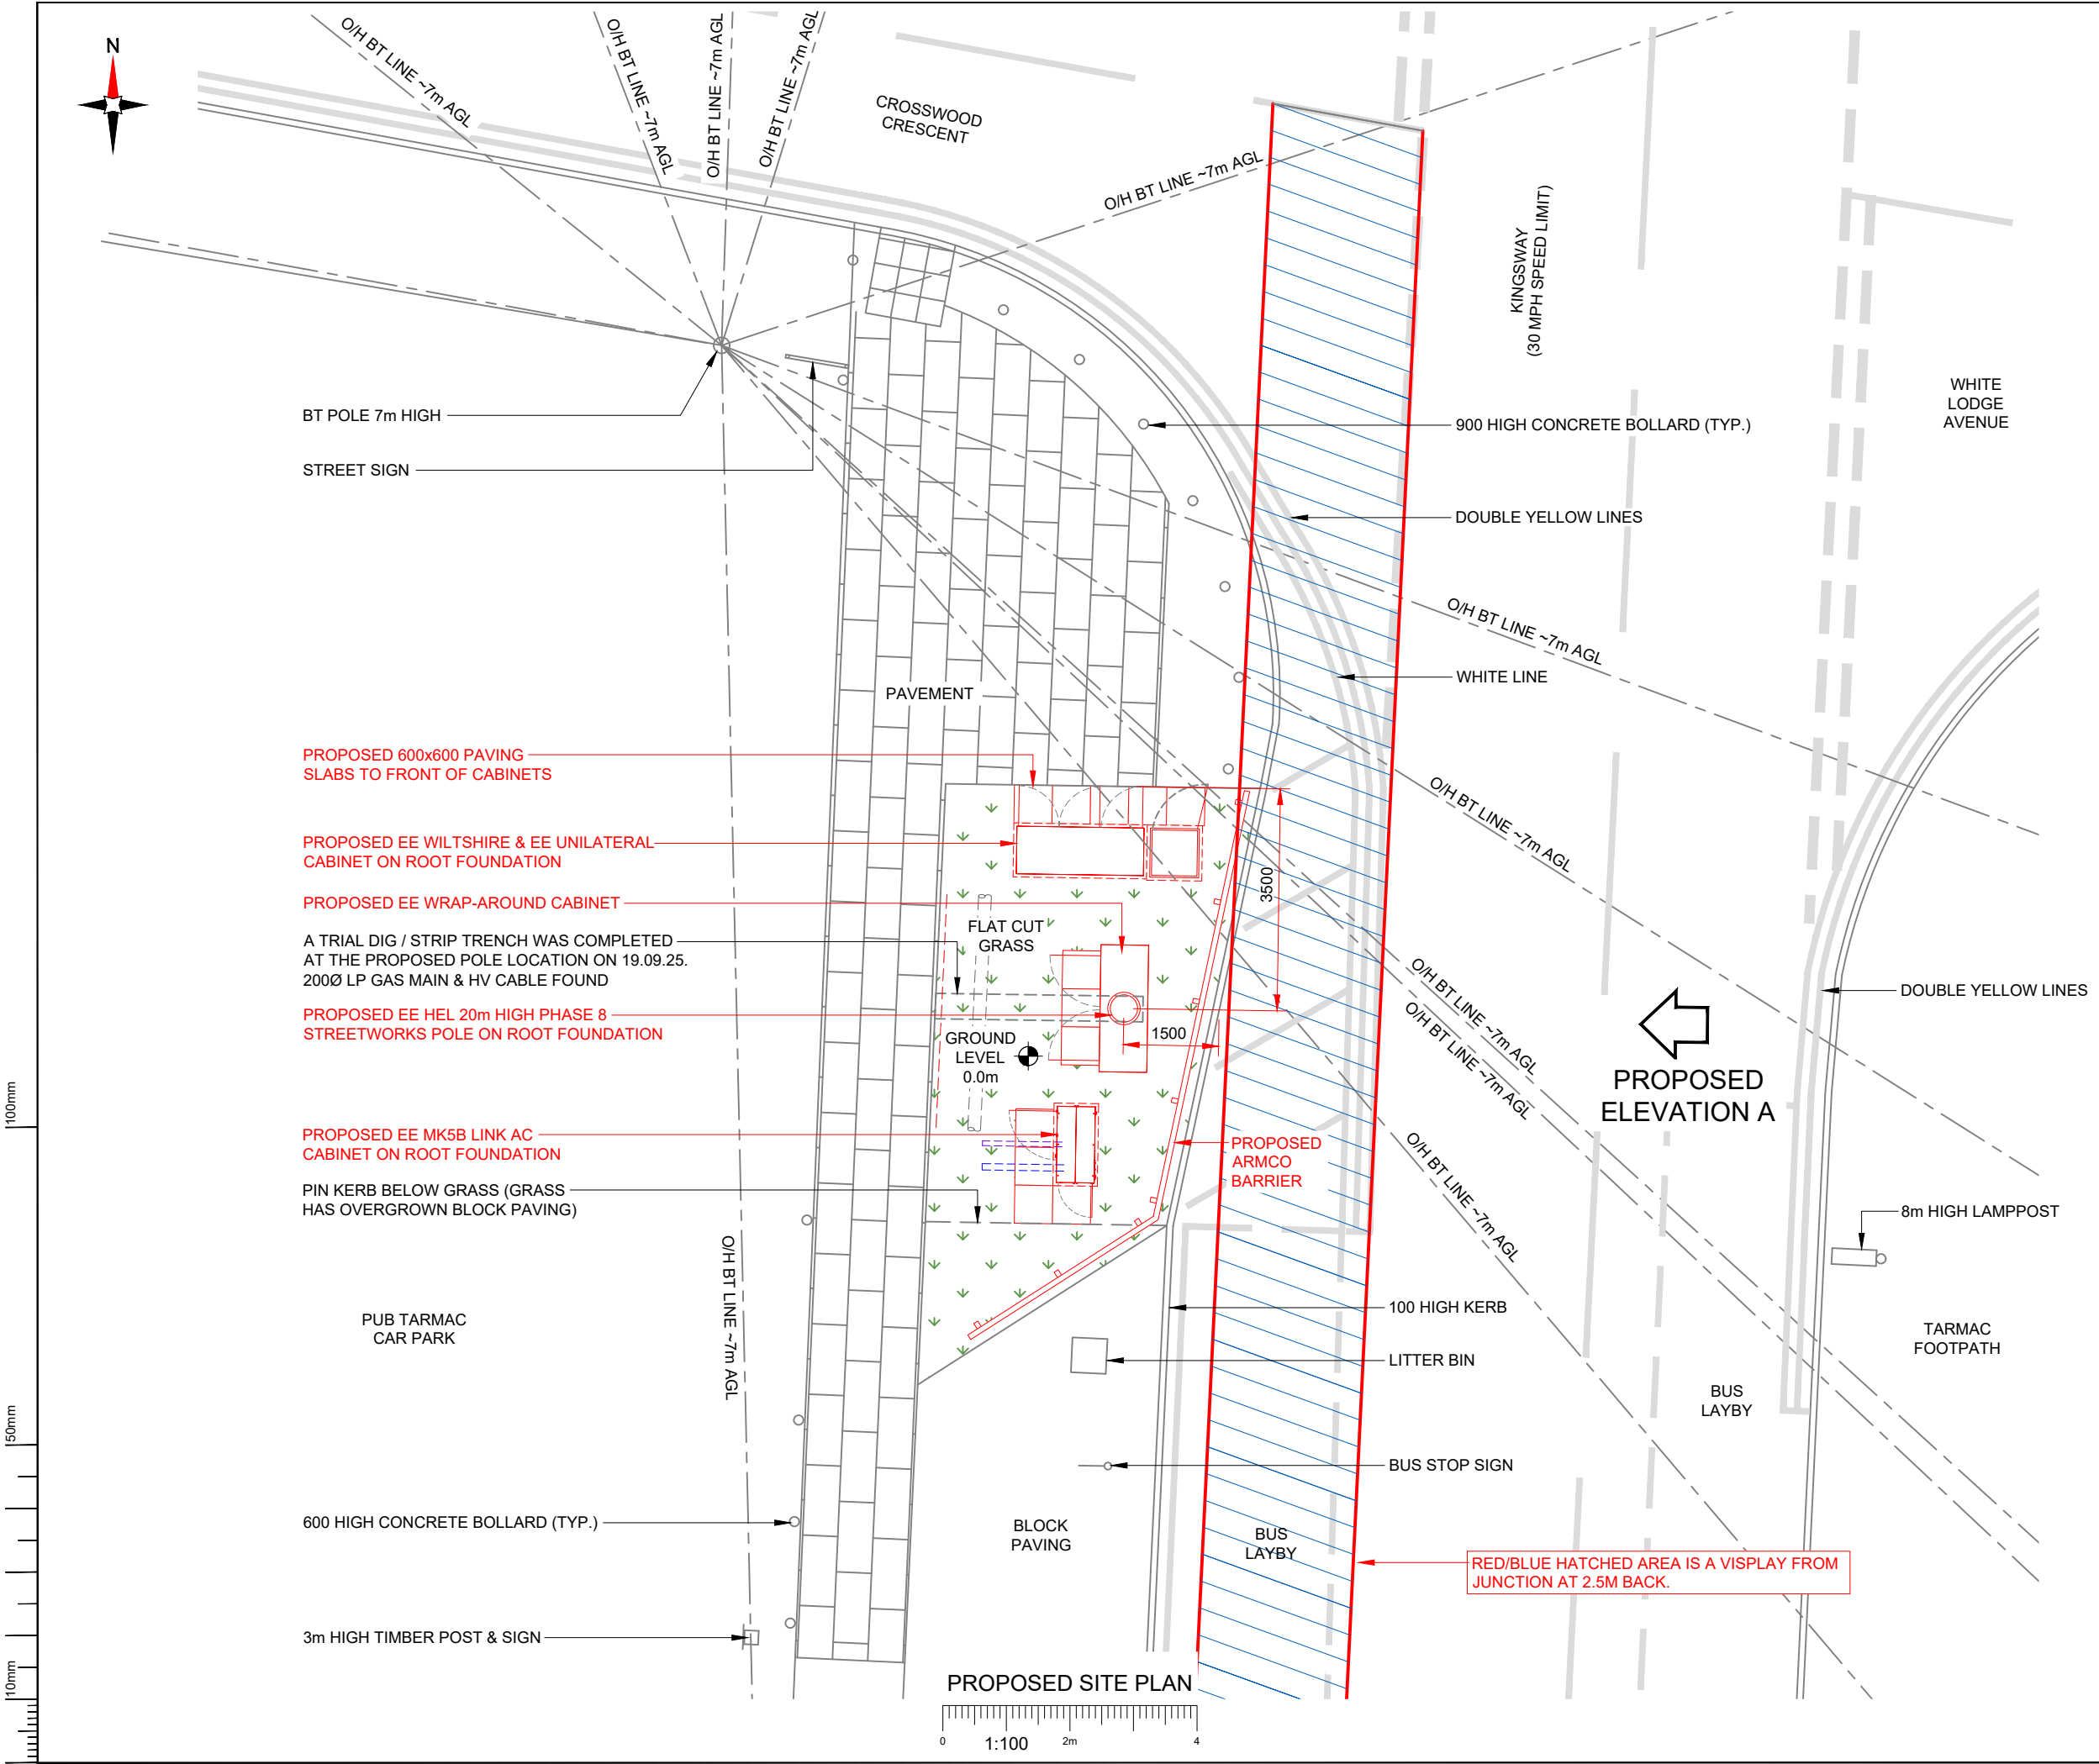

NOTES:

1. ALL DIMENSIONS IN MM UNLESS OTHERWISE NOTED.

Master:	M003	Project:	NTQ	Purpose of Issue:	Planning	Issue:	C
Date:	13.11.2025	Revision / Upgrade Description:					
Drawn:	J. Rossi	Drawings updated following Design review.					
Checked:	G. Jennings						
Approved:	G. Jennings						

Master:	M002	Project:	NTQ	Purpose of Issue:	Planning	Issue:	B
Date:	23.10.2025	Revision / Upgrade Description:					
Drawn:	J. Rossi	Tower type revised to HEL Phase 8. Armco barrier extended.					
Checked:	G. Jennings						
Approved:	G. Jennings						

Master:	M001	Project:	NTQ	Purpose of Issue:	Planning	Issue:	A
Date:	08/10/2025	Revision / Upgrade Description:					
Drawn:	J. Boote	First Issue					
Checked:	J. Stockdale						
Approved:	G. Jennings						

Hutchison 3G UK Limited
Green Park, 450 Longwater Avenue
Reading, RG30 3UR
Tel: 01628 765 000
Fax: 01628 765 001
H3G Base Station Information line:
0845 6043000
Available 8am-8pm Monday to Friday

Everything Everywhere
One Braham Street
London
E1 6EE
Tel: 020 7356 5000

MBNL Mobile Broadband Network Limited
Sixth Floor, Thames Tower, Station Road, Reading, RG1 1LX

Design Consultant & Principal Contractor:

WHP Telecoms
Castlevue House,
Calder Island Way, Wakefield
WF2 7AW
Tel: 01925 424 100
e-mail: info@whptelecoms.com

Site Name:

KINGSWAY

Site ID:

30002812

Address:

**KINGSWAY,
HUYTON,
KNOWSLEY,
MERSEYSIDE,
L36 2PW**

Title:

150 PROPOSED SITE PLAN

Project:

NTQ

Purpose of Issue:

GENERAL ARRANGEMENT

EE Cell ID:	MBNL Cell ID:	H3G Cell ID:
39793	KSY125	N/A


File name:

KSY125_39793_H3GNA_MBNL_NTQ_GAD_C_VISSPLAY


100mm

50mm

10mm

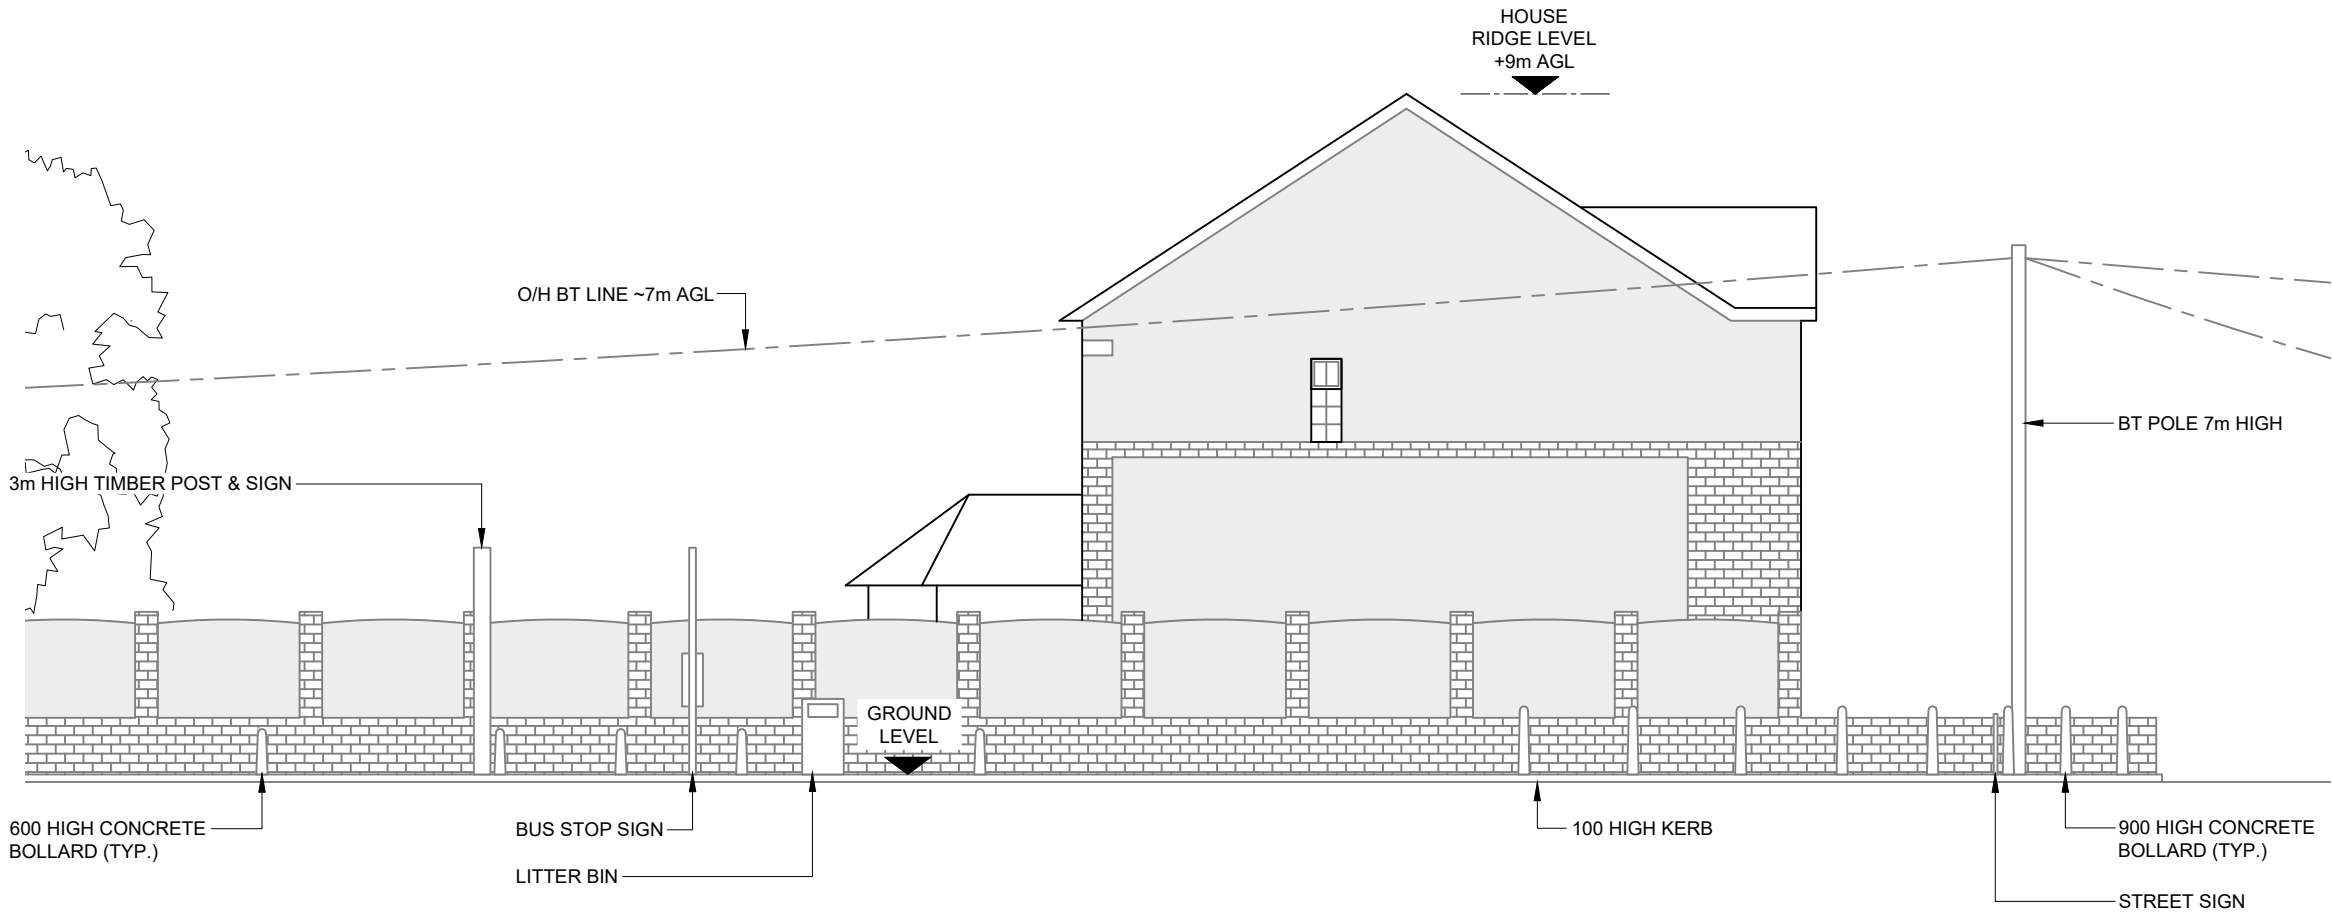

EXISTING SITE ELEVATION A

 

- NOTES:
- ALL DIMENSIONS IN MM UNLESS OTHERWISE NOTED.

Master:	M003	Project:	NTQ	Purpose of Issue:	Planning	Issue:	C
Date:	13.11.2025	Revision / Upgrade Description:					
Drawn:	J. Rossi	Drawings updated following Design review.					
Checked:	G. Jennings						
Approved:	G. Jennings						
Master:	M002	Project:	NTQ	Purpose of Issue:	Planning	Issue:	B
Date:	23.10.2025	Revision / Upgrade Description:					
Drawn:	J. Rossi	Tower type revised to HEL Phase 8. Armco barrier extended.					
Checked:	G. Jennings						
Approved:	G. Jennings						
Master:	M001	Project:	NTQ	Purpose of Issue:	Planning	Issue:	A
Date:	08/10/2025	Revision / Upgrade Description:					
Drawn:	J. Boote	First Issue					
Checked:	J. Stockdale						
Approved:	G. Jennings						



Hutchison 3G UK Limited
Green Park, 450 Longwater Avenue
Reading, RG30 3UR
Tel: 01628 765 000
Fax: 01628 765 001
H3G Base Station Information line:
0845 6043000
Available 8am-8pm Monday to Friday



Everything Everywhere
One Braham Street
London
E1 8EE
Tel: 020 7358 5000



Mobile Broadband Network Limited
Sixth Floor, Thames Tower, Station Road, Reading, RG1 1LX

Design Consultant & Principal Contractor:



WHP Telecoms
Castleview House,
Calder Island Way, Wakefield
WF2 7AW

Tel: 01925 424 100
e-mail: info@whptelecoms.com

Site Name: **KINGSWAY**

Site ID: **30002812**

Address: **KINGSWAY,
HUYTON,
KNOWSLEY,
MERSEYSIDE,
L36 2PW**


Title: **200 EXISTING SITE ELEVATION**

Project: **NTQ**

Purpose of Issue: **GENERAL ARRANGEMENT**

EE Cell ID:	MBNL Cell ID:	H3G Cell ID:
39793	KSY125	N/A

File name: **KSY125_39793_H3GNA_MBNL_NTQ_GAD_C_VISSPLAY**

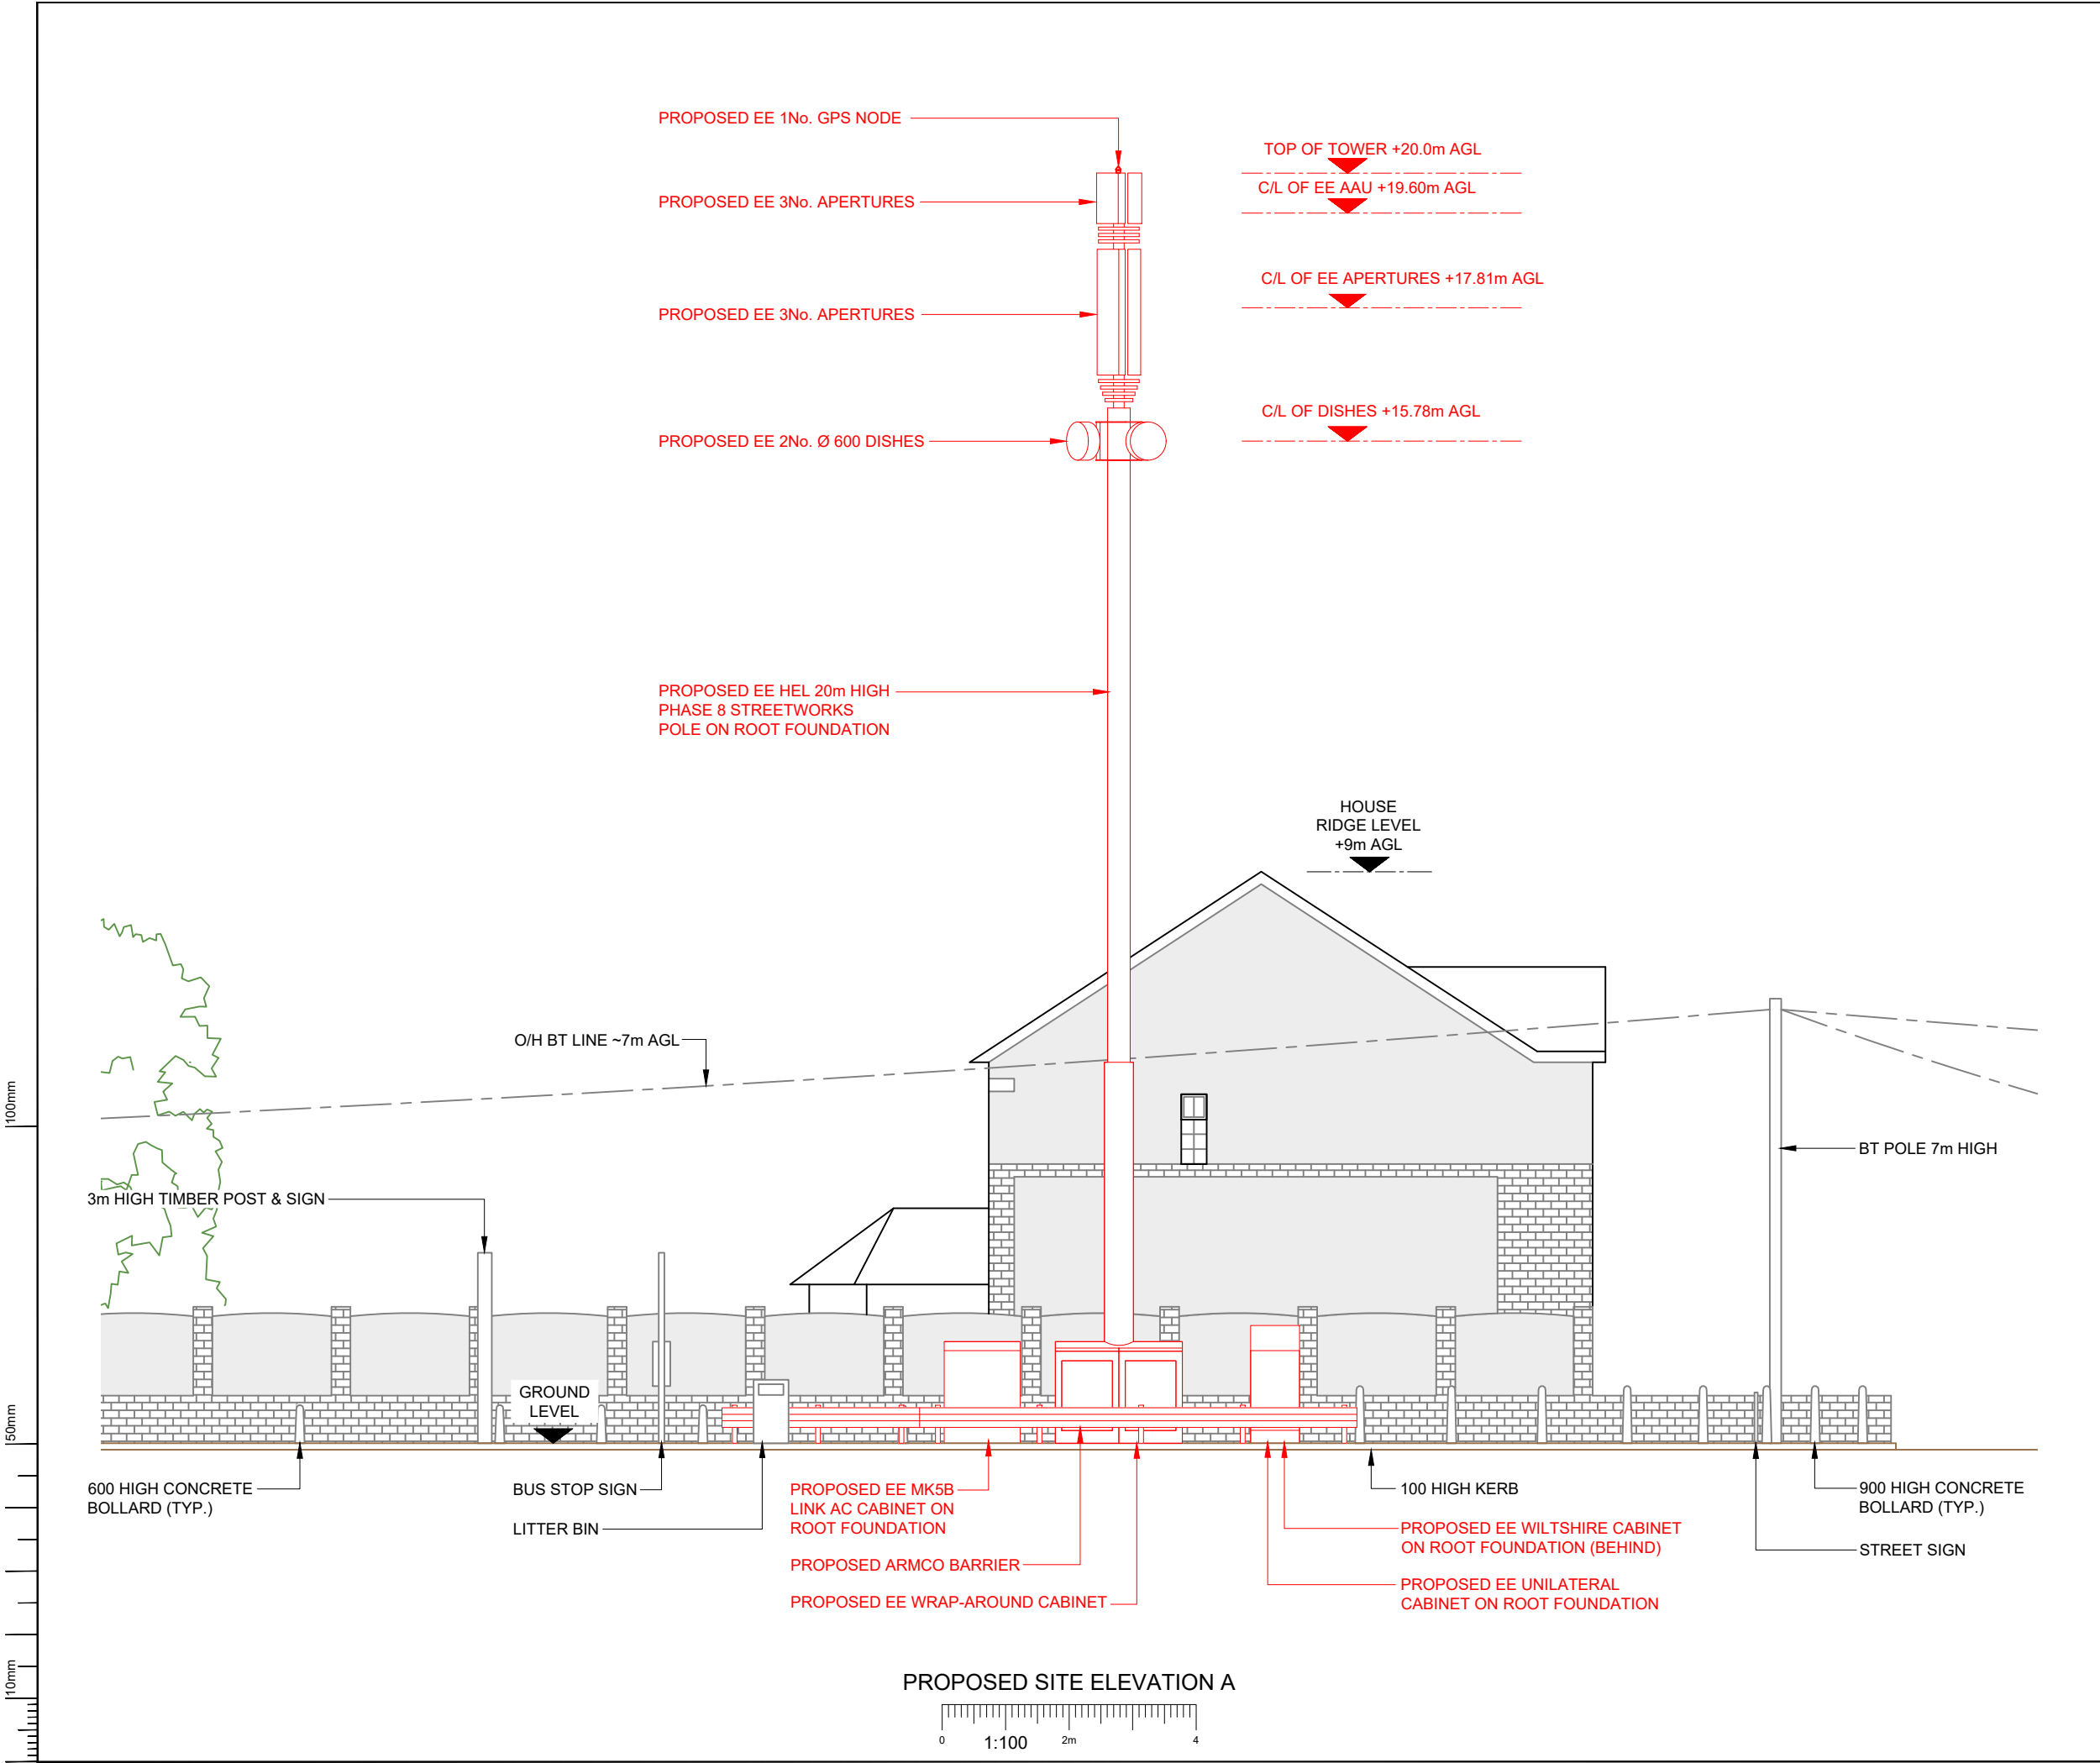

- NOTES:
- ALL DIMENSIONS IN MM UNLESS OTHERWISE NOTED.

Master: M003	Project: NTQ		Purpose of Issue: Planning		Issue: C
Date: 13.11.2025	Revision / Upgrade Description: Drawings updated following Design review.				
Drawn: J. Rossi					
Checked: G. Jennings					
Approved: G. Jennings					
Master: M002	Project: NTQ		Purpose of Issue: Planning		Issue: B
Date: 23.10.2025	Revision / Upgrade Description: Tower type revised to HEL Phase 8. Armco barrier extended.				
Drawn: J. Rossi					
Checked: G. Jennings					
Approved: G. Jennings					
Master: M001	Project: NTQ		Purpose of Issue: Planning		Issue: A
Date: 08/10/2025	Revision / Upgrade Description: First Issue				
Drawn: J. Boote					
Checked: J. Stockdale					
Approved: G. Jennings					



Hutchison 3G UK Limited
Green Park, 450 Longwater Avenue
Reading, RG30 3UR
Tel: 01628 765 000
Fax: 01628 765 001
H3G Base Station Information line:
0845 6043000
Available 8am-8pm Monday to Friday



Everything Everywhere
One Braham Street
London
E1 6EE
Tel: 020 7358 5000



Mobile Broadband Network Limited
Sixth Floor, Thames Tower, Station Road, Reading, RG1 1LX

Design Consultant & Principal Contractor:

WHP Telecoms
Castleview House,
Calder Island Way, Wakefield
WF2 7AW

Tel: 01925 424 100
e-mail: info@whptelecoms.com

Site Name:	KINGSWAY	
Site ID:	30002812	
Address:	KINGSWAY, HUYTON, KNOWSLEY, MERSEYSIDE, L36 2PW	
Title:	250 PROPOSED SITE ELEVATION	
Project:	NTQ	
Purpose of Issue:	GENERAL ARRANGEMENT	
EE Cell ID:	39793	MBNL Cell ID:
		KSY125
		H3G Cell ID:
		N/A
File name:	KSY125_39793_H3GNA_MBNL_NTQ_GAD_C_VISSPLAY	