


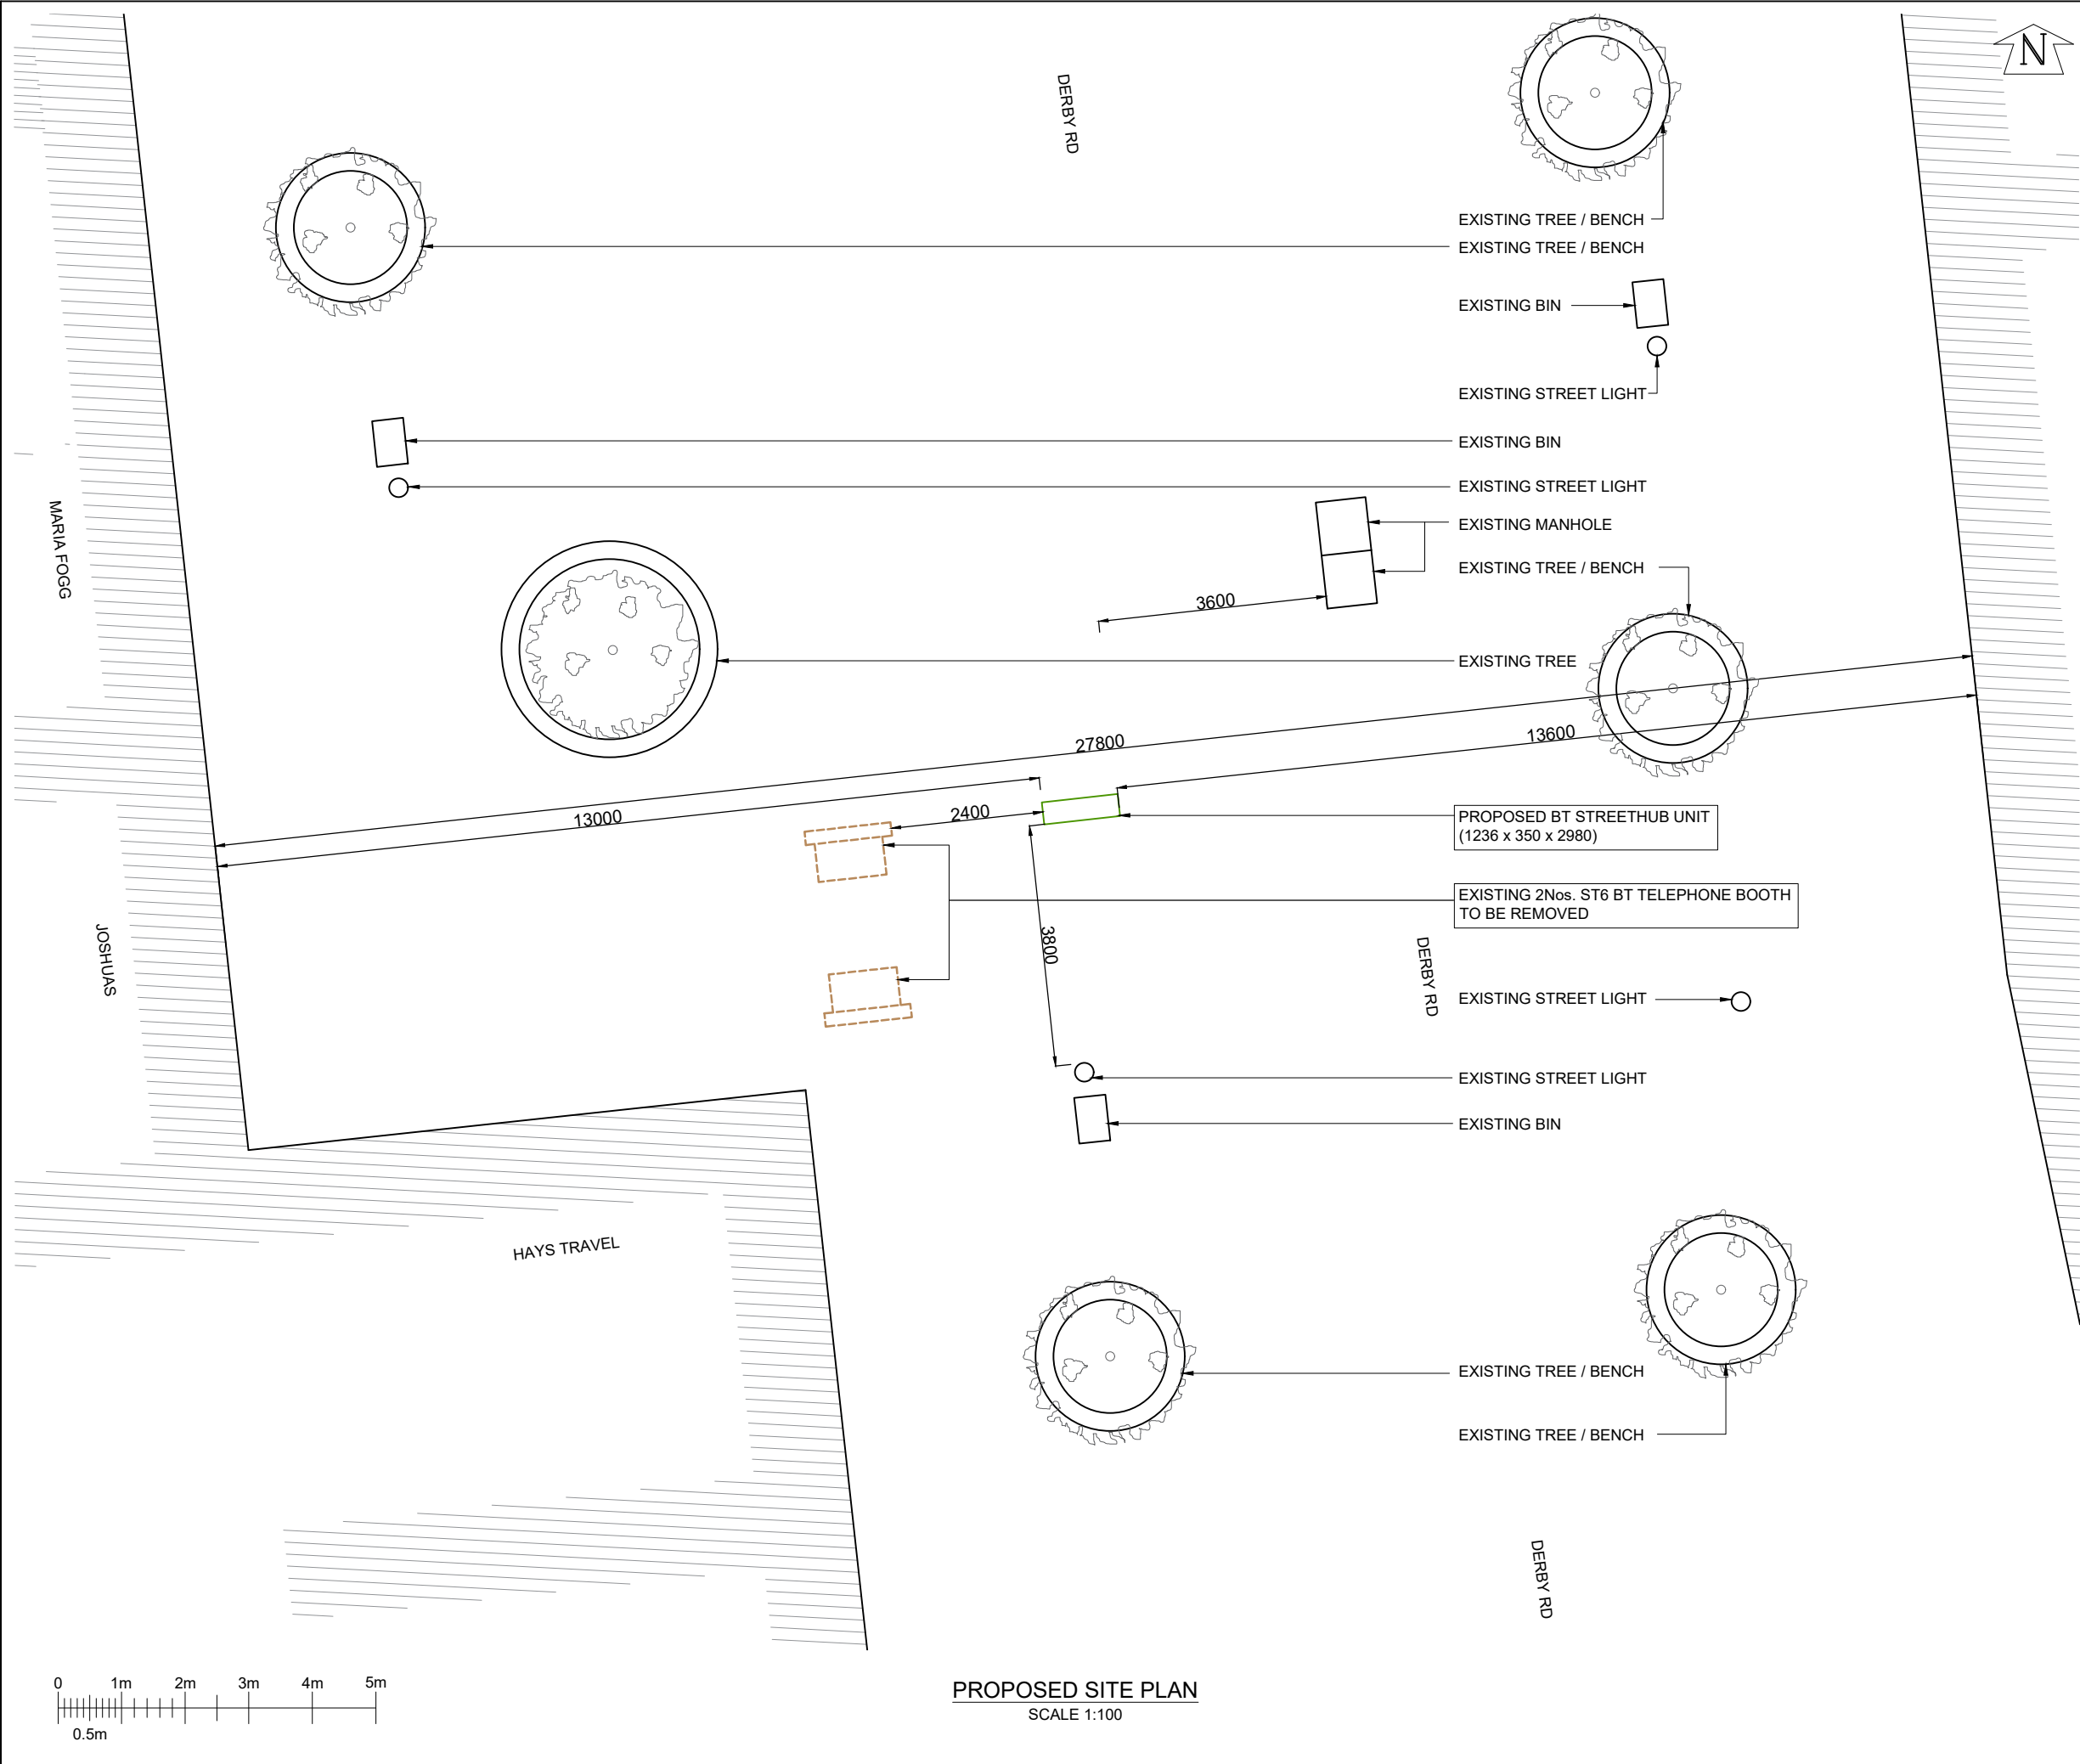

GENERAL NOTES

Use written dimensions only, do not scale from drawing. Use latest revision of all referenced information.

A	21.02.22	New BT Streethub Structure	MD	JE
Rev	Date	Description	Drawn	Chkd

MONO CONSULTANTS LIMITED
70-76 Steam Packet House
Cross Street
Manchester, M2 4JG
t. 44 (0)161 839 8839
www.monoconsultants.com

Drg Status
PLANNING

Cell No. & Name

KNOW002

Site Name & Address

O/S NO 34 DERBY ROAD HUYTON
LIVERPOOL L36 9UJ

Drawing Title

PROPOSED SITE PLAN

Scale	1:100	Date	21.02.2022
Drawn By	MD	Checked By	JE
Drawing Number 002		Revision A	