


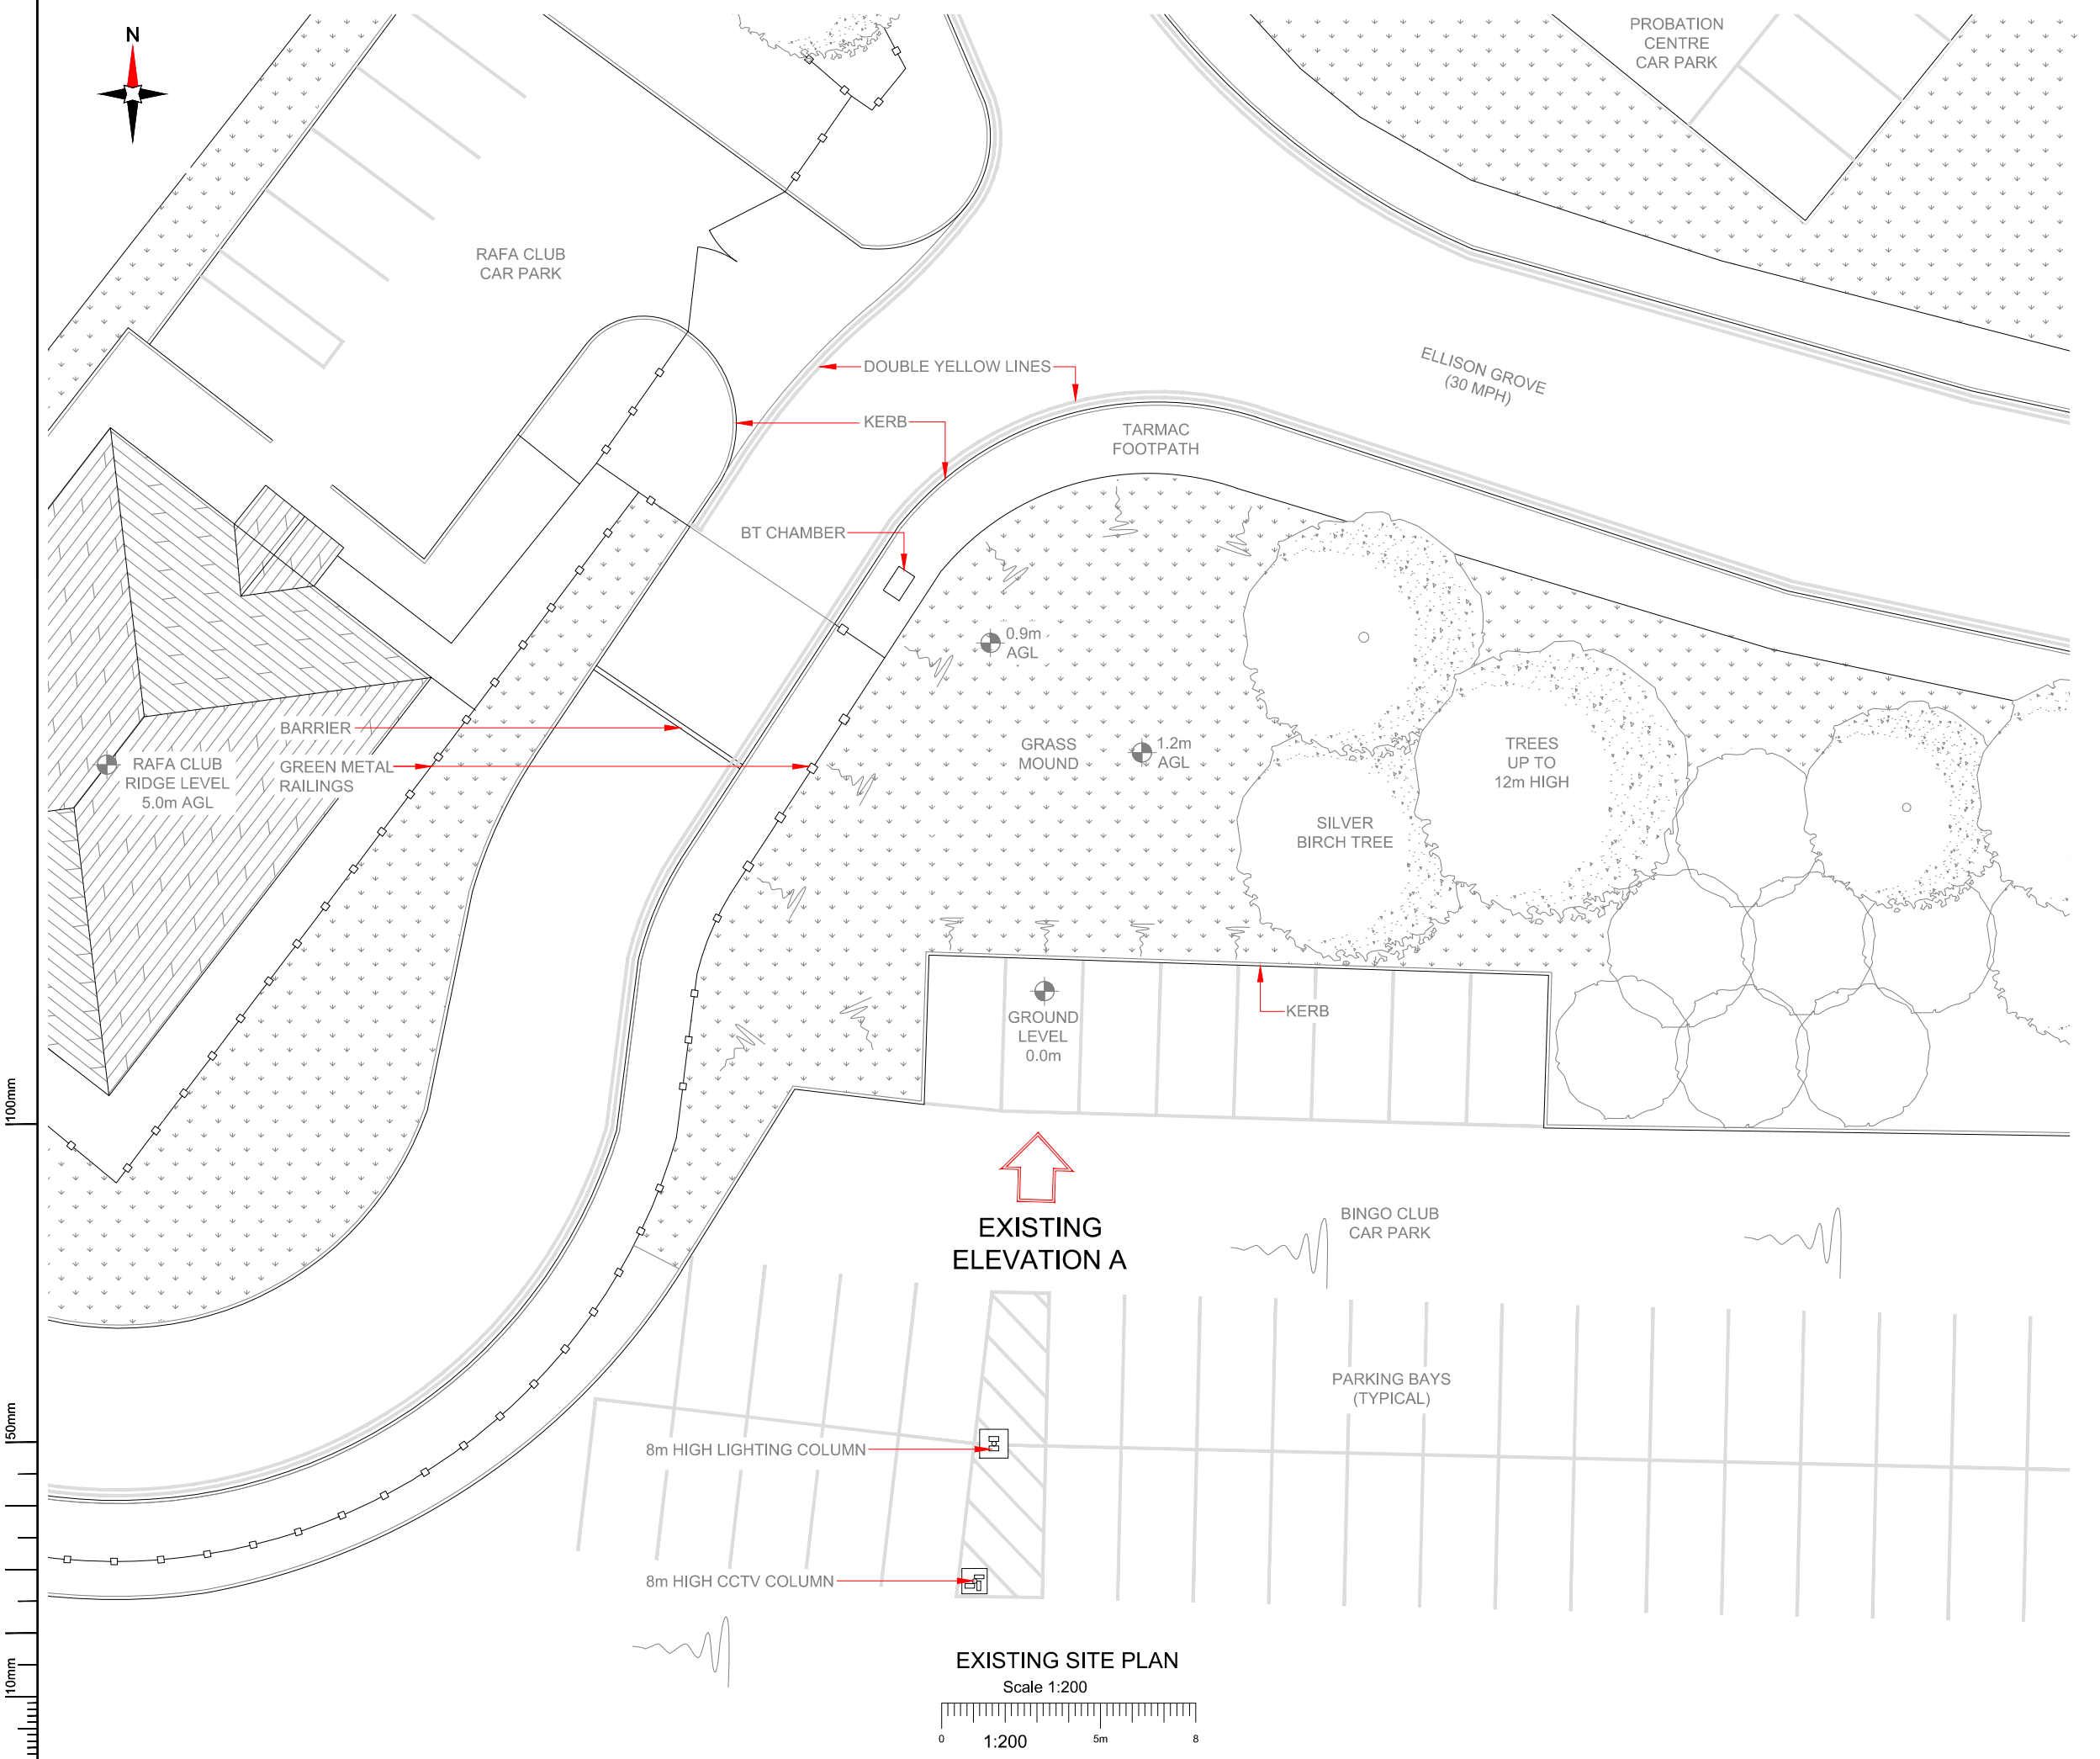

NOTES:

1. ALL DIMENSIONS IN MM UNLESS OTHERWISE NOTED.

Master:	MBNL / EE / H3G	Project:	NTQ	Purpose of Issue:	Planning	Issue:	B
Date:	30/04/21	Revision / Upgrade Description:					
Drawn:	R. PERKINS	Tower updated					
Checked:	A. FANNING						
Approved:	P. CONVERY						
Master:	MBNL / EE / H3G	Project:	NTQ	Purpose of Issue:	Planning	Issue:	A
Date:	01/04/21	Revision / Upgrade Description:					
Drawn:	J. BOOTE	First Issue					
Checked:	J. STOCKDALE						
Approved:	J. STOCKDALE						



Hutchison 3G UK Limited
Star House, 20 Grenfell Road
Mordenhead, SLS 1EH
Tel: 01628 765 000
Fax: 01628 765 001



Hatfield Business Park
Hatfield
Hertfordshire
AL10 9BW
Tel: 01707 315000
Fax: 01707 319001



Mobile Broadband Network Limited
Sixth Floor, Thames Tower, Station Road, Reading, RG1 1LX

Design Consultant & Principal Contractor:

 **WHP Telecoms**
Unit 1 Maple Park,
Low Fields Avenue, Leeds
LS12 6HH
Tel: 01133023550
e-mail: info@whptelecoms.com

Site Name:	CLUB 3000 BINGO HUYTON		
Site ID:	1632340		
Address:	CLUB 3000 BINGO HUYTON, POPLAR BANK, HUYTON, LIVERPOOL, MERSEYSIDE, L36 9US		
Title:	100 EXISTING SITE PLAN		
Project:	NTQ		
Purpose of Issue:	GENERAL ARRANGEMENT		
EE Cell ID:	92410	MBNL Cell ID:	KSY083
3UK Cell ID:	-		
Master Drawing No:	1632340_KSY083_92410_M002		Issue: B