


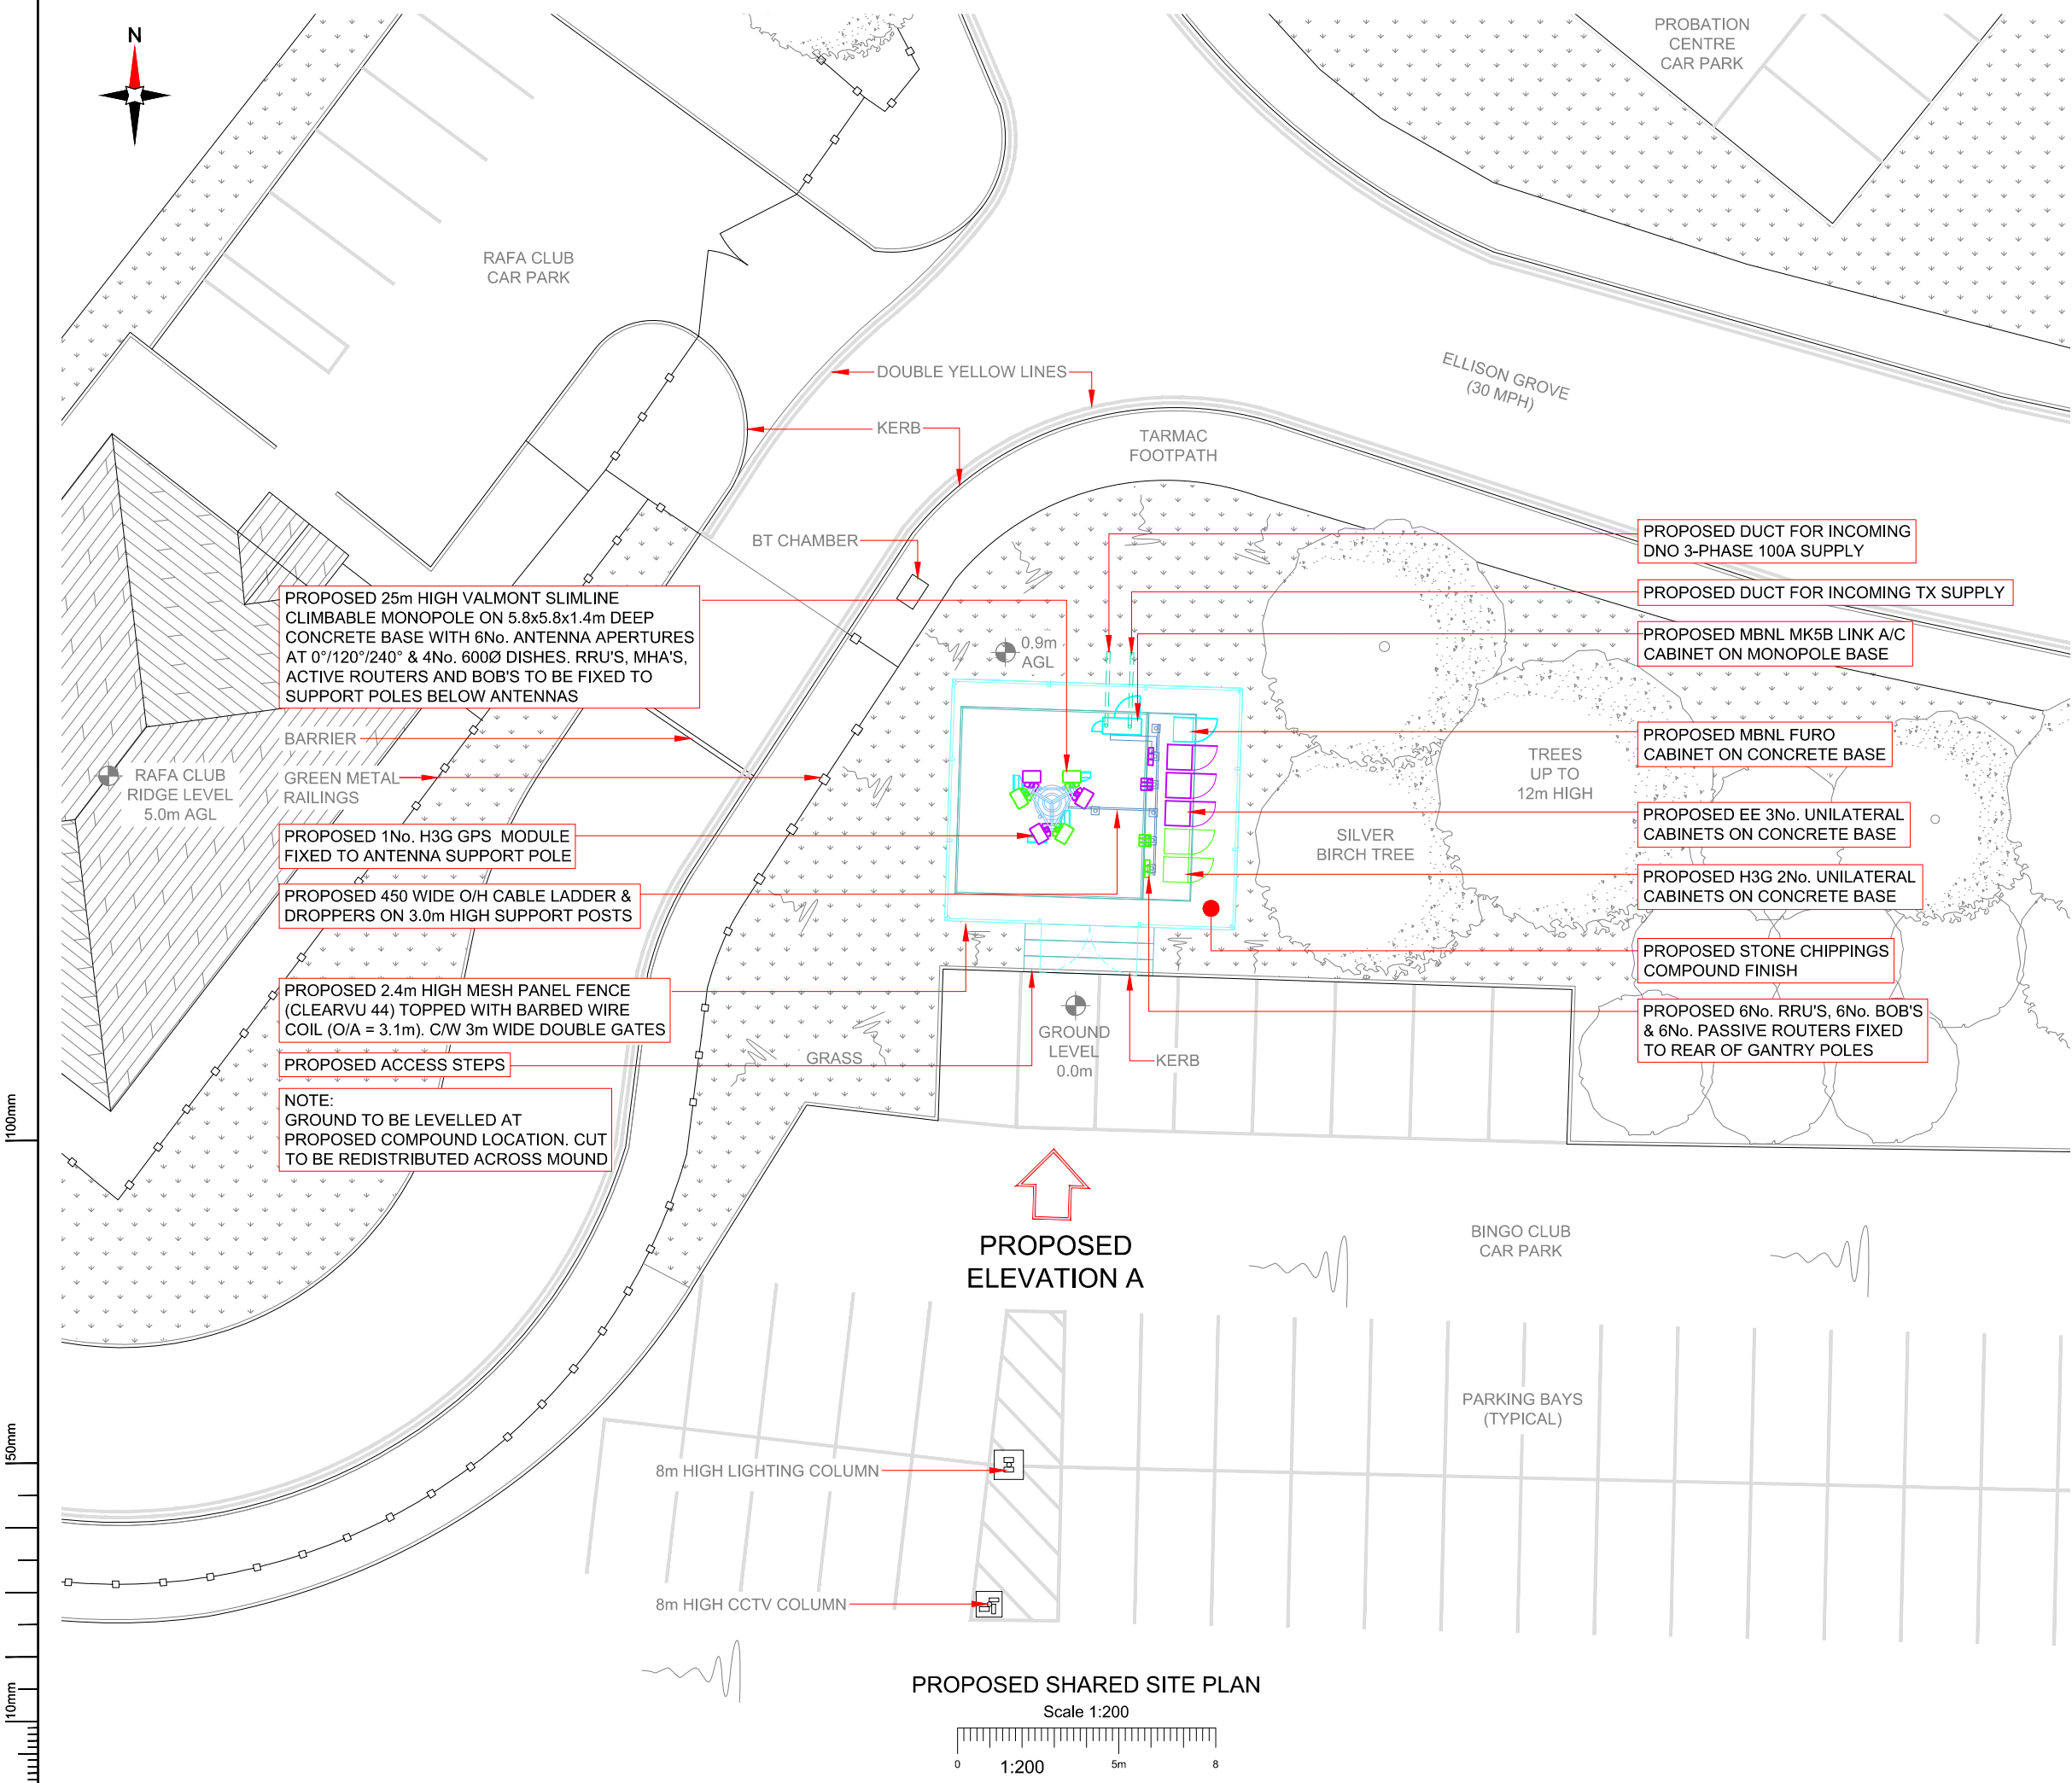

- NOTES:
- ALL DIMENSIONS IN MM UNLESS OTHERWISE NOTED.

SHARED CONFIGURATION SITE

RF CONFIG

H3b

Master:	MBNL / EE / H3G	Project:	Purpose of Issue:	Issue:
M002	MBNL	NTQ	Planning	B
Date:	30/04/21	Revision / Upgrade Description:		
Drawn:	R. PERKINS	Tower updated		
Checked:	A. FANNING			
Approved:	P. CONVERY			
Master:	MBNL / EE / H3G	Project:	Purpose of Issue:	Issue:
M001	MBNL	NTQ	Planning	A
Date:	01/04/21	Revision / Upgrade Description:		
Drawn:	J. BOOTE	First Issue		
Checked:	J. STOCKDALE			
Approved:	J. STOCKDALE			



Hutchison 3G UK Limited
Star House, 20 Grenfell Road
Macclesfield, SL6 1EH
Tel: 01628 765 000
Fax: 01628 765 001



Hatfield Business Park
Hatfield
Hertfordshire
AL10 9BW
Tel: 01707 315000
Fax: 01707 319001



Mobile Broadband Network Limited
Sixth Floor, Thames Tower, Station Road, Reading, RG1 1LX

Design Consultant & Principal Contractor:



WHP Telecoms
Unit 1 Maple Park,
Low Fields Avenue, Leeds
LS12 6HH

Tel: 01133023550
e-mail: info@whptelecoms.com

Site Name:
CLUB 3000 BINGO HUYTON

Site ID:
1632340

Address:
CLUB 3000 BINGO HUYTON,
POPLAR BANK,
HUYTON, LIVERPOOL,
MERSEYSIDE,
L36 9US

Title:
200 PROPOSED SHARED SITE PLAN

Project:
NTQ

Purpose of Issue:
GENERAL ARRANGEMENT

EE Cell ID: 92410	MBNL Cell ID: KSY083	3UK Cell ID: -
----------------------	-------------------------	-------------------

Master Drawing No: 1632340_KSY083_92410_M002	Issue: B
---	-------------